







WATERLOO REGIONAL HEALTH NETWORK @ MIDTOWN - PET CT
24048 | 835 KING ST W, KITCHENER, ON N2G 1G3
WATERLOO REGIONAL HEALTH NETWORK

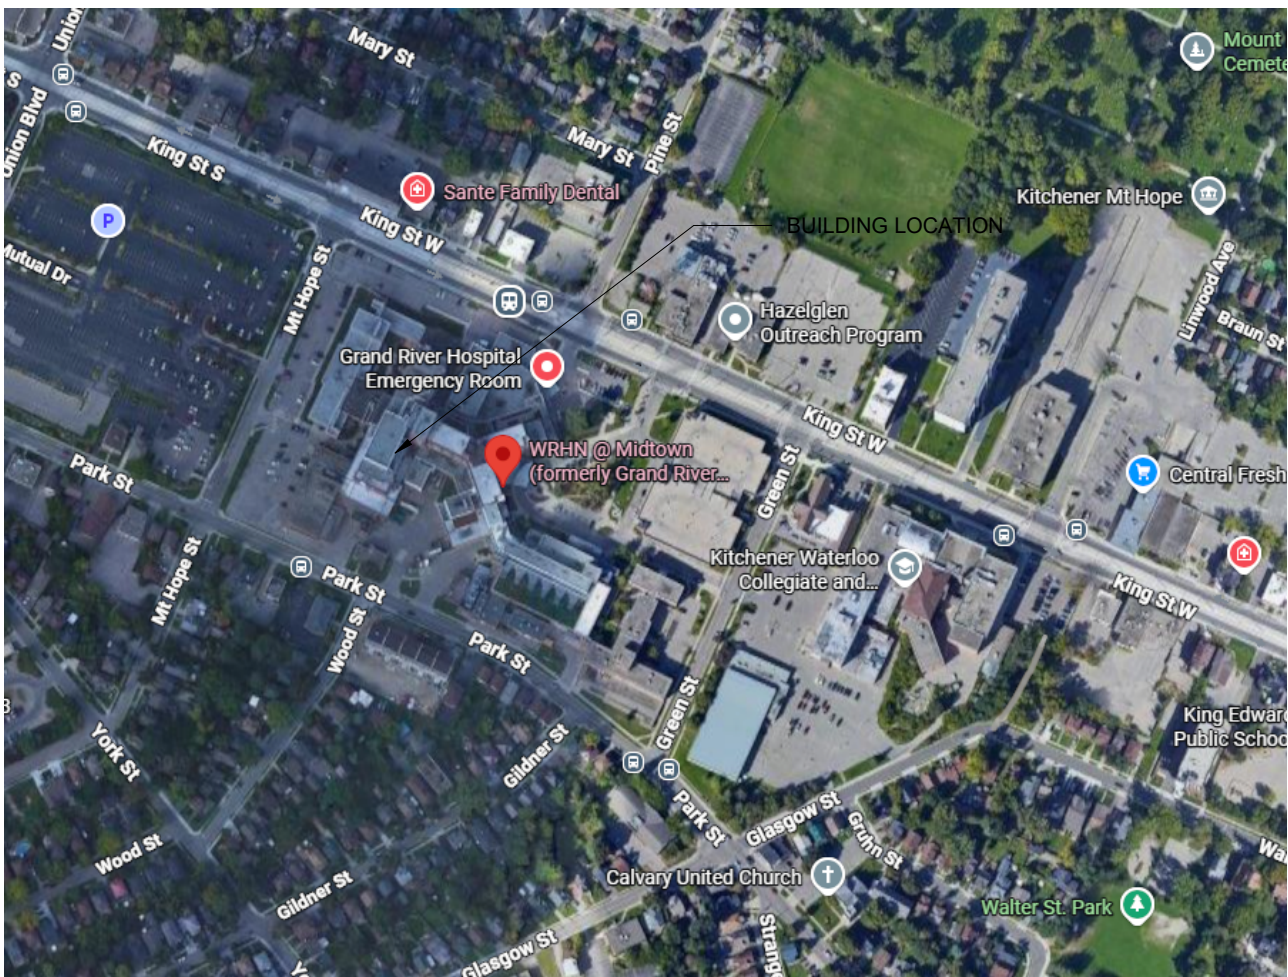

SHEET LIST - ELECTRICAL			SHEET LIST - ARCHITECTURAL		
NO.	NAME		NO.	NAME	
E000	GENERAL NOTES, LEGENDS AND DRAWING LIST		A0.0	COVER PAGE	
E001	SCHEDULES		A1.0	GENERAL INFORMATION	
E050	SPECIFICATIONS 1		A1.1	TYPICAL DETAILS	
E051	SPECIFICATIONS 2		A1.2	WALL ASSEMBLIES, ROOM FINISH SCHEDULE, DOOR AND FRAME SCHEDULE	
E200	LEVEL 1 DEMOLITION LIGHTING AND DEVICES		SK1.5	SECOND FLOOR KEY PLAN	
E201	LEVEL 1 PROPOSED LIGHTING AND DEVICES		SK1.7	CONTRACTOR ACCESS PLAN	
E202	LEVEL 2 DEMOLITION LIGHTING		D1.1	DEMOLITION L1 ENLARGED FLOOR PLAN	
E203	LEVEL 2 PROPOSED LIGHTING		D1.2	DEMOLITION L1 ENLARGED REFLECTED CEILING PLAN	
E300	LEVEL 2 PROPOSED POWER AND SYSTEMS PLAN		D1.3	DEMOLITION L2 ENLARGED FLOOR PLAN	
E301	LEVEL 2 PROPOSED POWER & SYSTEMS PLAN		A2.1	PROPOSED L1 ENLARGED FLOORING / HOARDING PLAN	
E302	LEVEL 3 AND ROOF PROPOSED POWER & SYSTEMS PLAN		A2.2	PROPOSED L2 ENLARGED FLOOR PLAN	
E400	SIEMENS INSTALLATION REFERENCE DRAWING SHEET 1		A2.3	ENLARGED L2 REFLECTED CEILING PLAN	
E401	SIEMENS INSTALLATION REFERENCE DRAWING SHEET 2		A3.1	PROPOSED INTERIOR ELEVATIONS	
E402	SIEMENS INSTALLATION REFERENCE DRAWING SHEET 3		A3.2	PROPOSED INTERIOR ELEVATIONS	
E403	SIEMENS INSTALLATION REFERENCE DRAWING SHEET 4		A3.3	PROPOSED INTERIOR ELEVATIONS AND DETAILS	
E404	SIEMENS INSTALLATION REFERENCE DRAWING SHEET 5				
E500	SINGLE LINE DIAGRAMS		SHEET LIST - MECHANICAL		
E501	SINGLE LINE DIAGRAMS				
E502	PANEL SCHEDULES - NEW PANELS		NO.	NAME	
E503	PANEL SCHEDULES - EXISTING PANELS				
E600	DETAILS		M001	GENERAL NOTES & DRAWING LIST	
			M002	LEGENDS & ABBREVIATIONS	
			M100	LEVEL 1 FIRE PROTECTION DEMO & PROPOSED PLAN	
			M101	LEVEL 2 FIRE PROTECTION DEMO & PROPOSED PLAN	
			M200	LEVEL 2 PLUMBING DEMO PLAN	
			M201	LEVEL 2 PLUMBING PROPOSED PLAN	
			M300	LEVEL 1 DRAINAGE DEMO & PROPOSED PLAN	
			M301	LEVEL 2 DRAINAGE DEMO & PROPOSED PLAN	
			M400	LEVEL 2 MEDICAL GAS DEMO & PROPOSED PLAN	
			M500	LEVEL 1 HVAC DEMO & PROPOSED PLAN	
			M501	LEVEL 2 HVAC DEMOLITION PLAN	
			M502	LEVEL 2 HVAC PROPOSED PLAN - CT SCANNER AREA	
			M503	LEVEL 2 HVAC PROPOSED PLAN - INJECTION ROOM AREA	
			M600	LEVEL 2 HYDRONIC DEMO & PROPOSED PLAN	
			M700	MECHANICAL PENTHOUSE HVAC PLAN	
			M800	ROOF - MECHANICAL PLAN	
			M900	SCHEMATIC	
			M1000	CONTROL DIAGRAMS	
			M1100	DETAILS	
			M1101	DETAILS	
			M1102	DETAILS	
			M1200	SCHEDULES	
SHEET LIST - STRUCTURAL					
NO.	NAME				
S1.1	LEVEL 3 FRAMING PLAN				
S1.2	PENTHOUSE ROOF FRAMING PLAN				

mcCallumSather  

 WRHN Waterloo Regional Health Network		
PROJECT LOGO		
KEY PLAN		
ISSUED FOR TENDER (2026.02.27)		
PRELIMINARY - NOT FOR CONSTRUCTION		
#	ISSUED FOR TENDER	2026-02-27
7	RE-ISSUED FOR PERMIT	2026-02-25
6	ISSUED FOR TENDER	2025-12-12
5	ISSUED FOR PERMIT	2025-11-28
4	FINAL DESIGN DEVELOPMENT SET	2025-11-07
3	FINAL DESIGN DEVELOPMENT SET	2025-10-31
2	100% DESIGN DEVELOPMENT PROGRESS SET	2025-09-29
1	50% DESIGN DEVELOPMENT PROGRESS SET	2025-05-09
No.	DESCRIPTION	DATE
REVISIONS:		
DISCREPANCIES MUST BE REPORTED IMMEDIATELY TO THE ARCHITECT / ENGINEER BEFORE PROCEEDING.		
ONLY FIGURED DIMENSIONS MUST BE USED.		
THE CONTRACTOR MUST CHECK THE DIMENSIONS ON SITE.		
THE DRAWING IS PROTECTED BY COPYRIGHT.		
ALL DIMENSIONS ARE SHOWN IN MILLIMETERS.		
DO NOT SCALE THE DRAWINGS.		
mccallumsather Westinghouse HQ, 2nd Floor 286 Sanford Ave. N. Hamilton, ON L8L 6A1 905.526.4700 www.mccallumsather.com		
		
SEAL		
CONSULTANTS:		
PROJECT: WATERLOO REGIONAL HEALTH NETWORK @ MIDTOWN - PET CT		
835 KING ST W, KITCHENER, ON N2G 1G3		
DRAWING TITLE: COVER PAGE		
DRAWN BY:	SB	DATE: 2026-02-27
CHECKED BY:	GL	SCALE: As indicated
PROJECT NO.: 24048		
DRAWING NO.: A0.0		

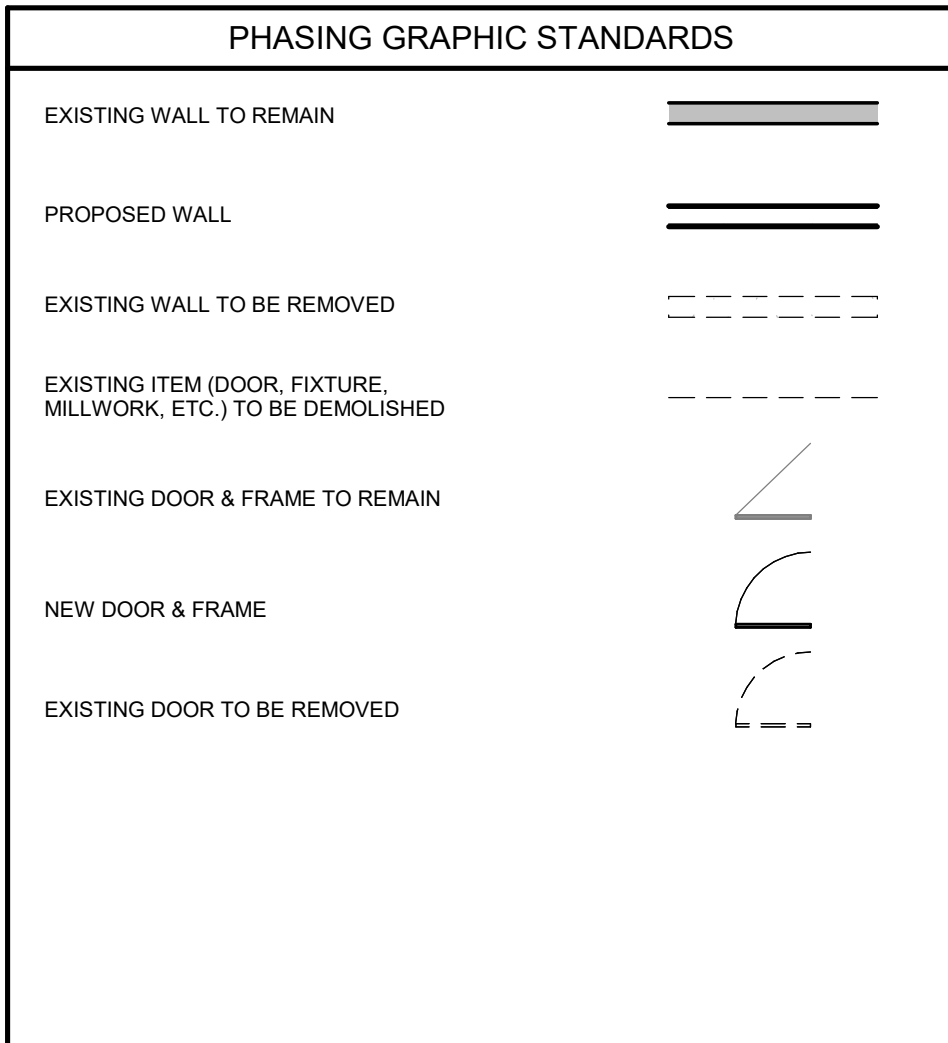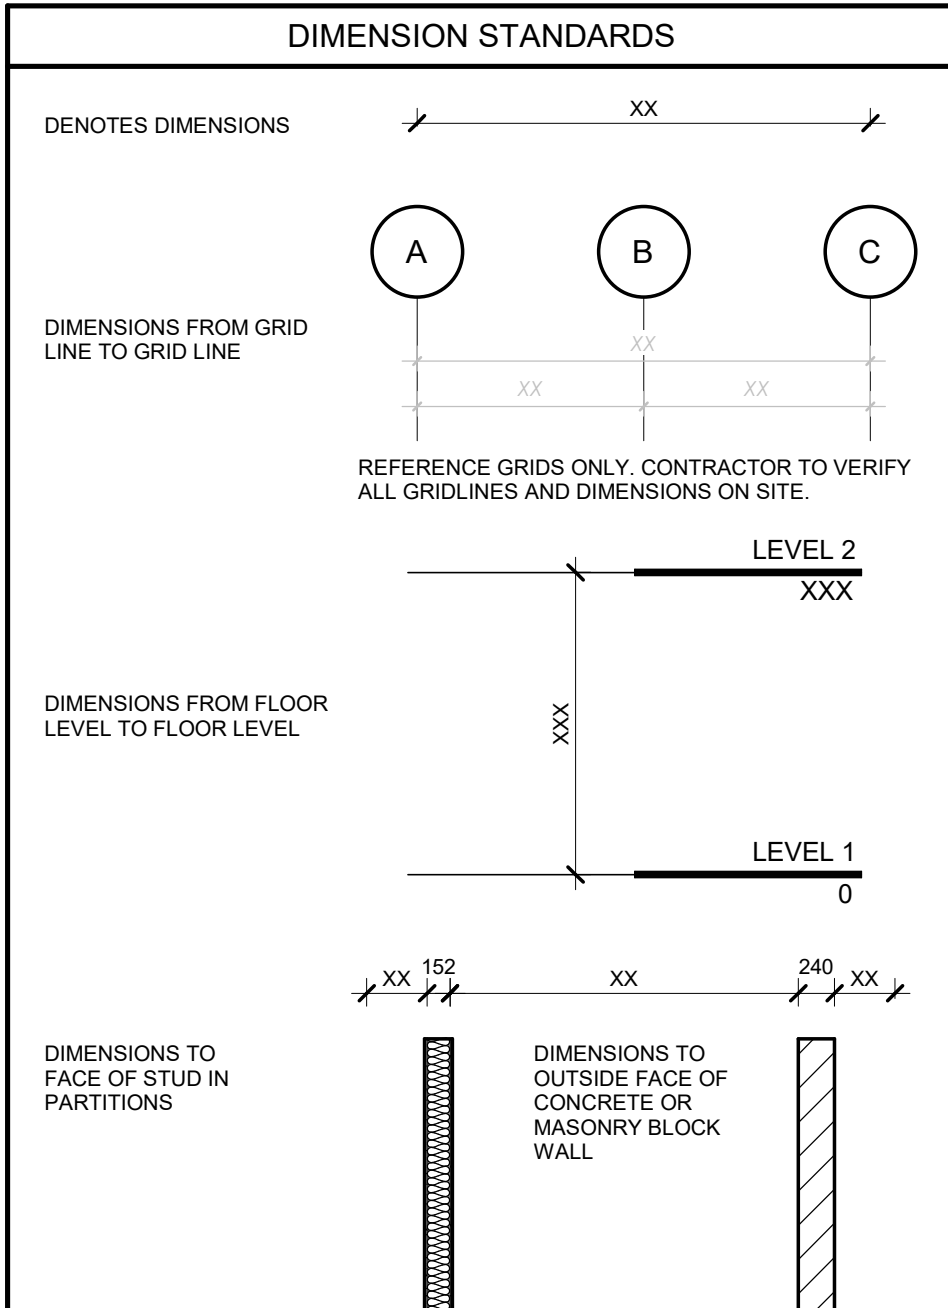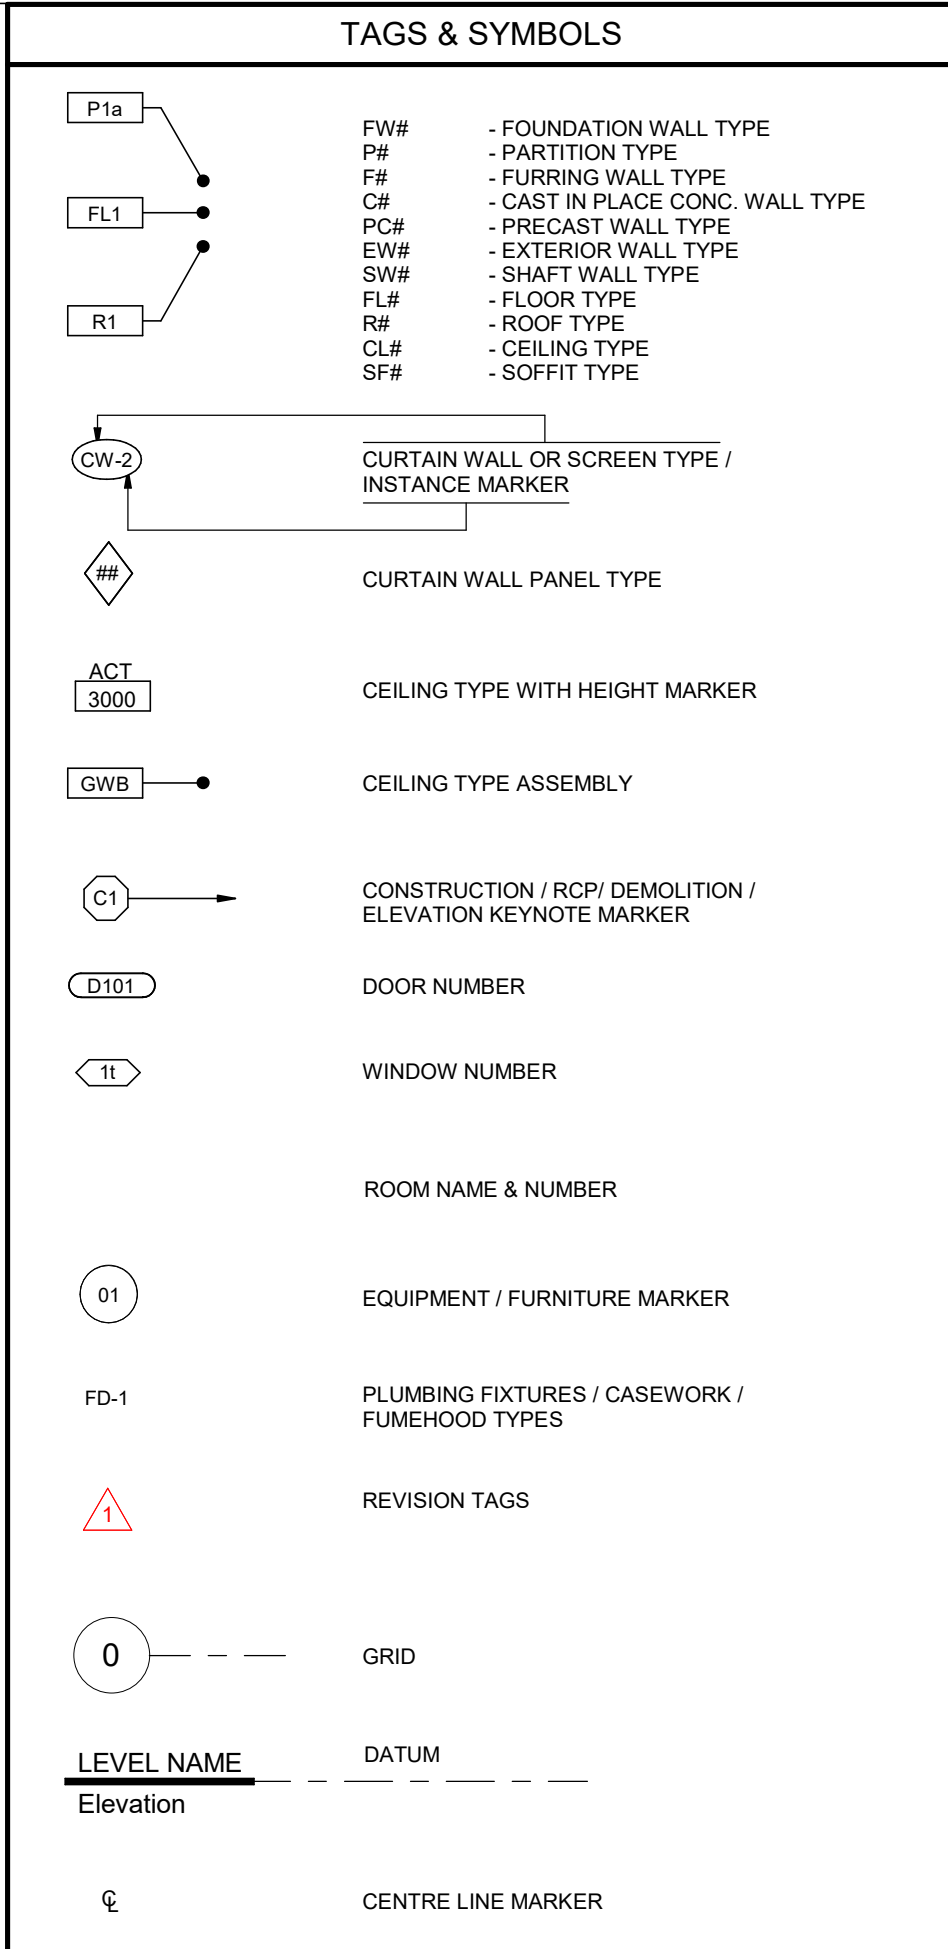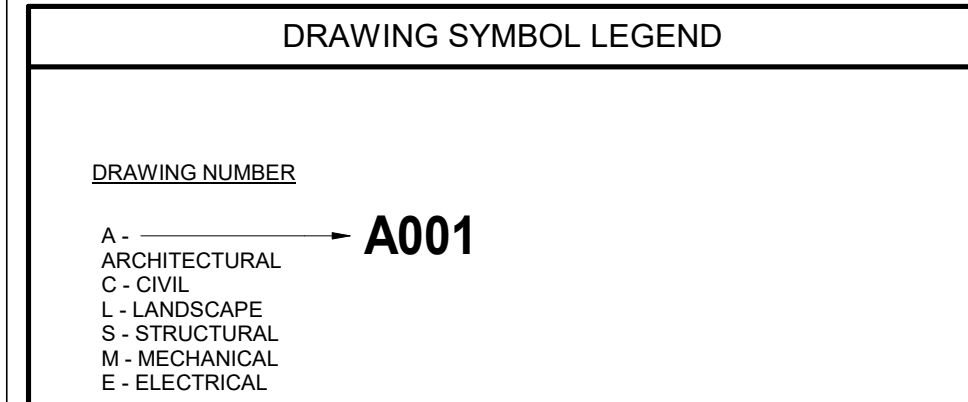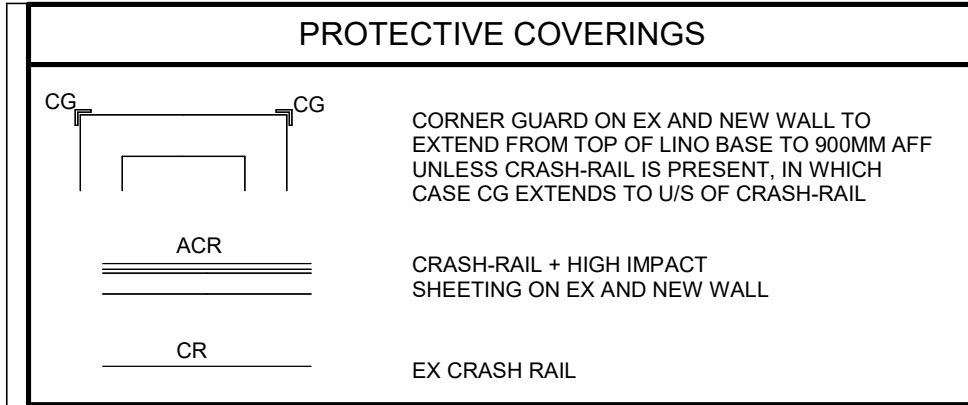

GENERAL CONSTRUCTION NOTES

DRAWINGS & SPECIFICATIONS OF ALL DISCIPLINES TO BE READ TOGETHER. ANY NOTE, DRAWING, OR DETAIL SHOWN OR SPECIFIED IN ONE DISCIPLINE IS APPLICABLE TO ALL DISCIPLINES.

CONSTRUCTION NOTES:


- SITE VERIFY ALL DIMENSIONS PRIOR TO INSTALLATIONS.
- WHERE FIRE SEPARATIONS ARE PENETRATED AS PART OF THE WORK, PROVIDE FIRE STOPPING TO REQ'D RATING.
- WHERE UNRATED FIRE SEPARATION IS INDICATED, PROVIDE SMOKE SEALANT AT ALL PENETRATIONS & PERIMETER JOINTS.
- COORDINATE LOCATIONS OF BACKING (3/4" PLY) IN WALL FOR WALL-MOUNTED ELEMENTS (CRASH-RAIL, EQUIPMENT, WASHROOM ACCESSORIES ETC). REFER TO PLANS, INT ELEVATIONS, & SPECIFICATIONS.
- LOCATIONS OF ELECTRICAL, DOOR HARDWARE, WASHROOM ACCESSORIES, EQUIPMENT, HANDRAILS, CRASHRAILS, ETC (AS APPLICABLE) NOT PROVIDED IN INTERIOR ELEVATIONS ARE TO BE CONFIRMED WITH THE ARCHITECT PRIOR TO INSTALLATION.
- UNLESS NOTED OTHERWISE, MOUNTING FIXTURES, EQUIPMENT, ETC ACROSS BUILDING EXPANSION JOINTS ON PARTITIONS/WALLS OR CLGS IS NOT PERMITTED.
- WHERE PROVISION OF FIRE SUPPRESSION COMPONENTS ARE REQ'D AS PART OF THE WORK, SPRINKLER HEAD COUNT, LOCATION, & STYLE SHOWN ARE FOR GENERAL DESIGN PURPOSES ONLY.
- SPRINKLER CONTRACTOR TO PRICE A COMPLETE & OPERATIONAL SYSTEM AND INCLUDE SUFFICIENT QUANTITIES & STYLES OF HEADS, MATERIALS, PIPE SIZES, FITTINGS, & COMPONENTS FOR AN NFPA 13 COMPLIANT SYSTEM.
- ANY INFORMATION (E.G. ON EX SYSTEM) REQ'D IS TO BE OBTAINED DIRECTLY BY THE CONTRACTOR AT NO ADDITIONAL COST TO THE CONTRACT.
- SPRINKLER SYSTEM TO BE ACTIVE WHEN WORKERS ARE NOT ON SITE, THROUGHOUT THE LENGTH OF THE PROJECT, WHEN NOT FEASIBLE, CONTRACTOR TO MEET REQUIREMENTS OF THE MUNICIPAL AUTHORITY VIA FIRE ALARM SYSTEM (ACTIVE SMOKE DETECTORS) OR BY PROVIDING FIRE WATCH.
- WHERE SYSTEMS FURNITURE IS TO BE PROVIDED AS PART OF THE WORK, CONTRACTOR IS RESPONSIBLE TO COORDINATE RELEVANT WORK OF ALL TRADES WITH SUPPLIER AND CONFIRM THE SAME WITH THE OWNER (E.G. FOR VERTICAL & HORIZONTAL LOCATIONS OF ELEC OUTLETS).
- ALLOW FOR RELOCATION OF FIXTURES & DEVICES WITHIN 305MM OF LOCATION SHOWN - PRIOR TO INSTALLATION, AT NO ADDITIONAL COST TO CONTRACT.
- FLOORS IN ALL ROOMS W/ FLOOR DRAINS ARE TO BE SLOPED IN ALL DIRECTIONS AT 2%. BUILD UP SUB-FLOOR TO OBTAIN REQ'D SLOPE. COORDINATE ANY IMPACT ON ADJACENT ELEMENTS (FINISHES, DOORS, FIXTURES, EQUIPMENT, ETC).
- PROVIDE CONTINUOUS BEAD OF SILICONE COLOUR-MATCHED SEALANT AT ALL JOINTS OF DISSIMILAR MATERIALS AND/OR SURFACES (TILE, CRASH-RAIL, FLOORING BASE, ETC) IN FINISHED SPACES AS APPLICABLE.
- FIRE RESISTANCE RATINGS ARE INDICATED AT PARTITIONS. PARTITIONS SHOWN RATED ARE TO BE CONSTRUCTED AS FIRE-SEPARATION ASSEMBLIES BUILT TO U/S ROOF FLOOR/DECK ABOVE, FOR PARTITIONS SHOWN RATED, PROVIDE FIRE STOPPING AT TOP OF WALL AND AT PENETRATIONS.

DEMOLITION NOTES


- DRAWINGS & SPECIFICATIONS OF ALL DISCIPLINES TO BE READ TOGETHER. ANY NOTE, DRAWINGS, OR DETAIL SHOWN OR SPECIFIED IN ONE DISCIPLINE IS APPLICABLE TO ALL DISCIPLINES.
- PATCH AND MAKE GOOD (TO BASE BUILDING STANDARDS) MECHANICAL COMPONENTS AND FINISHES DAMAGED DURING HE RENOVATION. PROVIDE INSULATED CAPPED CURBS EQUAL TO OR BETTER THAN ROOF R-VALUE FOR FANS, GOOSE NECK OPENINGS AND VENTS BEING ADDED AND REMOVED.
- DEMOLISHED WORK SHALL INCLUDE FOR TEMPORARY AND PERMANENT WORK REQUIRED TO KEEP ACTIVE PREMISES IN OPERATION. COORDINATE TIMES, ACCESS, TEMPORARY HOODING TEMPORARY SCAFFOLDING, TOOL/LIGHT POWER REQUIREMENTS AND OTHER MISCELLANEOUS ITEMS NEEDED TO COMPLETE WORK WITH GENERAL CONTRACTOR IN OCCUPIED AREA AT NIGHT OR IN ACCORDANCE WITH THE OWNER APPROVED SCHEDULE.
- DEMOLITION OF INTERIOR WALLS, ROOF, CEILING AND FLOOR FINISHES TO BE SEQUENCED WITH THE OWNER, IN AREAS WHERE ADJACENT OCCUPANCIES ARE NOT IN THE DEMOLITION AREA BUT AFFECTED BY NOISE OF DEMOLITION, OR WHERE TRADE REQUIRES ACCESS TO EXISTING OCCUPIED SPACES, CONTRACTOR SHALL COORDINATE TIMES OF WORK THROUGH THE OWNER.
- SUPPLY AIR DUCTWORK AND PIPING NOT SHOWN HATCHED IS TO BE RETAINED. ANY DAMAGE TO EXISTING INSULATION AND DUCTS TO BE REPAIRED TO MATCH EXISTING.
- DURING DEMOLITION WORK, ALL MECHANICAL SYSTEMS AND BUILDING SERVICES SERVING OCCUPIED AREAS SHALL BE MAINTAINED OPERATIONAL, WHERE SYSTEM OR SERVICE INTERRUPTIONS ARE REQUIRED, COORDINATE AFTER HOUR ACCESS REQUIREMENTS AND SECURITY EXECUTE WORK WITH CONSTRUCTION MANAGER/OWNER.
- REMOVE ALL EXISTING ELEMENTS AND FINISHES NECESSARY FOR THE COMPLETION OF THE WORK AS SHOWN ON THE DRAWINGS. INCLUDING BUT NOT LIMITED TO: ITEMS SHOWN IN DASHED LINES. NECESSARY DISCONNECTS AND ALTERATIONS TO EXISTING MECHANICAL AND ELECTRICAL SYSTEMS SHALL BE INCLUDED. PATCH AS REQUIRED ALL AREAS/ELEMENTS TO REMAIN IN ACCORDANCE WITH THE CONTRACT DRAWINGS. WHERE CONTRACTOR IS DESIGNATED TO MAKE REMOVALS, ESRI ETCETERA EACH WAY EPOXY WALL COATING EQUIPMENT PANEL EX EXISTING EXPOSED EXTERIOR
- DISPOSITION OF MATERIALS IS THE RESPONSIBILITY OF THE CONTRACTOR. VERIFY WITH OWNER. THE DISPOSITIONS AND REMOVAL OF ANY COMPONENTS OF SALVAGEABLE VALUE.
- REMOVE ONLY NON-LOAD BEARING WALLS AND PARTITIONS. CONTRACTOR TO VERIFY, PRIOR TO REMOVAL, THAT NO STRUCTURAL COMPONENTS, I.E. BEARING WALLS, BEAMS, HEADERS, ETC., SUPPORTING FLOOR, ROOF OR CEILING JOISTS ARE DESIGNATED FOR REMOVAL. CONTACT THE ARCHITECT PRIOR TO REMOVAL OF ANY ELEMENTS IN QUESTION OR DEVIATING FROM THE DESIGN INTENT. CONTRACTORS NON-CONTACT OF ARCHITECT PRIOR TO REMOVAL OF ANY WORK, INDICATES HIS COMPLETE UNDERSTANDING THAT NO LOAD BEARING OR STRUCTURAL WORKS IS BEING ALTERED UNDER THIS CONTRACT.

ABBREVIATIONS		
A	AT	F
@	AIR BARRIER	FBLT
A8	AIR CONDITIONING	FD
AC	HANDICAP ACTUATOR	FDC
ACP	ALUMINUM COMPOSITE PANEL	FE
ACT	ACUSTIC CEILING TILE	FEF
ACC	ACCESS FLOOR	FF
AF	ACUSTIC FIRE BATT	FHC
AFB	ABOVE FINISHED FLOOR	FINISH
AFB	ASPHALT IMPREGNATED FIBRE BOARD	FL
AHU	AIR HANDLING UNIT	FLASH
AL	ALUMINUM	FND
ALUM	ALUMINUM	FP
ANOD	ANODIZED	FR
ANP	ANNUNCIATOR PANEL	FRG
AP	ACCESS PANEL	FRF
APPROX	APPROXIMATE	FS
AR	ABUSE RESISTANT	FT
ARCH	ARCHITECTURAL	FTG
AUD	AUDITORIUM	FUR
AVB	AIR / VAPOUR BARRIER	G
AV	AUDIO / VISUAL	GA
B	BOARD	GALV
BD	BOTTOM EACH WAY	GC
BEW	BARRIER FREE	GFWB
BF	BUMPER GUARD	GL
BG	BUILDING	GLAZ
BLK	BLOCK	GRAN
BLL	BOTTOM LOWER LAYER	GWB
BM	BENCH MARK	GWG
BN	BULLNOSED	GYP
BP	BASE PLATE	
BR	BRICK	
BRD	BOARD	
BSMT	BASEMENT	
BSP	BENT STEEL PLATE	
BTM	BOTTOM	
BIF	BETWEEN	
BU	STEEL BUILT UP (TO OWS)	
BUL	BOTTOM LOWER LAYER	
C	CATCH BASIN	
CA	CLEAR ANODIZED	
CB	CATCH BASIN	
CBD	CEMENT BOARD	
C/C	CENTER TO CENTER	
CG	CORNER GUARD	
CIP	CAST IN PLACE	
CJ	CONSTRUCTION JOINT	
CL	CENTER LINE	
CLR	CEILING	
CLST	CLOSET	
CMP	COMPOSITE METAL PANEL	
CM	CONCRETE MASONRY UNIT	
COL	COLUMN	
COL	CONSTRUCTION	
CONST	CONTINUOUS	
CONT	CONCRETE	
CONC	CONCRETE	
COORD	COORDINATE	
CORR	CORRIDOR	
CP	COMMUNICATION/DATA PANEL	
CR	CARD READER	
CRS	COURSE	
CT	CURTAIN TRACK	
CW	COMPLETE WITH	
CIV	CIVIL	
CW	CURTAIN TRACK	
D	DOOR	
DB	DOOR BELL	
DBLT	DEAD BOLT	
DBL	DOUBLE	
DBN	DOUBLE BULLNOSED	
DC	DOOR CLOSER	
DCA	DOOR CONTROL ALARM	
DEG	DEGREE	
DEMO	DEMOLITION	
DF	DIAMETER	
DIA	DIAMETER	
Ø	DIAMETER	
DIM	DIMENSION	
DIV	DIVISION	
DN	DOWN	
DP	DEMOUNTABLE PARTITION	
DSL	DOOR STOP	
DS	DOOR SEAL	
DSW	DOOR SWEEP	
DT	DETAIL	
DWG(S)	DRAWING(S)	
E	EACH	
EA	EACH FACE	
EF	ELEVATION	
ELEC	ELECTRICAL	
ELEV	ELEVATION	
ECC	EPOXY CEILING COATING	
EFC	EPOXY FLOOR COATING	
EJ	EXPANSION JOINT	
ELEC	ELECTRICAL	
EMP	EMERGENCY POWER	
ENCL	ENCLOSED	
EP	ELECTRICAL PANEL	
EQ	EQUAL	
EQU	EQUIPMENT	
ES	ELECTRIC STRIKE	
ESRI	ELECTRIC STRIKE ROUGH-IN	
ETCETERA	ETCETERA	
EW	EACH WAY	
EWC	EPOXY WALL COATING	
EOP	EQUIPMENT PANEL	
EX	EXISTING	
EXP	EXPOSED	
EXT	EXTERIOR	
F	FLUSH BOLT	
FD	FLOOR DRAIN	
FDC	FIRE DEPARTMENT CONNECTION	
FE	FIRE EXTINGUISHER	
FEF	FIRE EXTINGUISHER CABINET	
FF	FACTORY FINISH	
FHC	FIRE HOSE CABINET	
FINISH	FINISH	
FL	FLOOR	
FLASH	FLASHING	
FND	FOUNDATION	
FP	FACTORY PRIMED (SITE PAINTED)	
FR	FRAME	
FRG	FIRE RATED GLASS	
FRF	FIRE RESISTANCE RATING	
FS	FIRE SEPARATION	
FT	FEET	
FTG	FOOTING	
FUR	FURNITURE	
G	GAUGE	
GA	GALVANIZED	
GC	GENERAL CONTRACTOR	
GFWB	GYPSON FIBRE WALL BOARD	
GL	GLAZING	
GLAZ	GLAZING	
GRAN	GRANULAR	
GWB	GYPSON WALL BOARD	
GWG	GEORGIAN WIRE GLASS	
GYP	GYPSON	
H	HOSE BIB	
HB	HEAVY DUTY	
HD	HORIZONTAL EACH FACE	
HEF	HORIZONTAL INSIDE FACE	
HFL	HORIZONTAL OUTSIDE FACE	
HM	HOLLOW METAL	
HOF	HORIZONTAL OUTSIDE FACE	
HORIZ	HORIZONTAL	
HR	HANG RAIL	
HRL	HOLLOW STRUCTURAL STEEL	
HSS	HEATING, VENTILATION AND AIR CONDITIONING	
HT	HEIGHT	
HTR	HEATER	
HP	HIGH POINT	
HVAC	HVAC	
I	INSULATED GLAZING UNIT	
IGU	INCLUDED IN CONTRACT	
IC	INSIDE DIMENSION	
ID	INSIDE DIMENSION	
IF	INSIDE FACE	
IHM	INSULATED HOLLOW METAL	
INCL	INCLUDED	
INSUL	INSULATION	
INT	INTERIOR	
IRWB	IMPACT RESISTANT WALL BOARD	
J	JANITOR	
JAN	JANITOR	
JT	JOINT	
K	KICKPLATE	
KP	KICKPLATE	
KPD	KEY PAD	
L	LAMINATE	
LAM	LAMINATE	
LAV	LAVATORY	
LINO	LINOLEUM	
LSG	LINOLEUM SAFETY GLASS	
LWT	LIGHT WEIGHT	
LP	LOW POINT	
LS	LOCK SET	
M	METRES	
MAG	MAGNETIC LOCK	
MANUF	MANUFACTURED	
MAX	MAXIMUM	
MAT	MATERIAL	
MDF	MEDIUM DENSITY FIBRE BOARD	
MECH	MECHANICAL	
MED	MEDIUM	
MEMB	MEMBRANE	
MEZZ	MEZZANINE	
MH	MANHOLE	
MHO	MAGNETIC HOLD OPEN	
MIN	MINIMUM	
MIR	MIRROR	
MISC	MISCELLANEOUS	
ML	MAGNETIC LOCK	
MLRI	MAGNETIC LOCK ROUGH IN	
MLWK	MILLWORK	
MO	MASONRY OPENING	
MOD	MODIFIED BUTYEM	
MSU	MEDICAL SERVICE UNIT	
MTL	METAL	
MTD	MOUNTED	
MS	MOTION SENSOR	
MKE	MECHANICAL & ELECTRICAL	
N	NATIONAL BUILDING CODE	
NBC	NATIONAL BUILDING CODE	
NIC	NOT IN CONTRACT	
NFB	NON FREEZER HOSE BIB	
NO	NOT TO SCALE	
NTS	NOT TO SCALE	
O	ONTARIO BUILDING CODE	
OBC	ON CENTER	
O/C	OUTSIDE DIMENSION	
OD	OUTSIDE FACE	
OF	OFFICE	
OFFC	OVERHEAD	
OPDS	ONTARIO PROVINCIAL STANDARD DETAIL	
OPSS	ONTARIO PROVINCIAL STANDARD SPECIFICATION	
OSB	ORIENTED STRAND BOARD	
OWSJ	OPEN WEB STEEL JOIST	
P	PARTITION	
PT	PARTITION	
PB	PUSH BUTTON	
PBCQ	PUSH BUTTON UNDER COUNTER	
PED	PEDESTAL	
PLAM	PLASTIC LAMINATE	
PLYWD	PLYWOOD	
POLY	POLYETHYLENE	
PREFIN	PREFINISHED	
PRHT	PARTIAL HEIGHT	
PRHT	PRESSURE TREATED	
PTD	PAINTED	
R	RADIUS	
RAD	REFLECTED CEILING PLAN	
RCP	ROOF DRAIN	
RD	REQUIRED	
REIN	REINFORCED	
REQD	REQUIRED	
REQTS	REQUIREMENTS	
RENO	RENOVATION	
RES	RECESSED	
RFE	RECESSED FIRE EXTINGUISHER	
RHC	RECESSED HEATING CABINET	
ROOM	ROOM	
RM	ROUGH OPENING	
RUB	RUBBER	
RTU	ROOF TOP UNIT	
RSF	RESILIENT SHEET FLOORING	
RWL	RAIN WATER LEADER	
S	SINK	
SEG	SEGREGATION	
SE	SQUARE FT	
SC	SAW CUT	
SCWD	SOLID WOOD	
SH	SHEET	
SHG	SHEATHING	
SIM	SIMILAR	
SOG	SLAB ON GRADE	
SPEC	SPECIFICATION	
SPF	SPRUCE PINE FIR	
SQ	SOLID RESURFACING	
SQ.FT	SQUARE FEET	
SQ.M	SQUARE METERS	
ST	STAINED	
ST	STEEL	
STOR	STORAGE	
STRUCT	STRUCTURAL	
STL	STEEL	
STM	STORM	
STRUCT	STRUCTURAL	
SUSP	SUSPENDED	
SWRD	SIDE WALL ROOF DRAIN	
T	TILE	
TH	THERMALLY BROKEN	
TB	TO BE DETERMINED	
TBD	TO BE DETERMINED	
TBHM	THERMALLY BROKEN HOLLOW METAL	
TEMP	TEMPERED	
TH	THICKNESS	
THK	THICKNESS	
TJ	THE JOIST	
TLL	TOP LOWER LAYER	
TRANS	TRANSITION	
TTL	THUMB TURN LOCK	
TRW	THROUGH WALL FLASHING	
TIO	TOP OF	
TUL	TOP UPPER LAYER	
TYP	TYPICAL	
U	UNDERGROUND	
U/G	UNDERGROUND	
UR	UNLESS NOTED OTHERWISE	
URS	UNDERGROUND	
V	VAPOUR BARRIER	
VB	VAPOUR BARRIER	
VCT	VINYL COMPOSITE TILE	
VEST	VESTIBULE	
VERT	VERTICAL	
VEF	VERTICAL EACH FACE	
VIF	VERTICAL INSIDE FACE	
VOF	VERTICAL OUTSIDE FACE	
VR	VAPOUR RETARDER	
W	WIDE	
WC	WATER CLOSET	
WD	WOOD	
WDF	WALL MOUNTED FIRE EXTINGUISHER	
WV	WATER VALVE	
WWM	WELDED WIRE MESS	
WO	WITHOUT	
W/R	WASHROOM	
W	WITH	


Ontario Building Code Data Matrix Part 3					Building Code Reference																															
3.00	Building Code Version:	O. Reg. 332/12		Last Amendment	O. Reg. 89/23	All references are to Division B of the OBC. Unless preceded by [A] for Division A and [C] for Division C.																														
3.01	Project Type:	☐ New ☐ Addition ☐ Change of Use ☒ Alteration				[A] 1.1.2.																														
3.02	Major Occupancy Classification:	Occupancy: B2 Use: CARE AND TREATMENT				3.1.2.1.																														
3.03	Superimposed Major Occupancy:	☐ Yes ☒ No Description: _____				3.2.2.7.																														
3.04	Building Area (m ²):	Existing 19,015.4 New 0 Total 19,015.4				[A] 1.4.1.2.																														
3.05	Gross Area (m ²):	Level _____ Existing UNCHANGED New - Total _____ Level _____ Existing _____ New _____ Total _____ Total Area: 75,531.4				[A] 1.4.1.2.																														
3.06	Mezzanine(s) Area (m ²)	Description: N/A Existing - New - Total -				3.2.1.1.																														
3.07	Building Height	8 Above grade (storeys) 13 Building Height above grade (m) 1 Below grade (storeys)				[A] 1.4.1.2. & 3.2.1.1.																														
3.08	High Building	☒ Yes ☐ No				3.2.6.																														
3.09	Number of Streets/ Fire Fighter Access:	3 Street(s)				3.2.2.10. & 3.2.5.																														
3.10	Building Classification (Size & Construction Relative to Occupancy)	OBC Reference: 3.2.2.28 Group/Division: GROUP B, Division 2				3.2.2.28																														
3.11	Sprinkler System	☒ Required ☐ Not Required Proposed: ☒ entire building ☐ selected compartments ☐ selected floor areas ☐ basement ☐ in lieu of roof rating ☐ not required				3.2.1.5. & 3.2.2.17. 3.2.2.18. 3.2.4.8. to 3.2.4.10. and 3.2.5.13.																														
3.12	Standpipe System	☒ Required ☐ Not Required				3.2.9.																														
3.13	Fire Alarm System	☒ Required ☐ Not Required Proposed: ☐ Single Stage ☐ Two Stage ☐ None				3.2.4.																														
3.14	Water Service/Supply is Adequate	☒ Yes ☐ No				3.2.5.7.																														
3.15	Construction Type:	Restriction: ☐ Combustible permitted ☒ Non combustible required ☐ Encapsulated mass timber Actual: ☐ Combustible ☒ Non combustible ☐ Combination of combustible and non-combustible ☐ Encapsulated mass timber ☐ Combination of encapsulated mass timber and non-combustible Heavy Timber Construction: ☐ Yes ☒ No				3.2.2.20. - 83. & 3.2.1.4.																														
3.16	Importance Category:	☐ Low ☐ Low human occupancy ☐ Post-disaster shelter ☒ Normal ☐ Minor storage building ☐ Explosive or hazardous substances ☒ High ☒ Post-disaster				4.1.2.1.(3) & Table 4.1.2.1.B																														
3.17	Seismic Hazard Index:	(I _e Fa Sa (0.2)) = - Seismic design required for Table 4.1.8.18. Items 6 to 21: (I _e Fa Sa (0.2)) ≥ 0.35 or Post-disaster ☐ Yes ☐ No				4.1.2.1.(3) 4.1.8.18.(1)																														
3.18	Occupant Load	Floor Level/Area Occupancy Based on (m ² /person or Design) Load (Persons) Posted Limit Required GROUND B2 EXISTING - NO CHANGE SECOND B2 EXISTING - NO CHANGE				3.1.17. & 3.1.17.1.(2)																														
3.19	Barrier-free Design: Barrier-free Entrances:	☒ Yes ☐ No (Explain) N/A Number _____ (Explain) _____				3.8.																														
3.20	Hazardous Substances	☐ Yes ☐ No(Explain) N/A				3.1.8.2.																														
3.21	Required Fire Resistance Rating (FRR)	<table><thead><tr><th>Horizontal Assemblies</th><th>Supporting Assemblies</th><th colspan="3">Noncombustible in lieu of rating?</th></tr></thead><tbody><tr><td>Storeys below grade 1 Hours</td><td>1 Hours</td><td>☐ Yes</td><td>☐ No</td><td>☐ N/A</td></tr><tr><td>Floors over basement 2 Hours</td><td>2 Hours</td><td>☐ Yes</td><td>☐ No</td><td>☐ N/A</td></tr><tr><td>Floors 2 Hours</td><td>2 Hours</td><td>☐ Yes</td><td>☐ No</td><td>☐ N/A</td></tr><tr><td>Roof 1 Hours</td><td>1 Hours</td><td>☐ Yes</td><td>☐ No</td><td>☐ N/A</td></tr><tr><td>Mezzanine N/A Hours</td><td>N/A Hours</td><td>☐ Yes</td><td>☐ No</td><td>☐ N/A</td></tr></tbody></table>				Horizontal Assemblies	Supporting Assemblies	Noncombustible in lieu of rating?			Storeys below grade 1 Hours	1 Hours	☐ Yes	☐ No	☐ N/A	Floors over basement 2 Hours	2 Hours	☐ Yes	☐ No	☐ N/A	Floors 2 Hours	2 Hours	☐ Yes	☐ No	☐ N/A	Roof 1 Hours	1 Hours	☐ Yes	☐ No	☐ N/A	Mezzanine N/A Hours	N/A Hours	☐ Yes	☐ No	☐ N/A	3.2.2.20. & 3.3.1. 3.2.1.2. 3.2.1.4. 3.2.2.15.
Horizontal Assemblies	Supporting Assemblies	Noncombustible in lieu of rating?																																		
Storeys below grade 1 Hours	1 Hours	☐ Yes	☐ No	☐ N/A																																
Floors over basement 2 Hours	2 Hours	☐ Yes	☐ No	☐ N/A																																
Floors 2 Hours	2 Hours	☐ Yes	☐ No	☐ N/A																																
Roof 1 Hours	1 Hours	☐ Yes	☐ No	☐ N/A																																
Mezzanine N/A Hours	N/A Hours	☐ Yes	☐ No	☐ N/A																																
3.22	Spatial Separation - Construction of Exterior Walls					3.2.3.																														
	Exposing Building Face	Area of EBF (m ²)	LD (m)	H/L or H/L (FRR) (Hours)	% Unprotected Openings Permitted	% Unprotected Openings Provided	Construction Type	Cladding Type																												
	North	N/A	N/A	N/A	N/A	N/A	N/A	☐ Noncombustible																												
	South	N/A	N/A	N/A	N/A	N/A	N/A	☐ Noncombustible																												
	East	N/A	N/A	N/A	N/A	N/A	N/A	☐ Noncombustible																												
	West	N/A	N/A	N/A	N/A	N/A	N/A	☐ Noncombustible																												
3.23	Plumbing Fixtures Requirements					3.7.4., 3.8.2.3., Tables 3.8.2.3.A and 3.8.2.3.B																														
	Male/Female Count @ except as noted otherwise	50 %	50 %	OBC Reference	WCs Required	WCs Provided	Barrier-free WCs Required	Barrier-free WCs Provided	Universal Washrooms Required	Universal Washrooms Provided																										
	Floor _____	Occupant Load _____		3.7.4.7.	N/A																															
	Floor _____	Occupant Load _____		3.7.4.7.	N/A																															
3.24	Energy Efficiency:	Compliance Path: _____ Climate Zone: _____ Degree Days Below 18 C: _____									12.2.1.2. SB-1 Table2																									
3.25	Sound Transmission Design:	Is there more than 1 dwelling unit per building?: ☐ Yes ☐ No Option Implemented: Notes: _____									SB-3. 5.8.1.2.(2), 5.8.1.4., & 5.8.1.5.																									

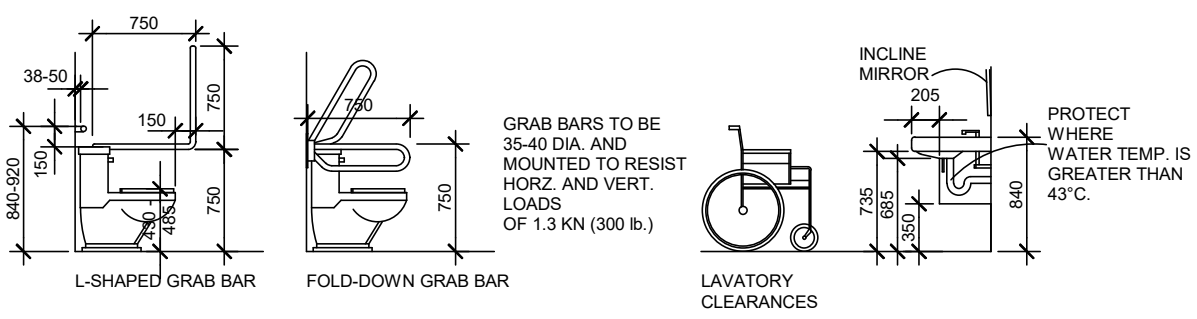

BARRIER FREE CLEARANCES

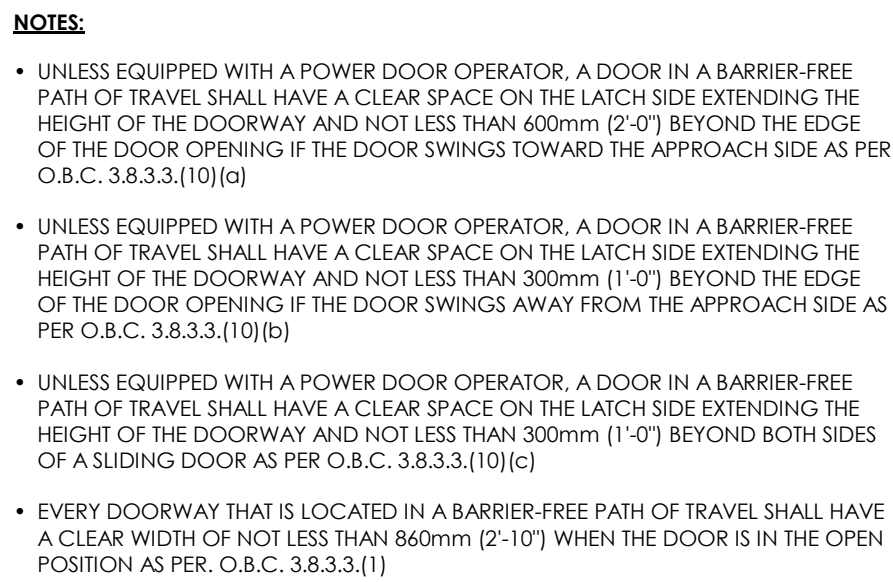

TYPICAL UNIVERSAL WASHROOM DOOR ELEVATIONS

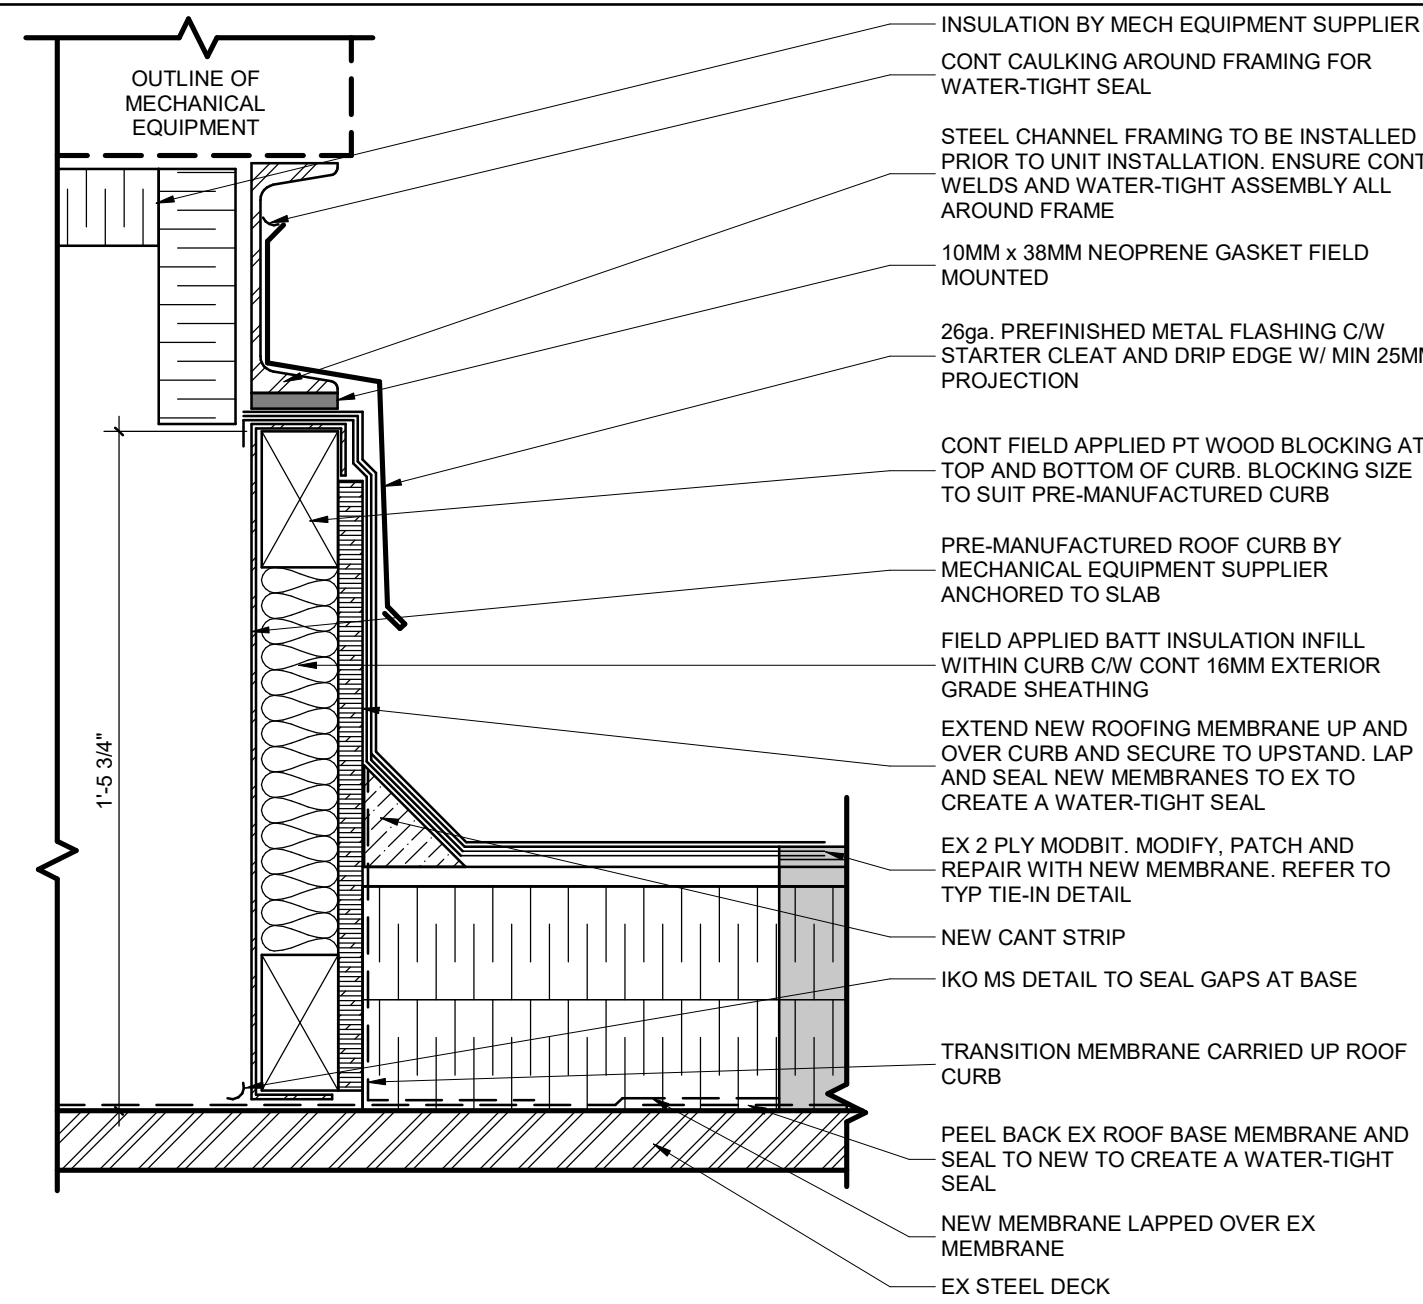

DUCT DETAIL AT ROOF




ROOM FINISH SCHEDULE - PHASE 1										
ROOM NO.	ROOM NAME	FLOORS		WALLS				CEILINGS		REMARKS
		FINISH	BASE	NORTH	EAST	SOUTH	WEST	MATERIAL	FINISH	
B1	BLANKET WARMER	SF1	RB1	P13/WP1	P13/WP1	P13/WP1	P13	GWB/ACT1	PT1	
B2	BLANKET WARMER									
I06	HOT LAB	EX						GWB/ACT1	PT1	
I07	MACHINE ROOM	SF2	RB1	P15	P15	P15	P15	ACT1		
I07b	SUPPLY	EX								
I08	PET CT	SF2	RB1	P15	P15	P15	P15	ACT1/LCP		REFER TO ENLARGED RCP FOR LOCATION OF LUMINOUS CEILING PANEL
I12	STAFF ROOM	SF1	RB1	P15	P15	P15	P15	ACT1		
I13	EVS ROOM	SF1	RB1	P13	P15/WP2	P15/WP2	P15/WP2	GWB/ACT1		
I14	SUPPLY	SF1	RB1	P15	P15	P15	P15	ACT1		
I15	HOT WR	SF1	RB1	P15/WP2	P15/WP2	P15/WP2	P15/WP2	GWB/ACT1		
I16	INJECTION ROOM-1	SF1	RB1	P15/WP2	WP3	P15/WP2	P15/WP2	GWB/ACT1	PT1	
I17	RAD OFFICE	SF1	RB1	P15	P15	P15	P15	GWB/ACT1	PT1	
I18	INJECTION ROOM-4	SF1	RB1	WP3	P15/WP2	P15/WP2	P15/WP2	GWB/ACT1	PT1	
I19	INJECTION ROOM-3	SF1	RB1	WP3	P15/WP2	P15/WP2	P15/WP2	GWB/ACT1	PT1	
I20	INJECTION ROOM-2	SF1	RB1	WP3	P15/WP2	P15/WP2	P15/WP2	GWB/ACT1	PT1	
I21	STRETCHER WAITING	SF1	RB1	P13/WP1	P13/WP1	P13/WP1	P13/WP1	GWB/ACT1	PT1	WP4 HANDRAIL
B	CORRIDOR	SF1	RB1	P13/WP1	P13/WP1	P13/WP1	P13/WP1	GWB/ACT1	PT1	WP4 HANDRAIL
B1	BLANKET WARMER	SF1	RB1	P13/WP1	P13/WP1	P13/WP1	P13/WP1	GWB/ACT1	PT1	

FINISH SPECIFICATION SCHEDULE					
Abbreviation	MANUFACTURER	PRODUCT	DESCRIPTION	APPLICATION	COMMENTS
ACOUSTIC CEILING TILE					
ACT1	ARMSTRONGS	CORTEGA ANGLED TEGULAR PANEL	COLOUR: WHITE - 24" X 48" X 5/8" #789	LAY IN CEILING TILE	
PAINT					
PT1	BENJAMIN MOORE	LOW VOC PAINT	COLOUR: CHANTILLY LACE	PAINT - CEILINGS	
PT2	SHERWIN WILLIAMS	LOW VOC PAINT	COLOUR: TO MATCH EXISTING 'HERON GREY'	PAINT - DOORS & FRAMES	
PT3	SHERWIN WILLIAMS	LOW VOC PAINT	COLOUR: TO MATCH EXISTING 'IVORY SILK' 2007	PAINT - CORRIDOR FIELD COLOUR	
PT4	SHERWIN WILLIAMS	LOW VOC PAINT	COLOUR: TO MATCH PANTONE '4039 C'	PAINT - CORRIDOR SIGNAGE ACCENTS	
PT5	SHERWIN WILLIAMS	LOW VOC PAINT	COLOUR: TO MATCH PANTONE 'WARM GRAY 1C'	PAINT - ENCLOSED ROOMS FIELD COLOUR	
PT6	SHERWIN WILLIAMS	LOW VOC PAINT	COLOUR: TO MATCH PANTONE '4039 C'	PAINT - END OF CORRIDOR B WEST WALL	
RUBBER BASE					
RB1	TARKETT	JOHNSONITE TRADITIONAL BASE	COLOUR 'PEARL CB' 22 - HEIGHT - 4"	WALL BASE	
SHEET FLOORING					
SF1	POLYFLOR	POLYFLOR 'PEARLAZZO PUR'	COLOUR: TOASTED ALMOND #9716	FLOORING	
SF2	POLYFLOR	POLYFLOR 'PEARLAZZO PUR'	COLOUR: RAIN CLOUD #9718	FLOORING	
WALL PROTECTION					
WP1	CONSTRUCTION SPECIALTIES	ACROVYN SOLID COLOURS	COLOUR: PLUMICE #858	WALL PROTECTION - CORRIDORS	INSTALL IN A 4'-0" HIGH SHEET 4" AFF ABOVE RUBBER BASE; REFER TO ELEVATIONS
WP2	CONSTRUCTION SPECIALTIES	ACROVYN SOLID COLOURS	COLOUR: DRIFTWOOD #262	WALL PROTECTION - ENCLOSED ROOMS	INSTALL IN A 4'-0" HIGH SHEET 4" AFF ABOVE RUBBER BASE; REFER TO ELEVATIONS
WP3	CONSTRUCTION SPECIALTIES	ACROVYN BY DESIGN	PATTERN: PAPYRUS #14100; COLOUR: BIRCH	WALL PROTECTION- INJECTION ROOM FEATURE WALL	INSTALL FULL HEIGHT OF WALL 4" AFF ABOVE RUBBER BASE; REFER TO ELEVATIONS
WP4	CONSTRUCTION SPECIALTIES	ACROVYN SOLID COLORS	COLOR : SLATE #209	CORRIDOR HAND RAIL	INSTALL FULL HEIGHT OF WALL 4" AFF ABOVE RUBBER BASE; REFER TO ELEVATIONS


- ROOM FINISHING NOTES:**
- ALL UNFINISHED PARTITIONS/WALLS & CLGS SHALL BE PAINTED 'PT1' UNLESS NOTED OTHERWISE.
 - PAINT FINISHES ARE AS FOLLOWS: WALLS – EGGSHELL, DOORS & FRAMES – SEMI-GLOSS, GWB CLGS – FLAT. MATTE FINISH NOT PERMITTED ON WALLS.
 - PAINT ALL EXPOSED & UNFINISHED M&E EQUIPMENT (DUCTWORK, CONDUIT, PANELS, ETC), EXCEPT WHERE DISALLOWED BY APPLICABLE CODES & STANDARDS.
 - PAINT ALL STRUCT MEMBERS (COLUMNS, BEAMS, JOISTS, DECKS, SLABS, ETC) IN AREAS CALLING FOR PAINT FINISH.
 - PAINT ALL HM DOORS & FRAMES.
 - PAINT ALL EX PAINTED SURFACES.

DOOR AND HARDWARE SCHEDULE																							
F.R.R.	DOOR				FRAME			FINISH	HARDWARES													DOOR VIEWER	NOTES
	TYPE	SIZE	MAT.	FINISH	TYPE	MAT.	FUNCTION																
							PASSAGE SET		PRIVATE SET	APARTMENT SET	CLASSROOM SET	STORKOON SET	BUTT HINGES	180 HINGES	PANIC DEVICE	AUTO OPENER	ELEC. STRIKE	CLOSER	FLUSH BOLT	CARD READER	WEATHERSTRIP		
LEVEL 1																							
D107b	D	305 x 2134 - 864 x 2134	HCW	PT2	F1	HM	PT						X	X			X	X	-			1.6 mm LEAD LINING	
D108	E	2-3505 x 2134	HCW	PT2	F1	HCW	PT	X									X	X	X	-		SLIDING TRACK HARDWARE	
D112	A	965 x 2134	HCW	PT2	F1	HM	PT2					X	X				X	X	X	X			
D113	B	965 x 2134	HCW	PT2	F1	HM	PT2	X					X	X			X	X	X	-		1.6 mm LEAD LINING	
D114	A	914 x 2134	HCW	PT2	F1	HM	PT2					X	X				X	X	X	X		1.6 mm LEAD LINING	
D115	A	965 x 2134	HCW	PT2	F1	HM	PT2					X			X		X	X	X	-		1.6 mm LEAD LINING	
D116	B	1118 x 2134	HCW	PT2	F1	HM	PT2	X							X	X	X	X	X	-		1.6 mm LEAD LINING	
D117	B	965 x 2134	HCW	PT2	F1	HM	PT2					X			X	X	X	X	X	X		1.6 mm LEAD LINING	
D118	C	457 x 2134 - 1118 x 2134	HCW	PT2	F1	HM	PT2	X							X	X	X	X	X	X		1.6 mm LEAD LINING	
D119	C	457 x 2134 - 1118 x 2134	HCW	PT2	F1	HM	PT2	X							X	X	X	X	X	X		1.6 mm LEAD LINING	
D120	B	1118 x 2134	HCW	PT2	F1	HM	PT2	X							X	X	X	X	X	X		1.6 mm LEAD LINING	
D121	C	457 x 2134 - 1118 x 2134	HCW	PT2	F1	HM	PT2	X							X	X	X	X	X	X		1.6 mm LEAD LINING	

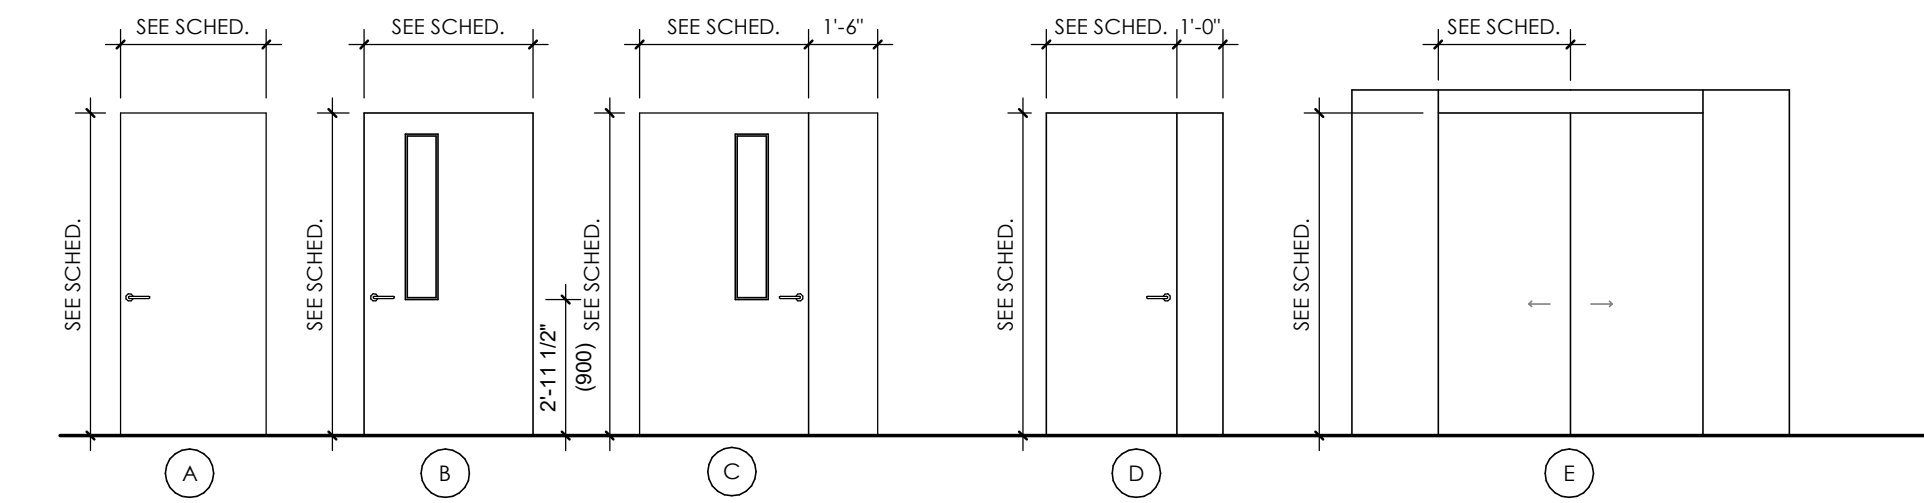


DOOR TYPES



INTERIOR WALL TYPES			
MARK	ASSEMBLY (PLAN VIEW)	ASSEMBLY DESCRIPTION	COMMENTS
WS1		WS1 - 16 mm DRYWALL - 92 MTL STUDS @ 400 mm o.c. - 3 mm LEAD SHEETING - 16 mm DRYWALL	
WS1a		WS1a *new wall built up against existing wall (solid block) - EXISTING BASE BUILDING SUBSTRATE - 92 MTL STUDS @ 400 mm o.c. - 3 mm LEAD SHEETING - 16 mm DRYWALL	
WS1b		WS1b - 16 mm DRYWALL - 150 mm MTL STUDS @ 400 mm o.c. - 16 mm DRYWALL	
WS1c		WS1c - 92 mm MTL STUDS @ 400 mm o.c. - 16 mm DRYWALL	
WS1d		WS1d - LAMINATE DRYWALL DIRECTLY TO SUBSTRATE	

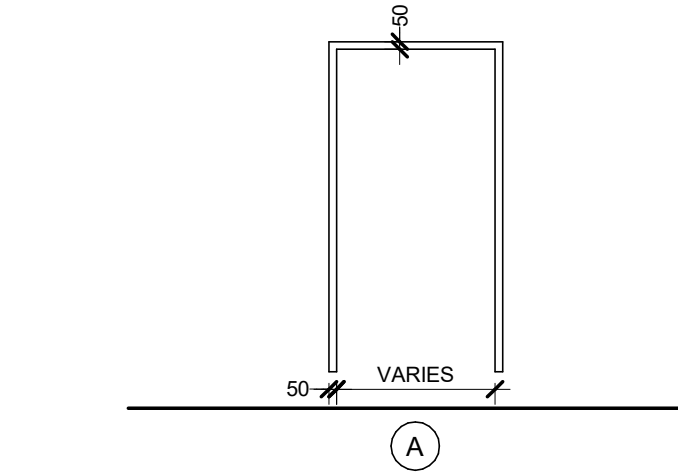

FRAME TYPES

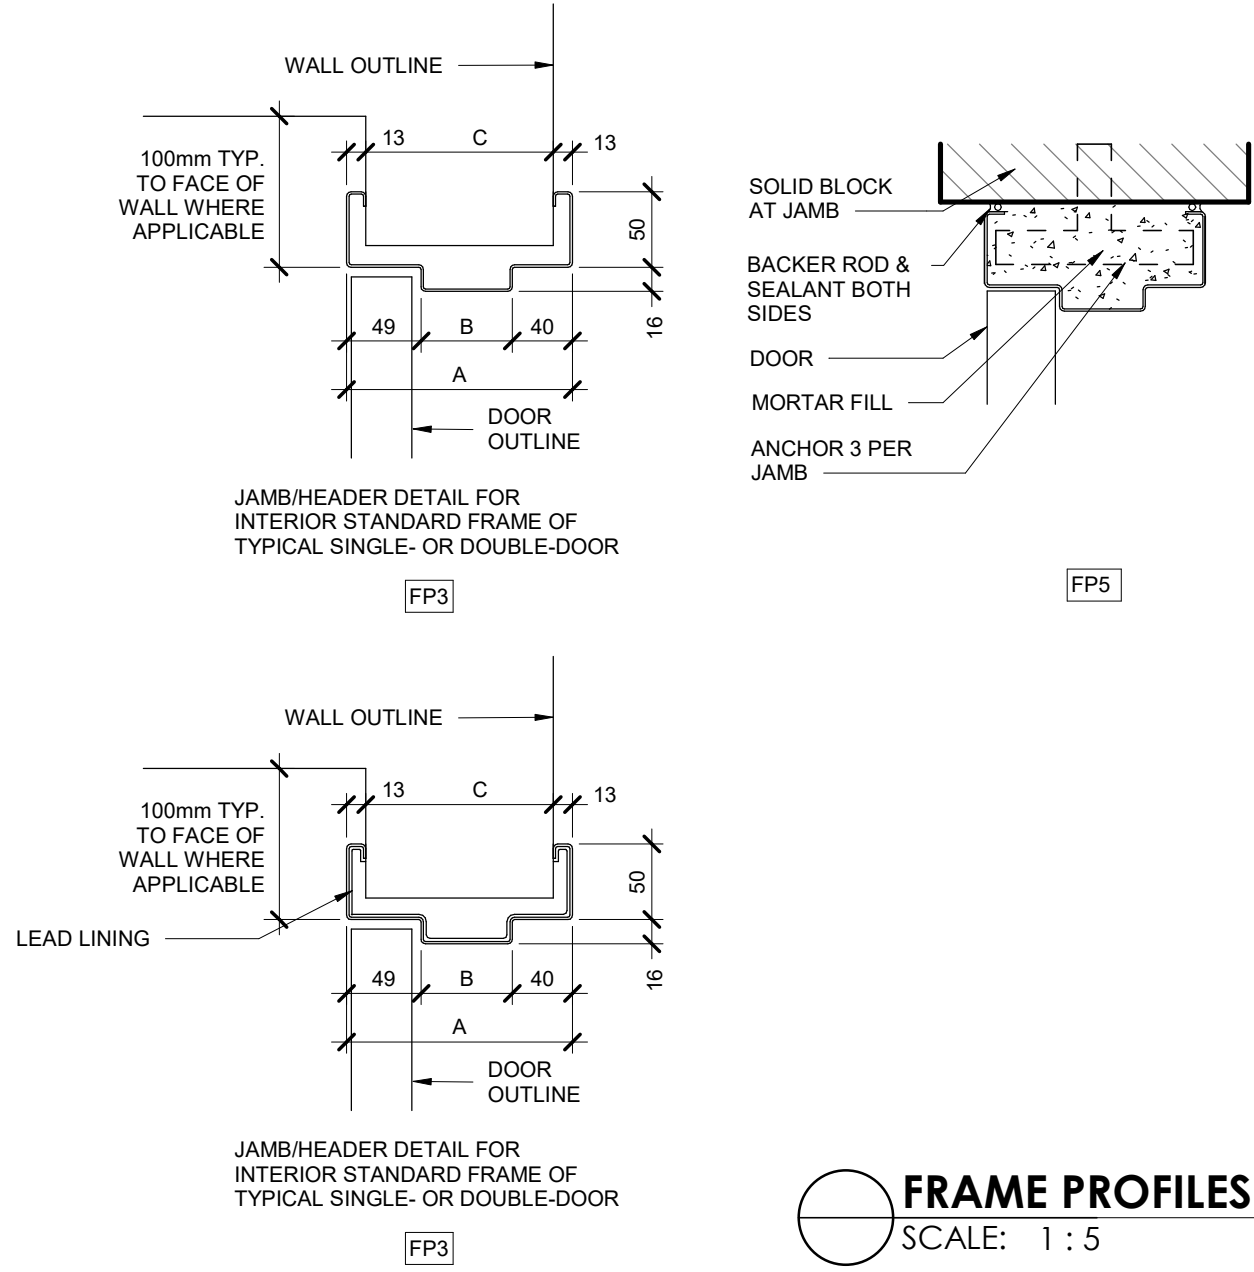

FRAME PROFILES
SCALE: 1 : 5

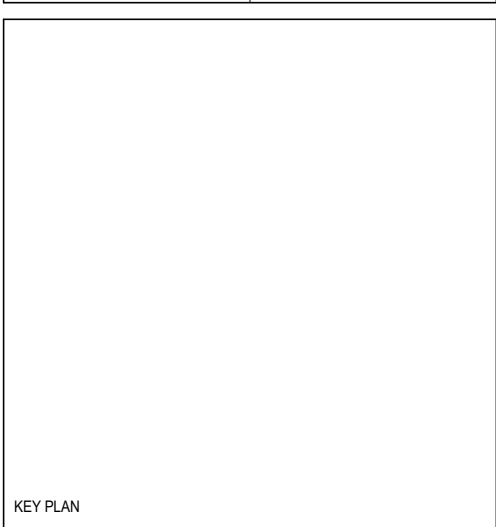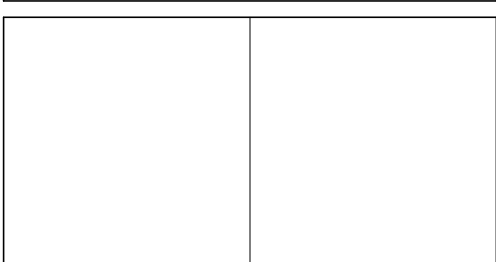

ISSUED FOR TENDER (2026.02.27)			
8	ISSUED FOR TENDER	2026-02-27	
7	RE - ISSUED FOR PERMIT	2026-02-25	
6	ISSUED FOR TENDER	2025-12-12	
5	ISSUED FOR PERMIT	2025-11-28	
4	FINAL DESIGN DEVELOPMENT SET	2025-11-07	
3	FINAL DESIGN DEVELOPMENT SET	2025-10-31	
2	100% DESIGN DEVELOPMENT PROGRESS SET	2025-09-29	
1	50% DESIGN DEVELOPMENT PROGRESS SET	2025-05-09	
No.	DESCRIPTION	DATE	
REVISIONS			
		2025-09-29	

DISCREPANCIES MUST BE REPORTED IMMEDIATELY TO THE ARCHITECT / ENGINEER BEFORE PROCEEDING.
ONLY FIGURED DIMENSIONS MUST BE USED.
THE CONTRACTOR MUST CHECK THE DIMENSIONS ON SITE.
THE DRAWING IS PROTECTED BY COPYRIGHT.
ALL DIMENSIONS ARE SHOWN IN MILLIMETERS.
DO NOT SCALE THE DRAWINGS.

McCallumSather
Westinghouse HQ, 2nd Floor
286 Sanford Ave. N
Hamilton, ON L8L 6A1
905.526.6700
www.mccallumsather.com



SEAL
CONSULTANTS:

PROJECT:
WATERLOO REGIONAL HEALTH NETWORK @ MIDTOWN - PET CT


835 KING ST W, KITCHENER, ON
N2G 1G3

DRAWING TITLE:
WALL ASSEMBLIES, ROOM FINISH SCHEDULE, DOOR AND FRAME SCHEDULE

DRAWN BY:	SB	DATE:	2025.10.31
CHECKED BY:	GL	SCALE:	As indicated

PROJECT NO.: **24048**


DRAWING NO.: **A1.2**

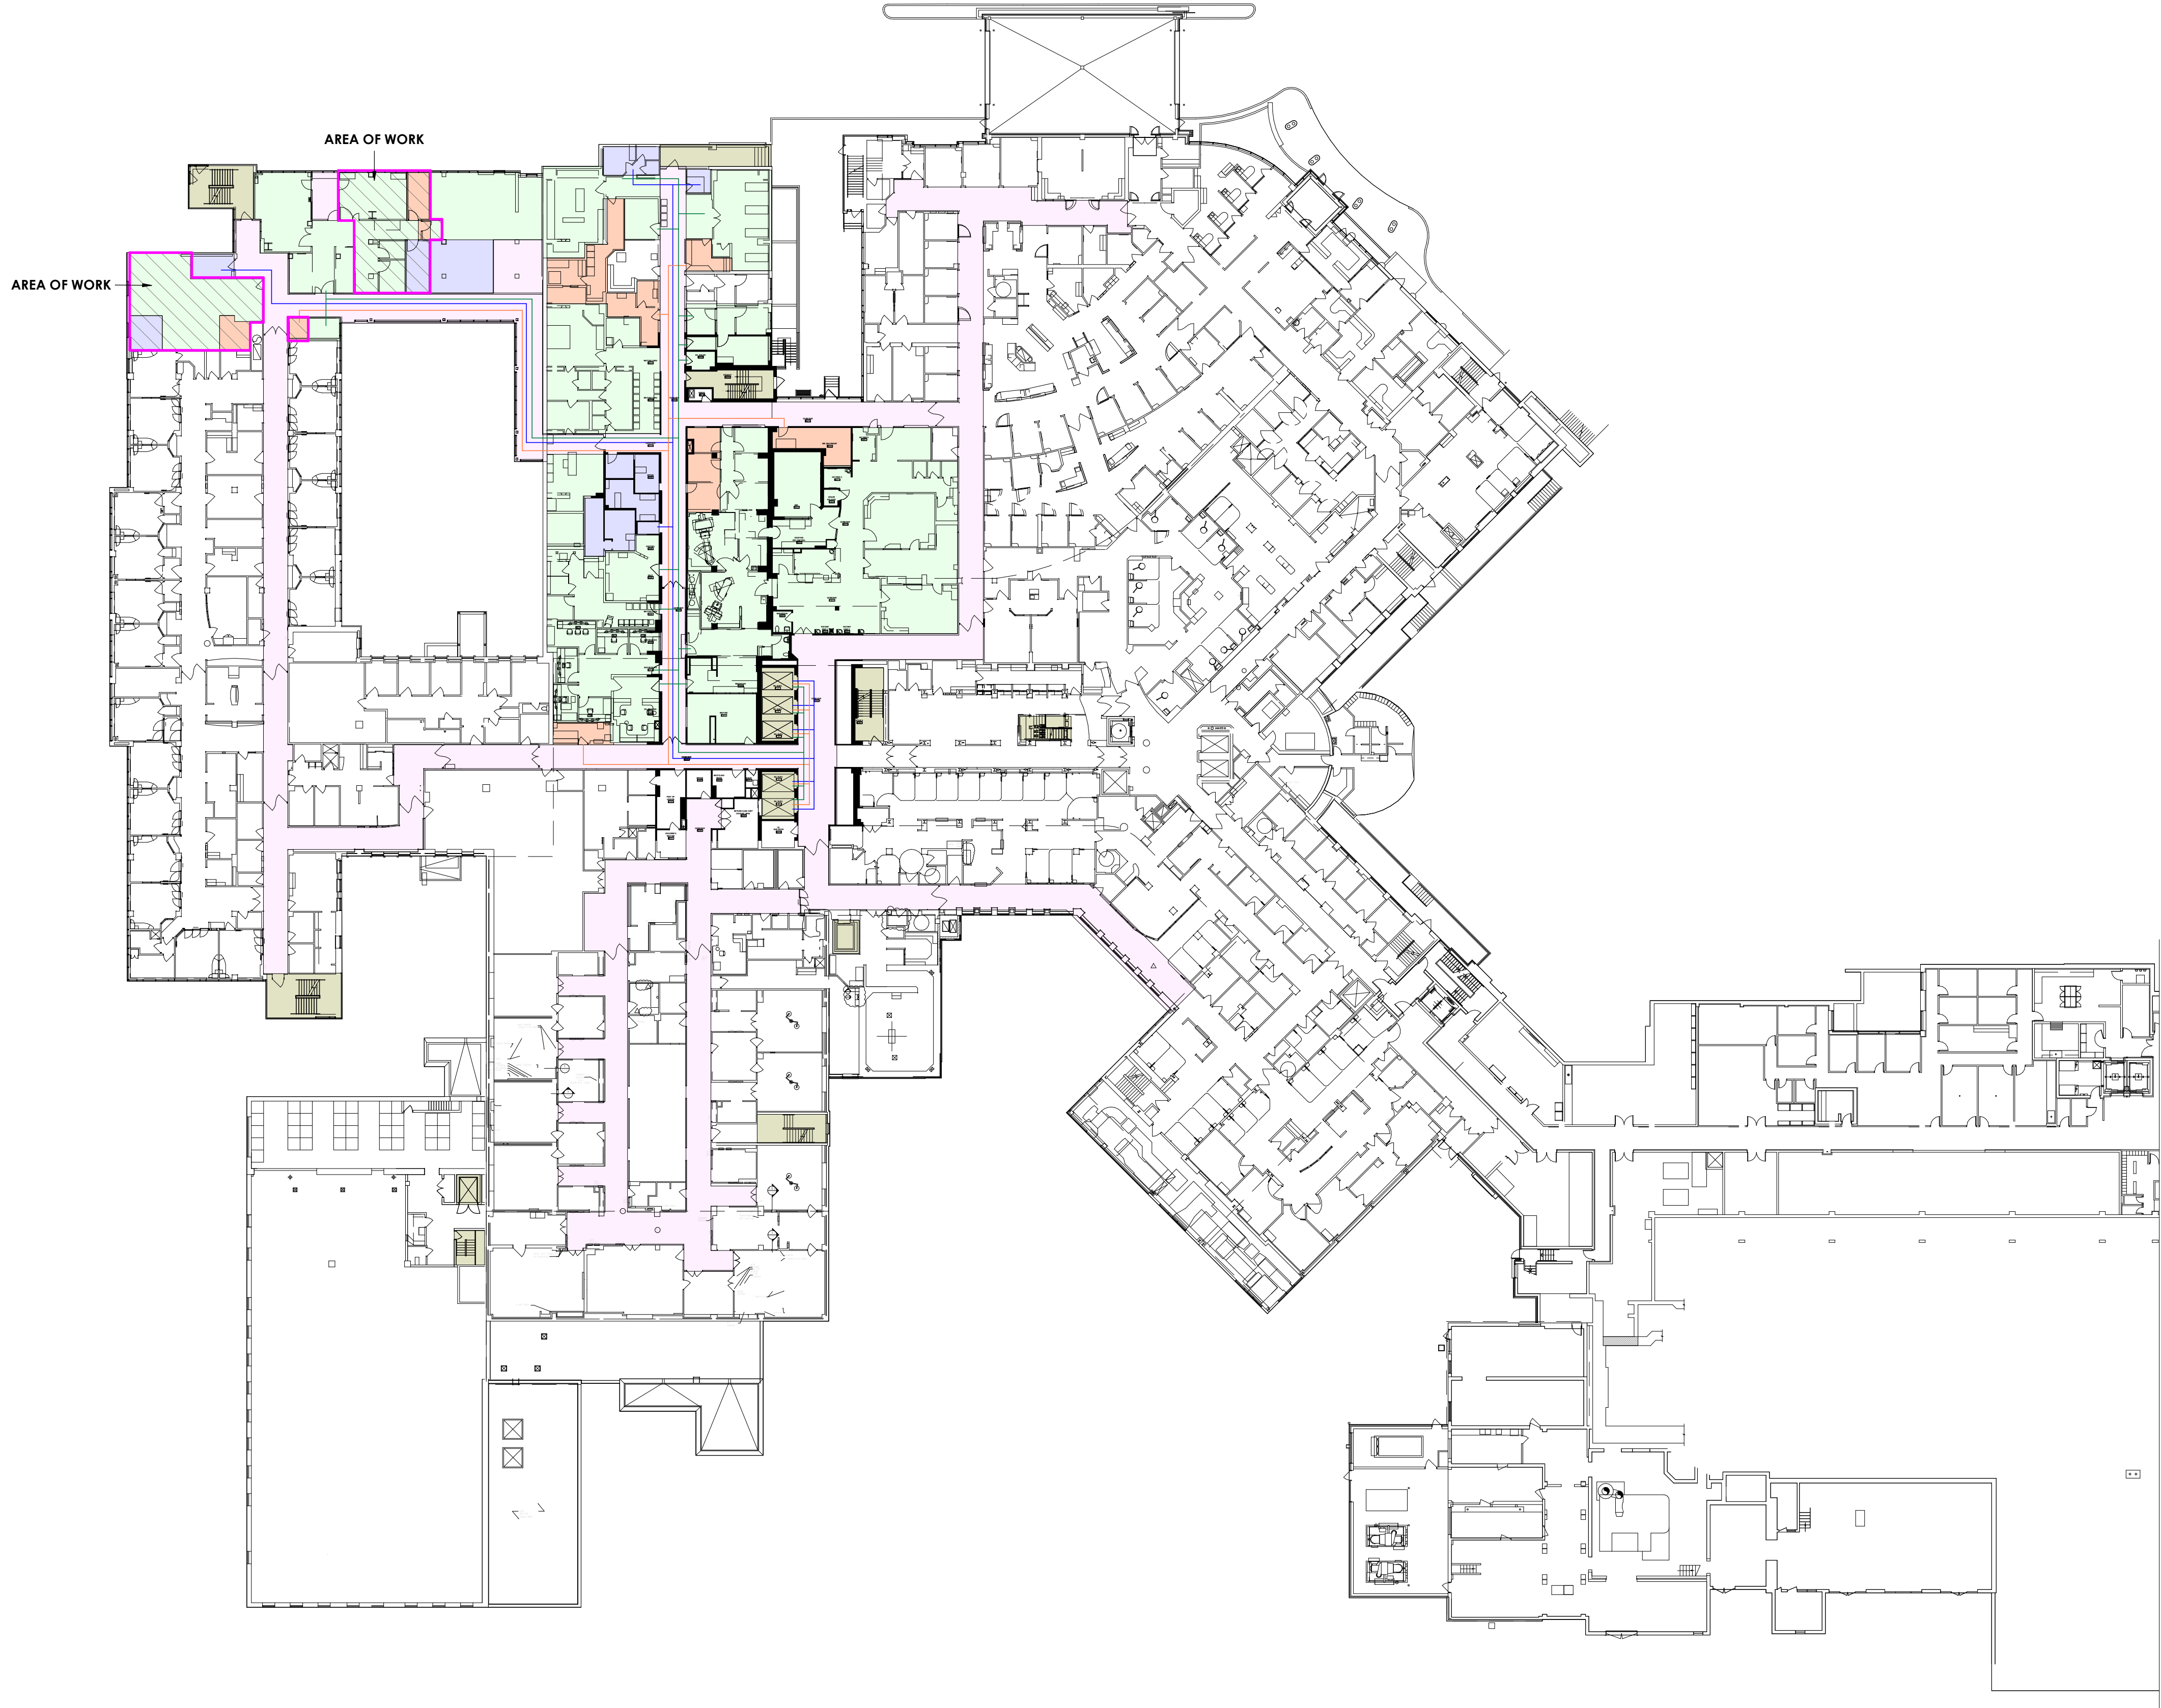

- LEGEND
- CIRCULATION
 - STAFF
 - PATIENT
 - SUPPORT
 - VERTICAL CIRCULATION
 - STAFF CIRCULATION
 - PATIENT CIRCULATION
 - SUPPORT STAFF CIRCULATION
 - AREA OF WORK



PROJECT LOGO

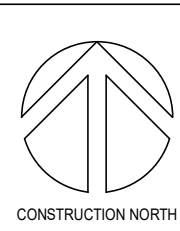

KEY PLAN

ISSUED FOR TENDER
(2026.02.27)

6	ISSUED FOR TENDER	2025.12.12
3	FINAL DESIGN DEVELOPMENT SET	2025.10.31
No.	DESCRIPTION	DATE

REVISIONS: 2025.09.29

DISCREPANCIES MUST BE REPORTED IMMEDIATELY TO THE ARCHITECT / ENGINEER BEFORE PROCEEDING.
ONLY FIGURED DIMENSIONS MUST BE USED.
THE CONTRACTOR MUST CHECK THE DIMENSIONS ON SITE.
THE DRAWING IS PROTECTED BY COPYRIGHT.
ALL DIMENSIONS ARE SHOWN IN MILLIMETERS.
DO NOT SCALE THE DRAWINGS.

McCallumSather
Westinghouse HQ, 2nd Floor
286 Sanford Ave. N
Hamilton, ON L8L 6A1
905.526.6700
www.mccallumsather.com



SEAL

CONSULTANTS:

PROJECT:
**WATERLOO REGIONAL HEALTH
NETWORK @ MIDTOWN - PET CT**


**835 KING ST W, KITCHENER, ON
N2G 1G3**

DRAWING TITLE:
SECOND FLOOR KEY PLAN


DRAWN BY:	SB	DATE:	2025.10.31
CHECKED BY:	MT	SCALE:	1/32" = 1'-0"

PROJECT NO: **24048**

DRAWING NO.: **SK1.5**

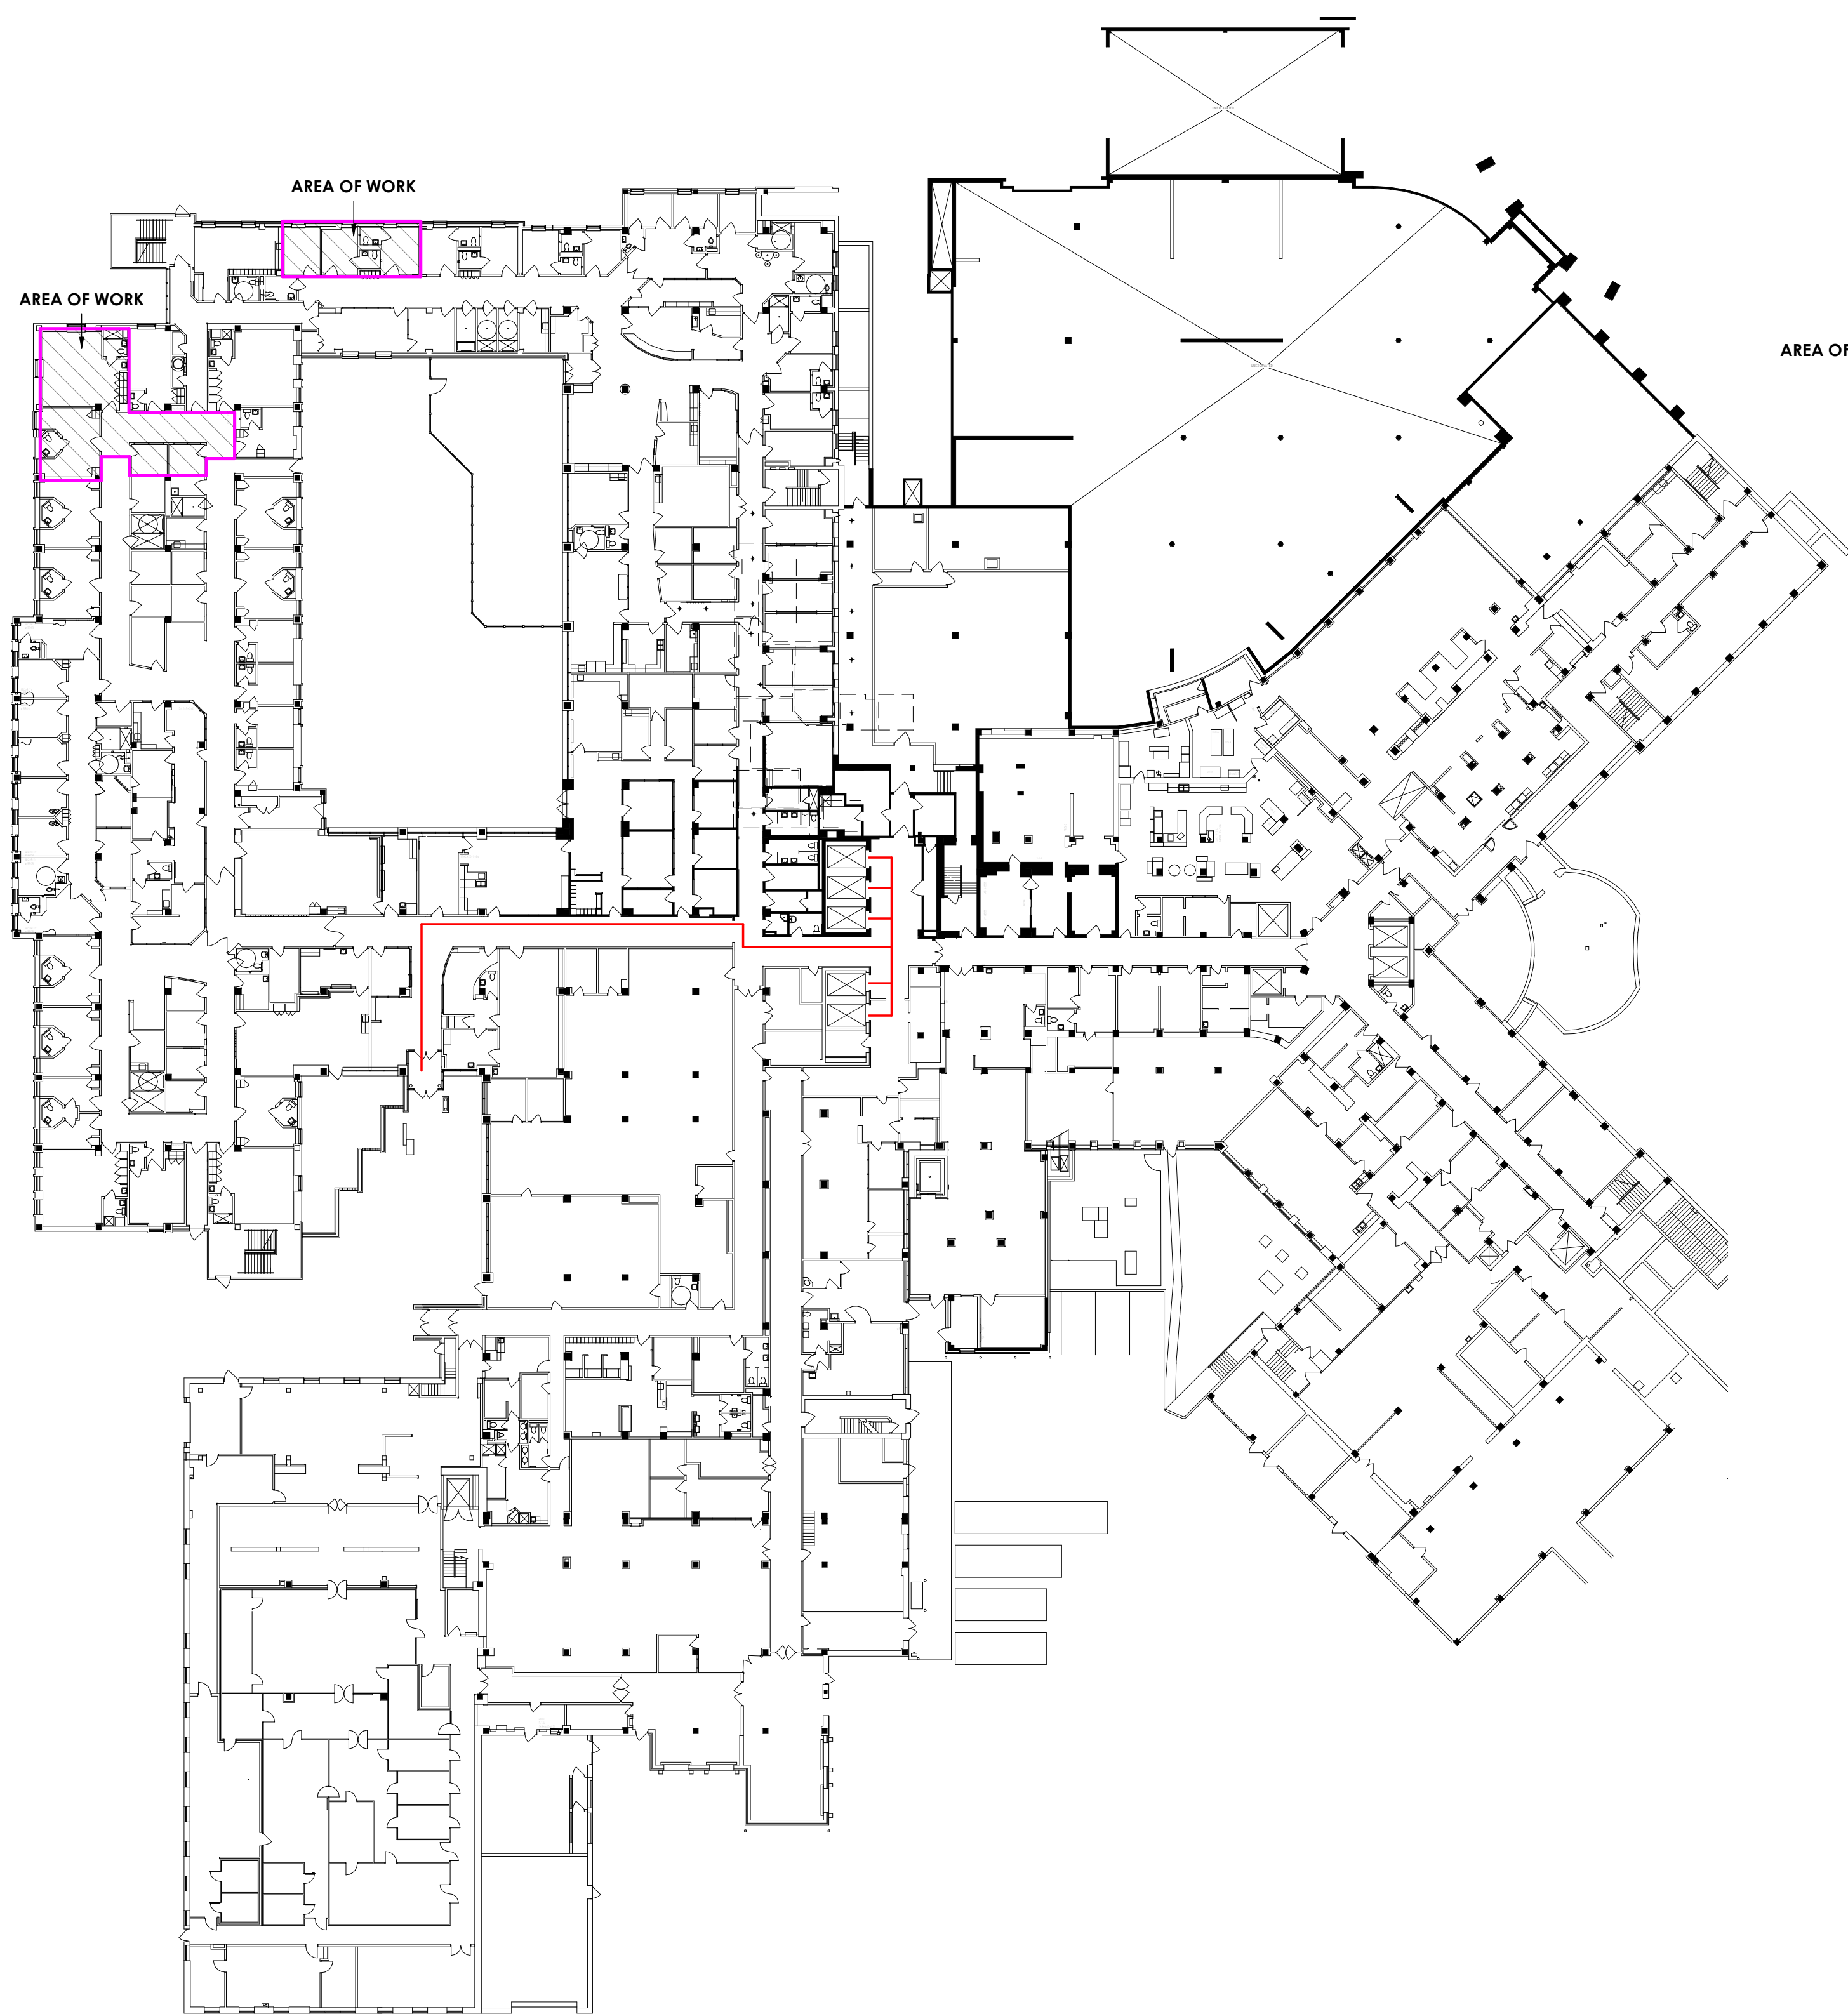

LEVEL 1 - EXISTING OVERALL FLOOR PLAN

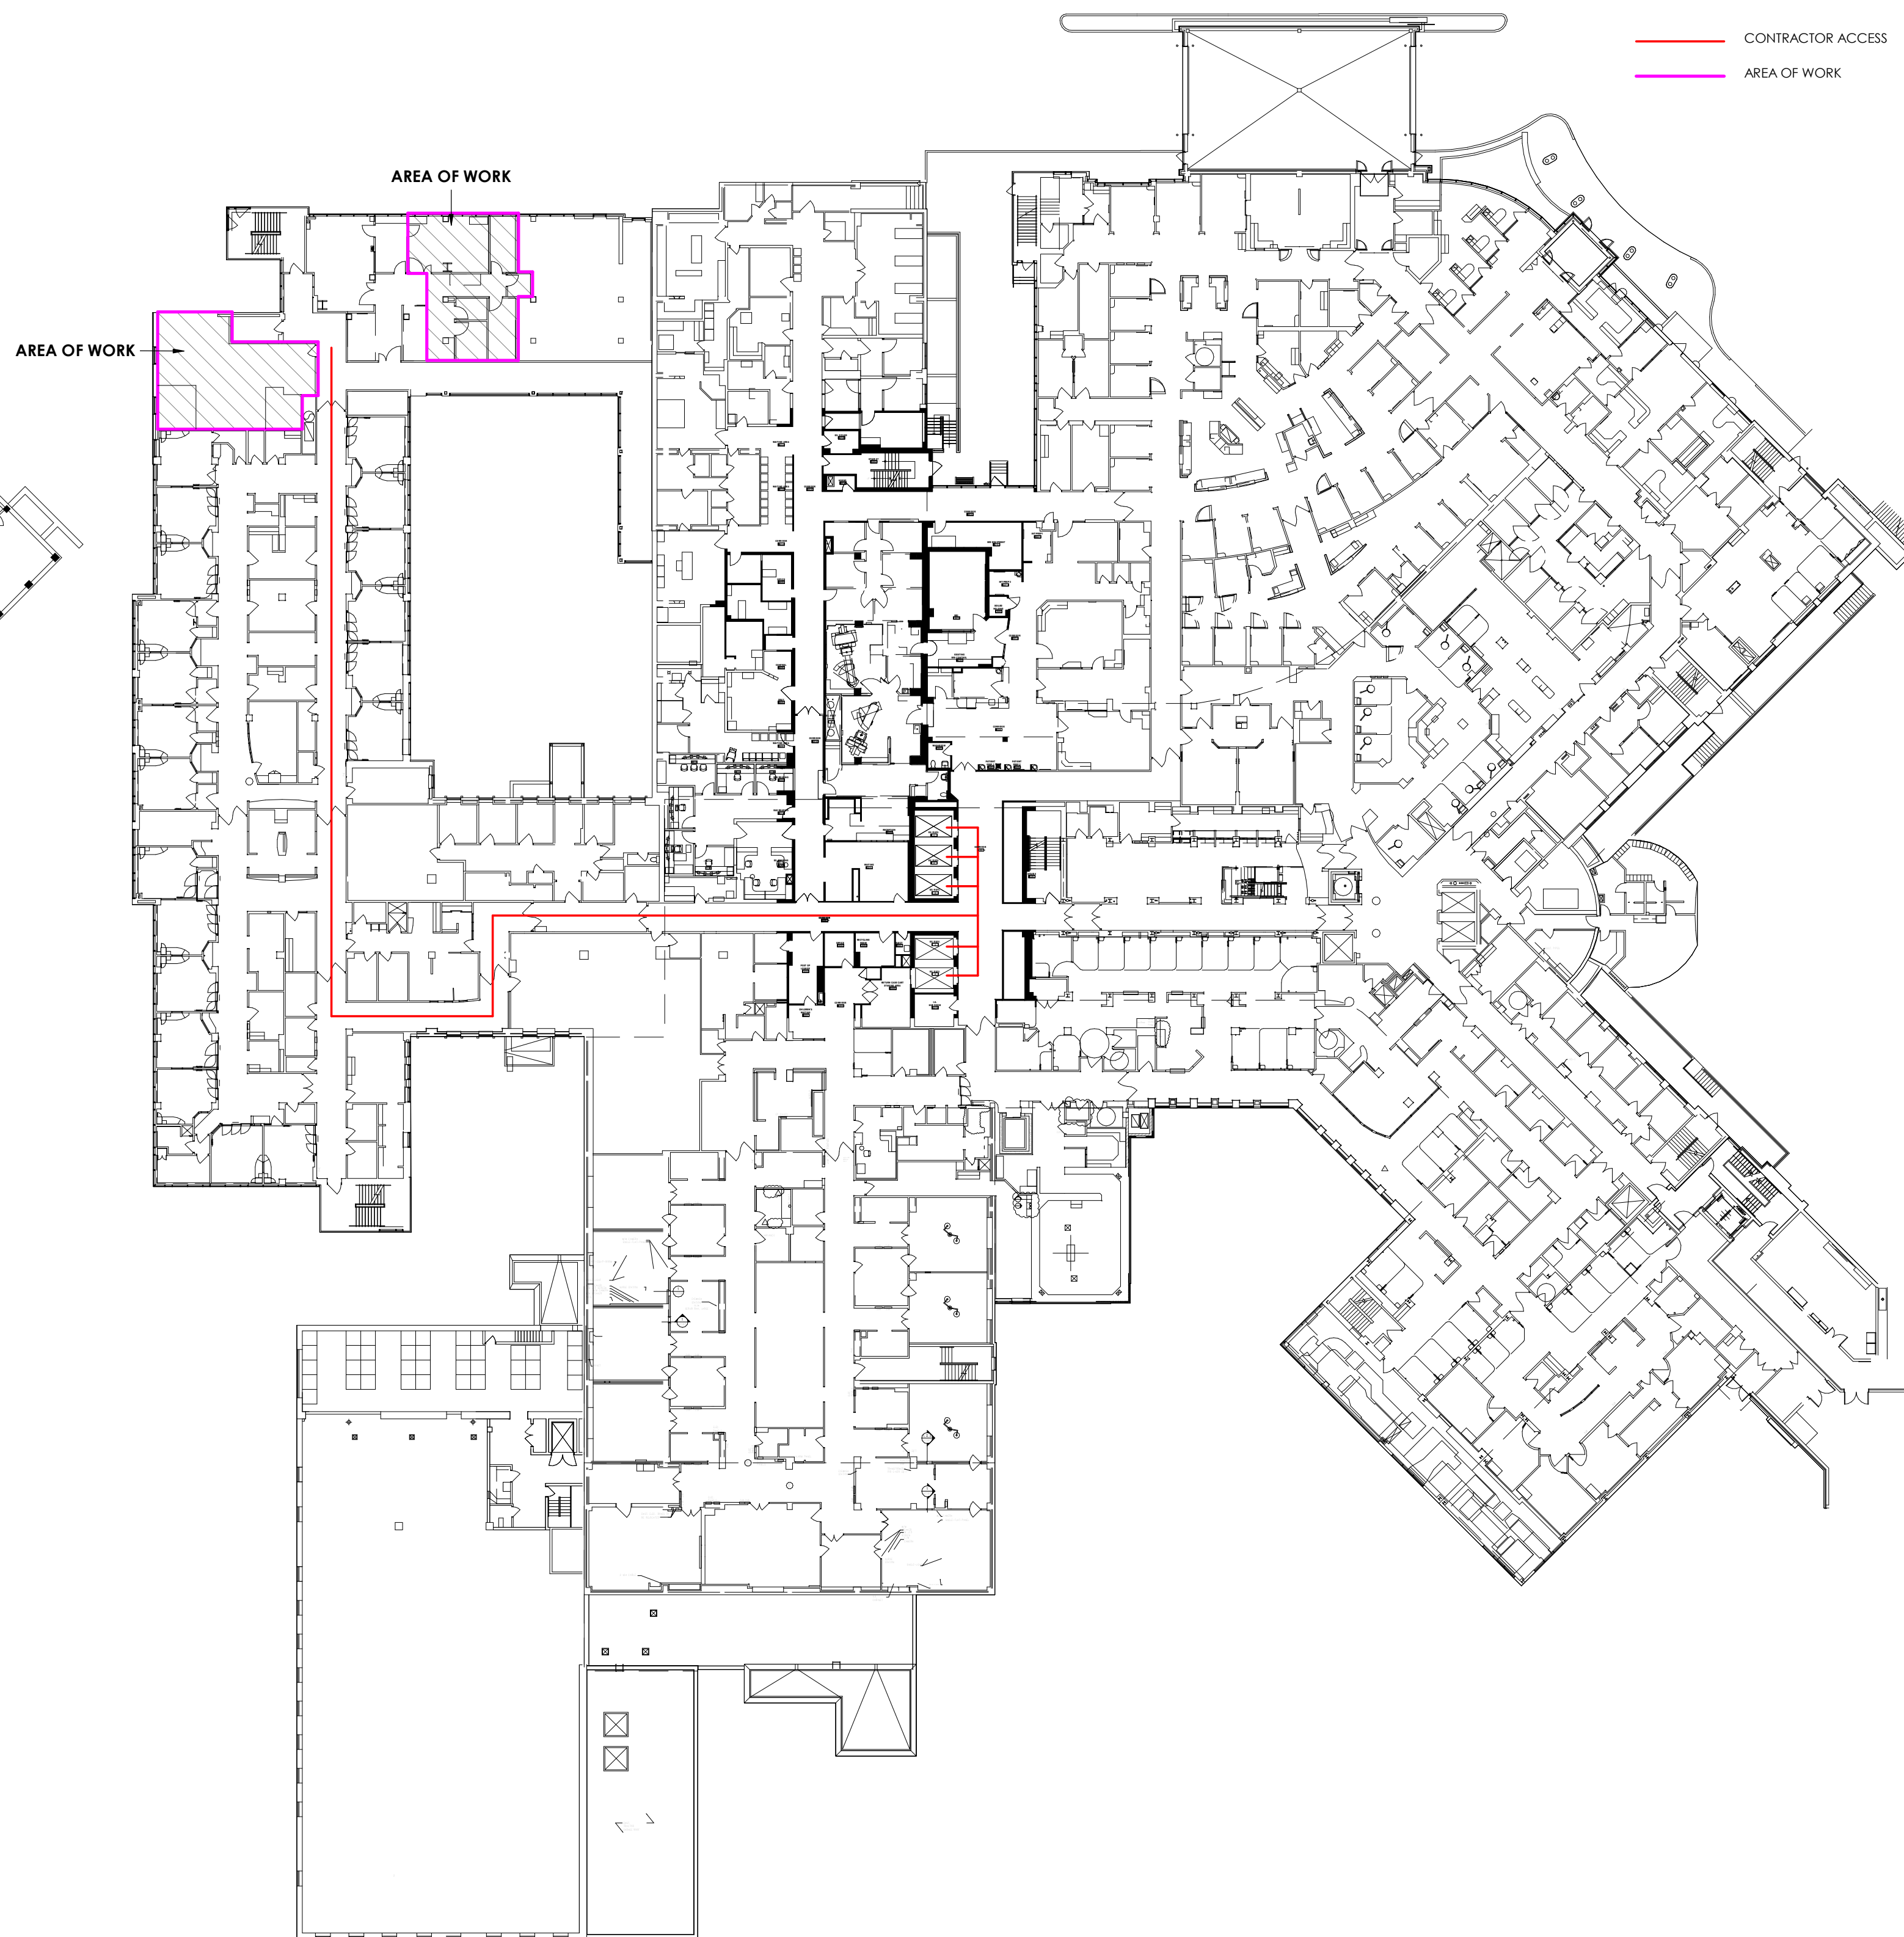

LEVEL 2 - EXISTING OVERALL FLOOR PLAN




WRHN
Waterloo Regional
Health Network

PROJECT LOGO



TRUE NORTH

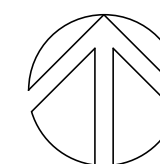

CONSTRUCTION NORTH

KEY PLAN

ISSUED FOR TENDER
(2026.02.27)

6	ISSUED FOR TENDER	2025.12.12
3	FINAL DESIGN DEVELOPMENT SET	2025.10.31
2	DESIGN	DATE

REVISIONS: 2025.09.29

DISCREPANCIES MUST BE REPORTED IMMEDIATELY TO THE ARCHITECT / ENGINEER BEFORE PROCEEDING.
ONLY FIGURED DIMENSIONS MUST BE USED.
THE CONTRACTOR MUST CHECK THE DIMENSIONS ON SITE.
THE DRAWING IS PROTECTED BY COPYRIGHT.
ALL DIMENSIONS ARE SHOWN IN MILLIMETERS.
DO NOT SCALE THE DRAWINGS.

McCallumSather
Westinghouse HQ, 2nd Floor
286 Sanford Ave. N
Hamilton, ON L8L 6A1
905.526.6700
www.mccallumsather.com



ONARIO ASSOCIATION
OF
ARCHITECTS
GREGORY LATIMER
LICENCE
4172

SEAL

CONSULTANTS:

PROJECT:
**WATERLOO REGIONAL HEALTH
NETWORK @ MIDTOWN - PET CT**

**835 KING ST W, KITCHENER, ON
N2G 1G3**

DRAWING TITLE:
CONTRACTOR ACCESS PLAN


DRAWN BY:	SB	DATE:	2025.10.31
CHECKED BY:	MT	SCALE:	1/32" = 1'-0"

PROJECT NO.:
24048

DRAWING NO.:
SK1.7

D 6106/14

PROJECT: 24048 - WATERLOO REGIONAL HEALTH NETWORK @ MIDTOWN - PET CT Stage 2_A_04.rvt
PLOT DATE: 2026-02-13 10:32:26 AM

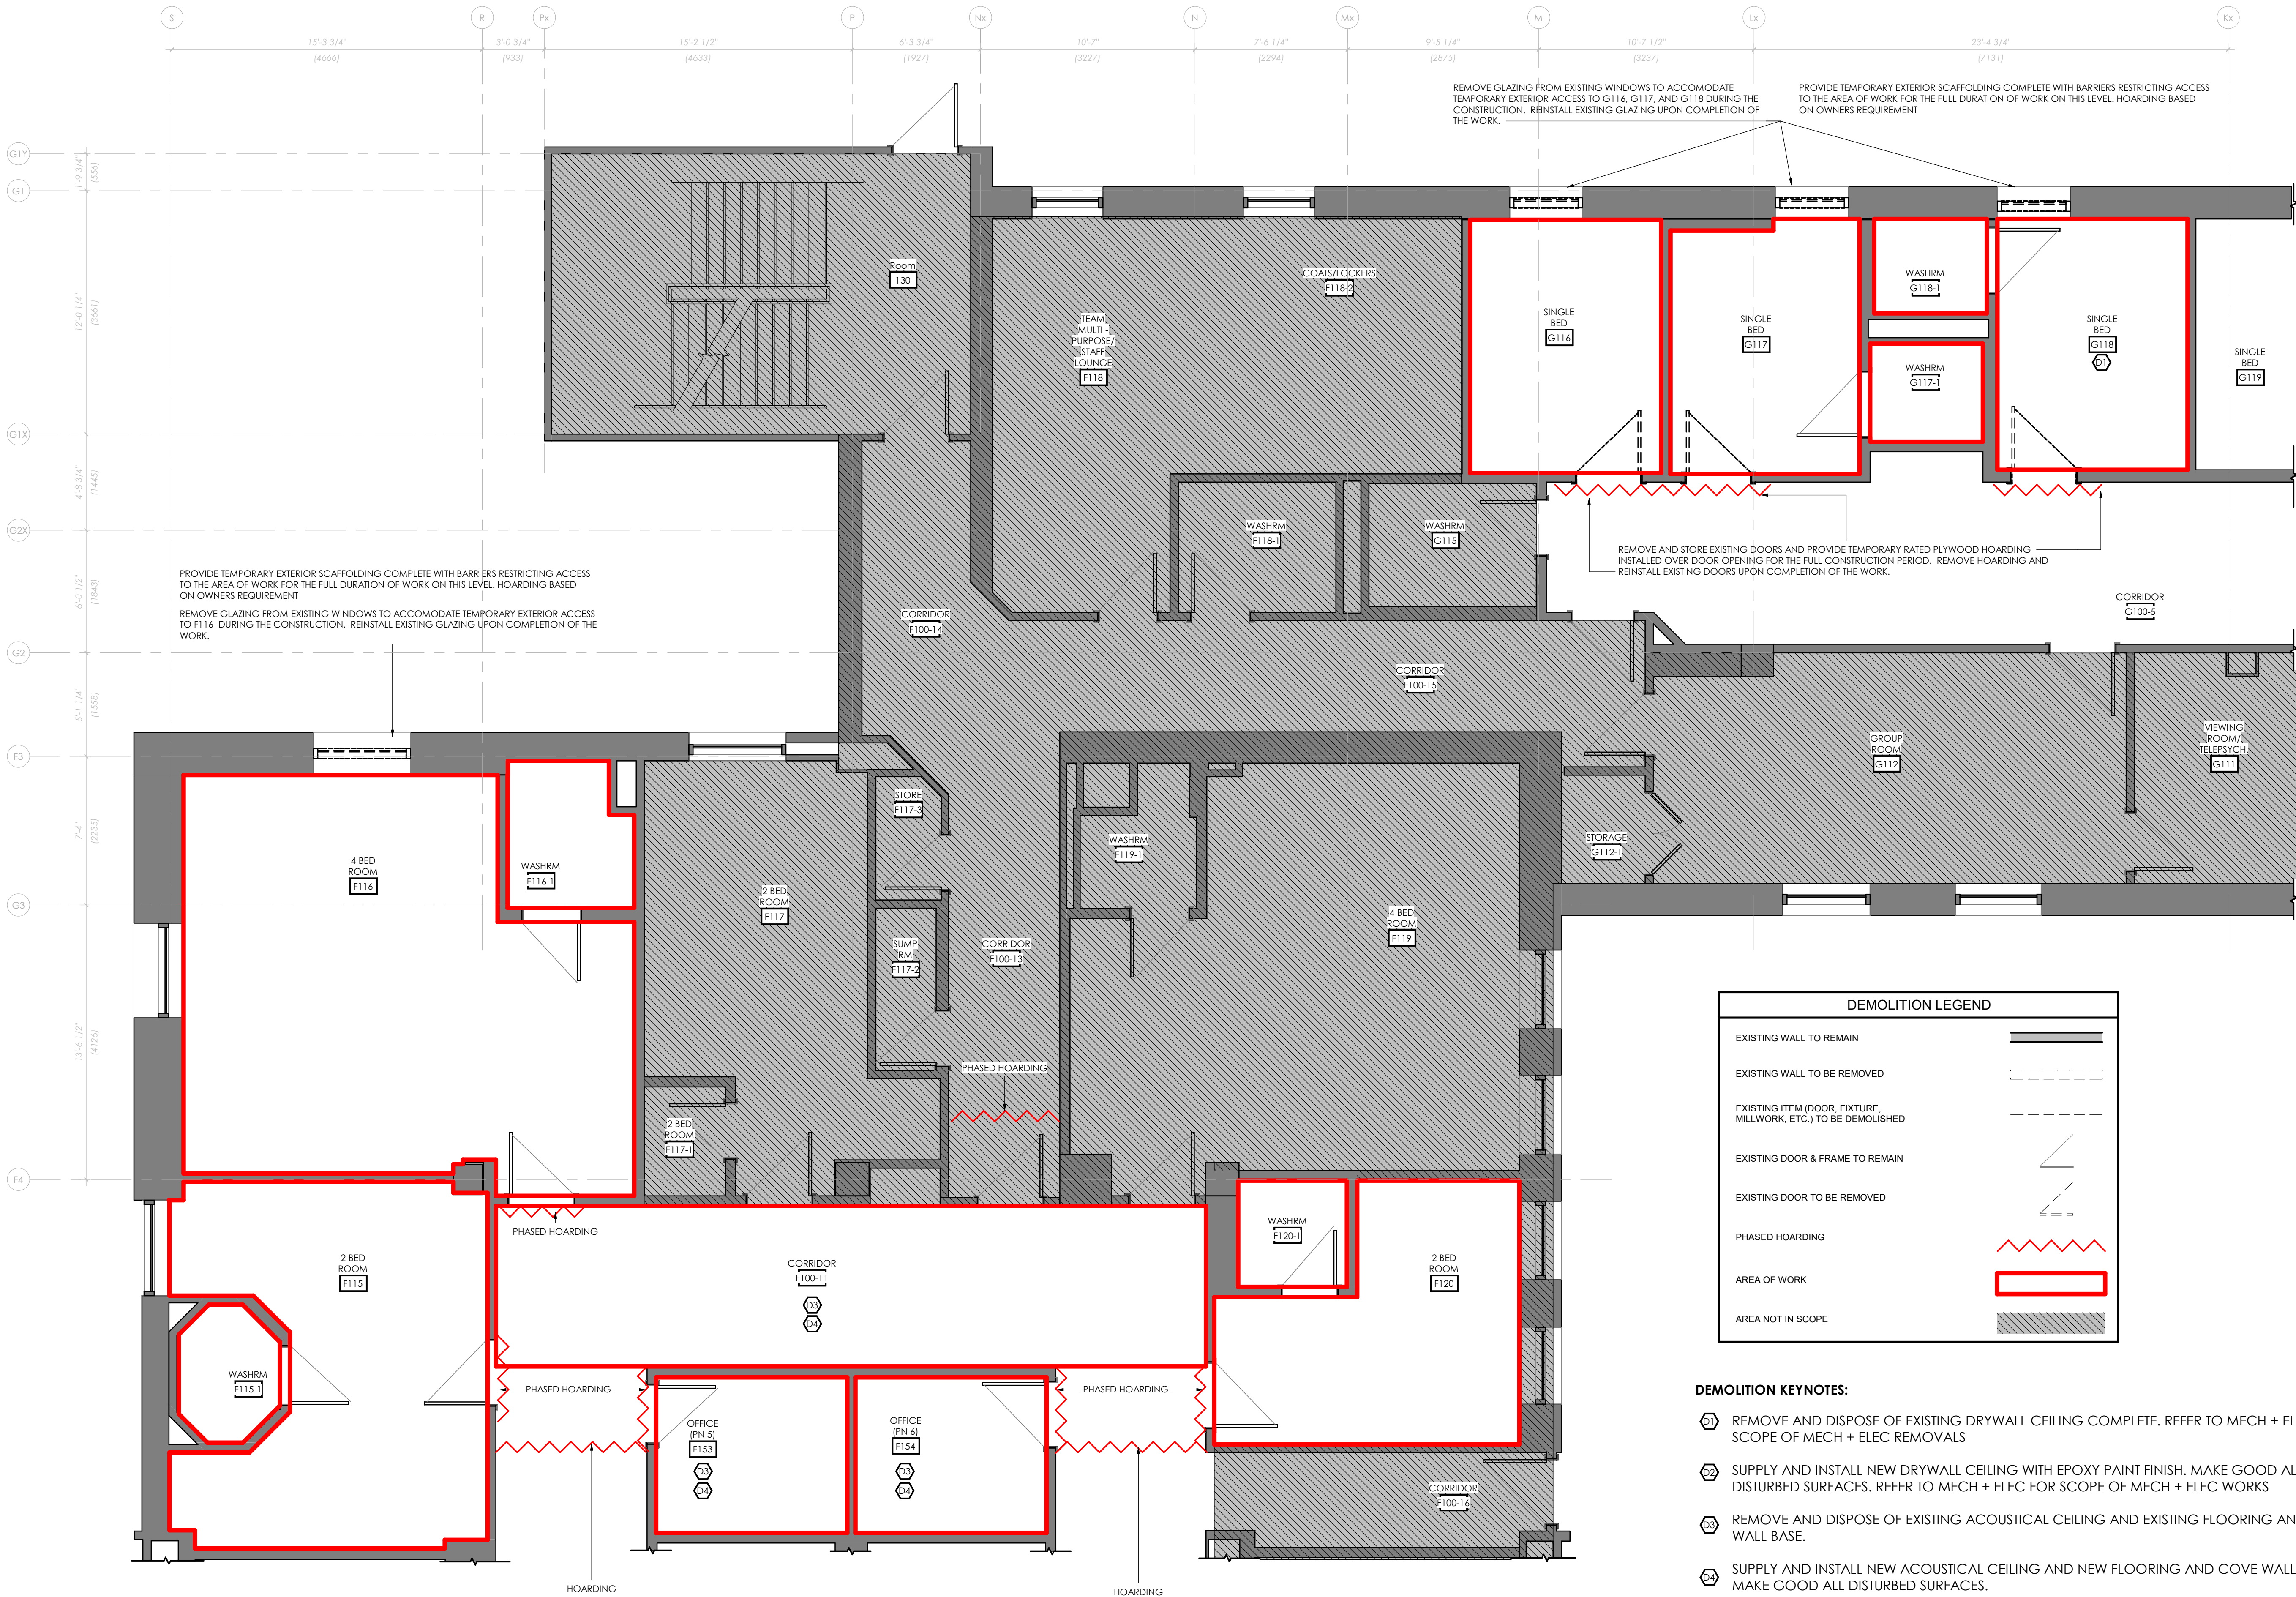



DEMOLITION LEGEND	
EXISTING WALL TO REMAIN	
EXISTING WALL TO BE REMOVED	
EXISTING ITEM (DOOR, FIXTURE, MILLWORK, ETC.) TO BE DEMOLISHED	
EXISTING DOOR & FRAME TO REMAIN	
EXISTING DOOR TO BE REMOVED	
PHASED HOARDING	
AREA OF WORK	
AREA NOT IN SCOPE	

- DEMOLITION KEYNOTES:**
- REMOVE AND DISPOSE OF EXISTING DRYWALL CEILING COMPLETE. REFER TO MECH + ELEC FOR SCOPE OF MECH + ELEC REMOVALS
 - SUPPLY AND INSTALL NEW DRYWALL CEILING WITH EPOXY PAINT FINISH. MAKE GOOD ALL DISTURBED SURFACES. REFER TO MECH + ELEC FOR SCOPE OF MECH + ELEC WORKS
 - REMOVE AND DISPOSE OF EXISTING ACOUSTICAL CEILING AND EXISTING FLOORING AND COVE WALL BASE.
 - SUPPLY AND INSTALL NEW ACOUSTICAL CEILING AND NEW FLOORING AND COVE WALL BASE. MAKE GOOD ALL DISTURBED SURFACES.
 - HSS AND PAPER TOWEL DISPENSER TO REMAIN
 - REMOVE AND DISPOSE - EXISTING SINK, MOP SINK AND EYE WASH STATION

NOTE: HOARDING LAYOUT AND SEQUENCE OF WORK TO BE FINALIZED WITH SELECTED PROPONENT AND ADJUSTMENTS MAY BE MADE TO ACCOMMODATE HOSPITAL OPERATIONS



PROJECT LOGO

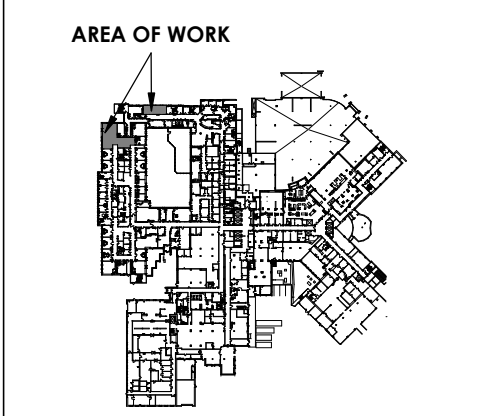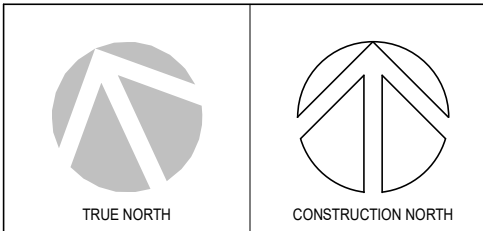

KEY PLAN

ISSUED FOR TENDER
(2026.02.27)

No.	DESCRIPTION	DATE
1	50% DESIGN DEVELOPMENT PROGRESS SET	2025.05.09
2	100% DESIGN DEVELOPMENT PROGRESS SET	2025.09.29
3	FINAL DESIGN DEVELOPMENT SET	2025.10.31
4	FINAL DESIGN DEVELOPMENT SET	2025.11.07
5	ISSUED FOR PERMIT	2025.11.28
6	ISSUED FOR TENDER	2025.12.12
7	RE- ISSUED FOR PERMIT	2026.02.25
8	ISSUED FOR TENDER	2026.02.27

DISCREPANCIES MUST BE REPORTED IMMEDIATELY TO THE ARCHITECT / ENGINEER BEFORE PROCEEDING.
ONLY FIGURED DIMENSIONS MUST BE USED.
THE CONTRACTOR MUST CHECK THE DIMENSIONS ON SITE.
THE DRAWING IS PROTECTED BY COPYRIGHT.
ALL DIMENSIONS ARE SHOWN IN MILLIMETERS.
DO NOT SCALE THE DRAWINGS.

mcCallumSather
Westinghouse HQ, 2nd Floor
286 Sanford Ave. N
Hamilton, ON L8L 6A1
905.526.6700
www.mccallumsather.com



SEAL

CONSULTANTS:

PROJECT:
WATERLOO REGIONAL HEALTH NETWORK @ MIDTOWN - PET CT


835 KING ST W, KITCHENER, ON N2G 1G3

DRAWING TITLE:
DEMOLITION L1 ENLARGED FLOOR PLAN

DRAWN BY: SB DATE: 2025.10.31
CHECKED BY: GL SCALE: 1/4" = 1'-0"

PROJECT NO. **24048**

DRAWING NO. **D1.1**

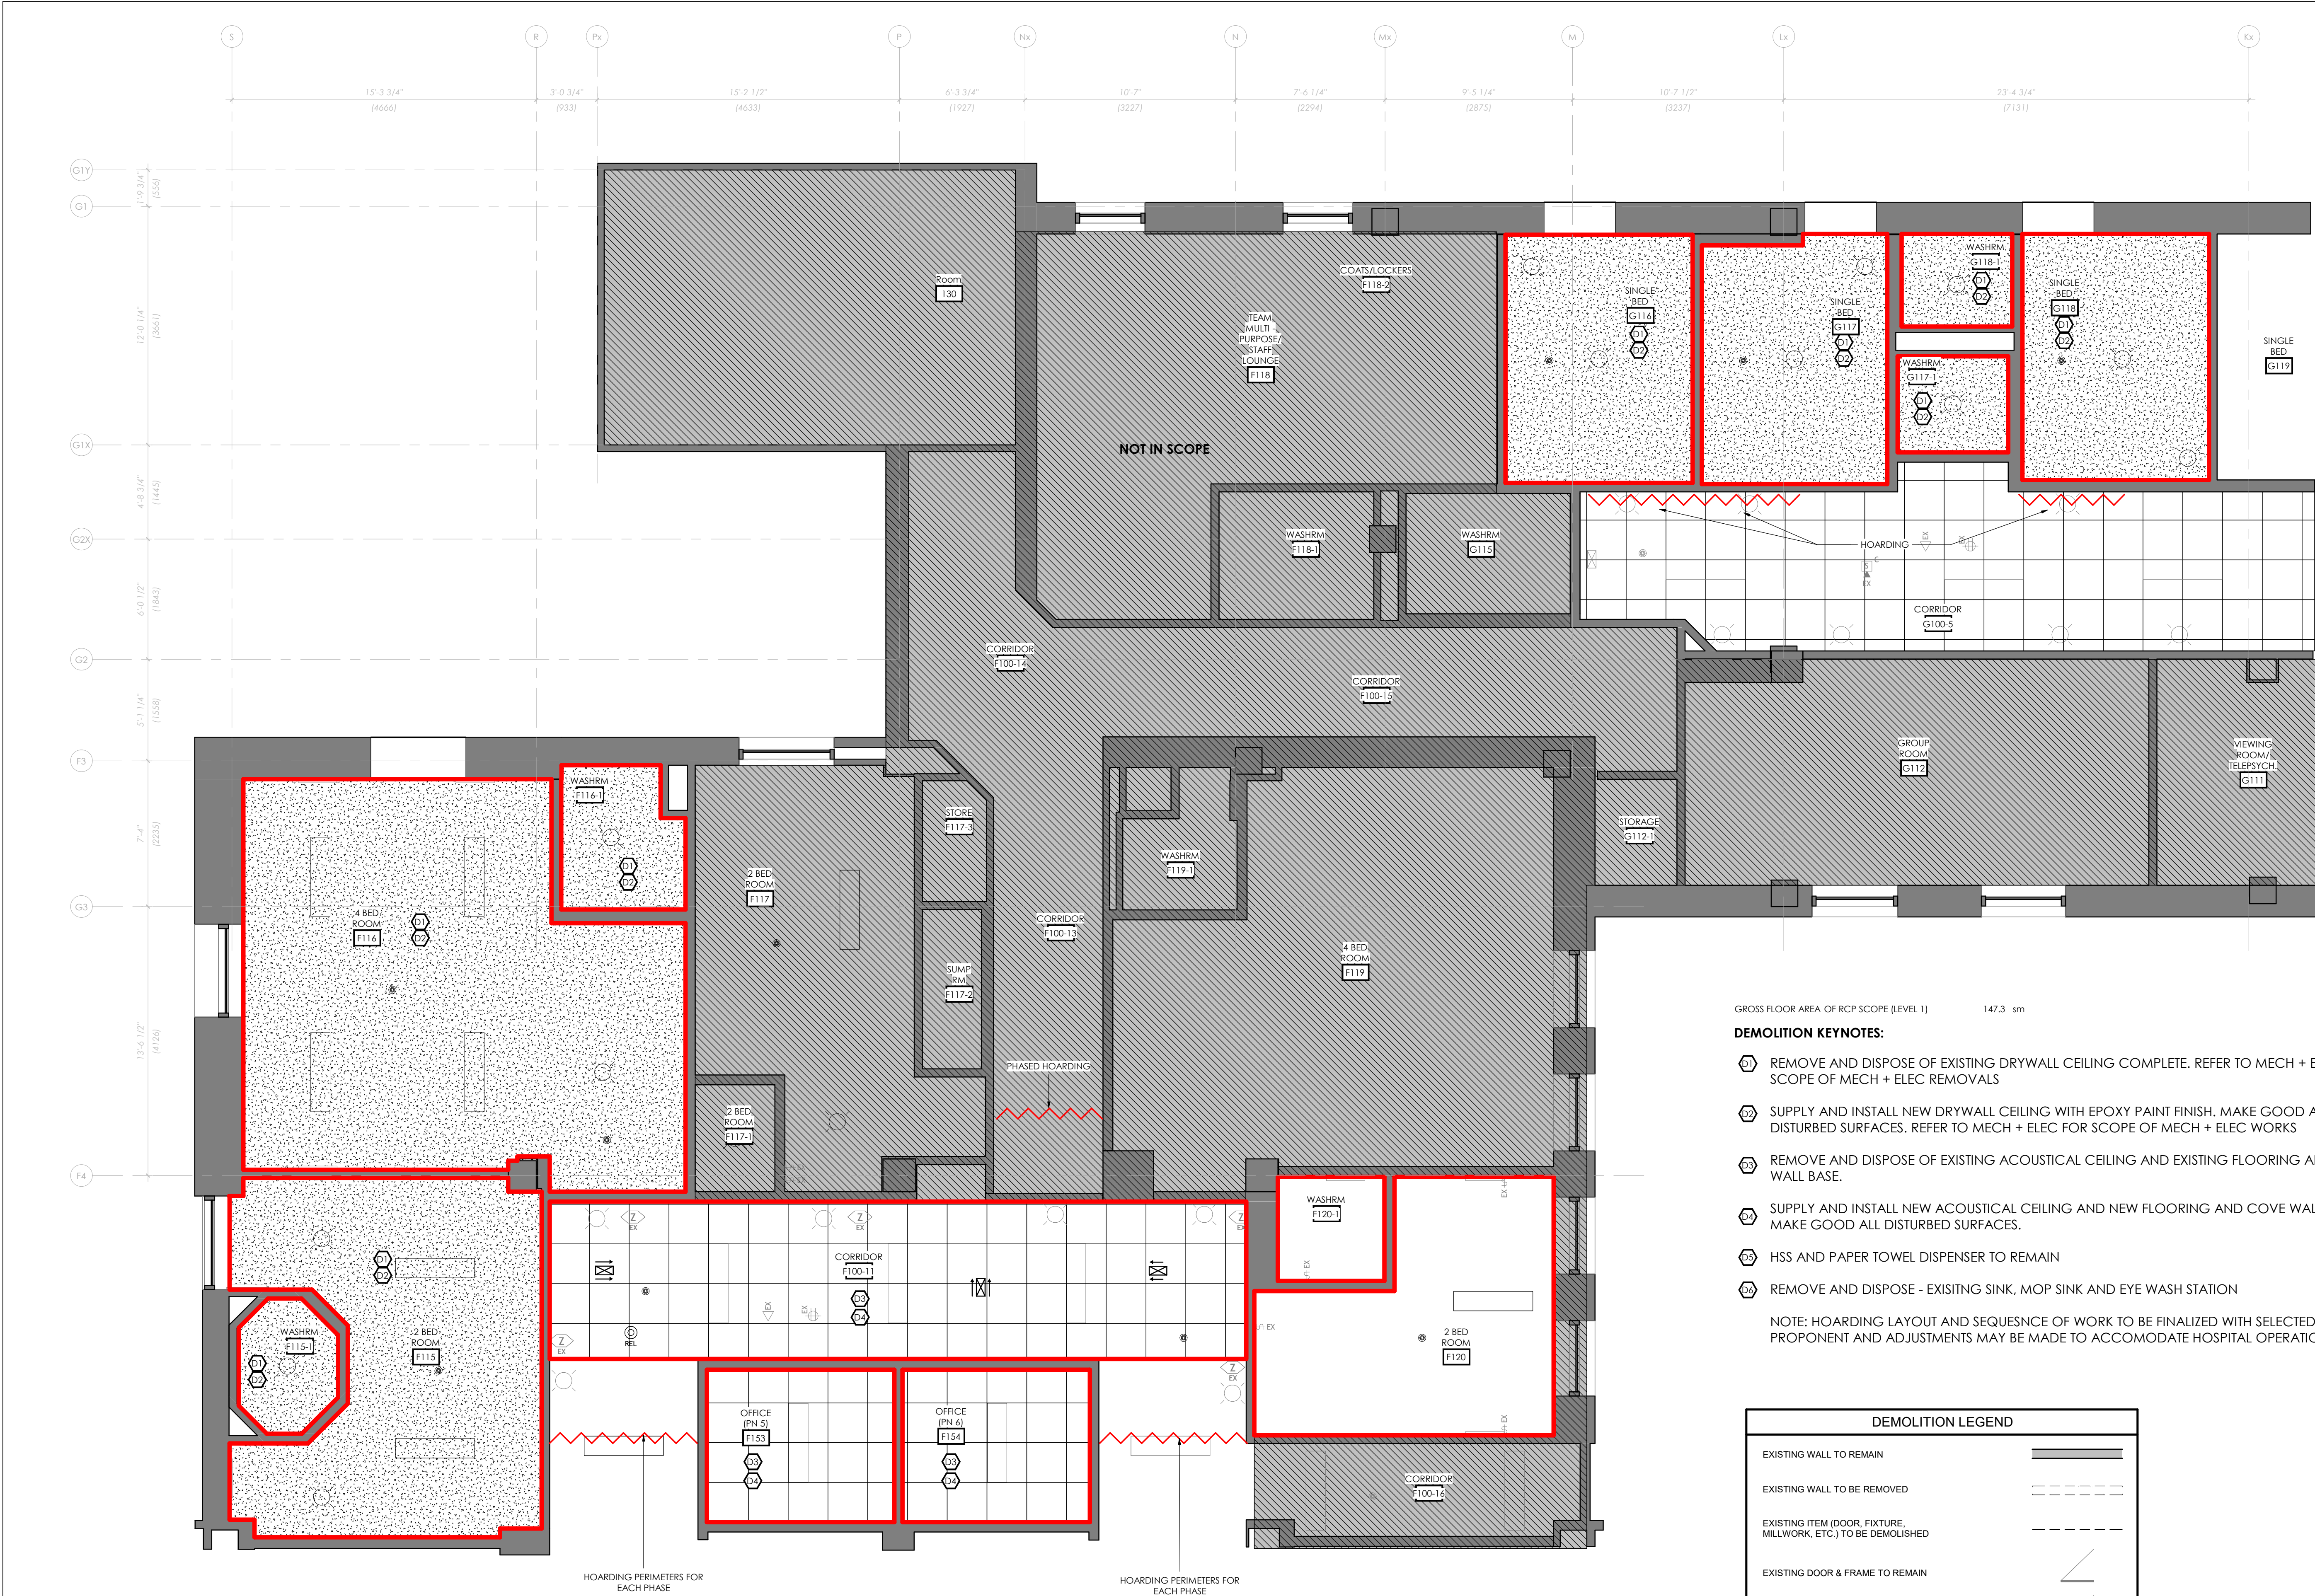

HOARDING PERIMETERS FOR EACH PHASE

HOARDING PERIMETERS FOR EACH PHASE


GROSS FLOOR AREA OF RCP SCOPE (LEVEL 1) 147.3 sm

DEMOLITION KEYNOTES:

- 17 REMOVE AND DISPOSE OF EXISTING DRYWALL CEILING COMPLETE. REFER TO MECH + ELEC FOR SCOPE OF MECH + ELEC REMOVALS
- 27 SUPPLY AND INSTALL NEW DRYWALL CEILING WITH EPOXY PAINT FINISH. MAKE GOOD ALL DISTURBED SURFACES. REFER TO MECH + ELEC FOR SCOPE OF MECH + ELEC WORKS
- 23 REMOVE AND DISPOSE OF EXISTING ACOUSTICAL CEILING AND EXISTING FLOORING AND COVE WALL BASE.
- 24 SUPPLY AND INSTALL NEW ACOUSTICAL CEILING AND NEW FLOORING AND COVE WALL BASE. MAKE GOOD ALL DISTURBED SURFACES.
- 25 HSS AND PAPER TOWEL DISPENSER TO REMAIN
- 26 REMOVE AND DISPOSE - EXISTING SINK, MOP SINK AND EYE WASH STATION

NOTE: HOARDING LAYOUT AND SEQUENCE OF WORK TO BE FINALIZED WITH SELECTED PROPONENT AND ADJUSTMENTS MAY BE MADE TO ACCOMMODATE HOSPITAL OPERATIONS

DEMOLITION LEGEND	
EXISTING WALL TO REMAIN	
EXISTING WALL TO BE REMOVED	
EXISTING ITEM (DOOR, FIXTURE, MILLWORK, ETC.) TO BE DEMOLISHED	
EXISTING DOOR & FRAME TO REMAIN	
EXISTING DOOR TO BE REMOVED	
PHASED HOARDING	
AREA OF WORK	
AREA NOT IN SCOPE	

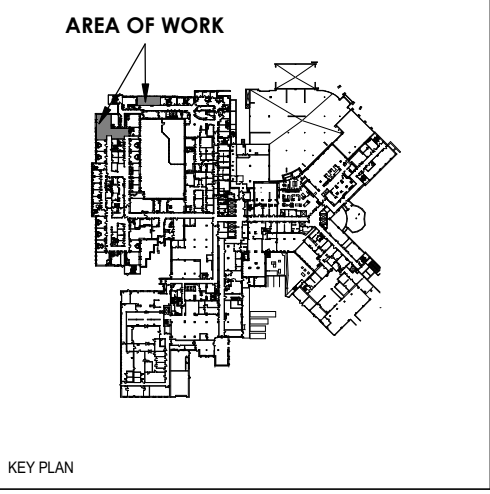

ISSUED FOR TENDER (2026.02.27)		
8	ISSUED FOR TENDER	2026-02-27
7	RE- ISSUED FOR PERMIT	2026-02-25
6	ISSUED FOR TENDER	2025-12-12
5	ISSUED FOR PERMIT	2025-11-28
4	FINAL DESIGN DEVELOPMENT SET	2025-11-07
3	FINAL DESIGN DEVELOPMENT SET	2025-10-31
2	100% DESIGN DEVELOPMENT PROGRESS SET	2025-09-29
1	50% DESIGN DEVELOPMENT PROGRESS SET	2025-05-09
No.	DESCRIPTION	DATE
REVISIONS: 2025-09-29		

DISCREPANCIES MUST BE REPORTED IMMEDIATELY TO THE ARCHITECT / ENGINEER BEFORE PROCEEDING.
ONLY FIGURED DIMENSIONS MUST BE USED.
THE CONTRACTOR MUST CHECK THE DIMENSIONS ON SITE.
THE DRAWING IS PROTECTED BY COPYRIGHT.
ALL DIMENSIONS ARE SHOWN IN MILLIMETERS.
DO NOT SCALE THE DRAWINGS.

McCallumSather
Westinghouse HQ, 2nd Floor
286 Sanford Ave. N
Hamilton, ON L8L 6A1
905.526.6700
www.mccallumsather.com



CONSULTANTS:

PROJECT:
WATERLOO REGIONAL HEALTH NETWORK @ MIDTOWN - PET CT


835 KING ST W, KITCHENER, ON N2G 1G3

DRAWING TITLE:
DEMOLITION L1 ENLARGED REFLECTED CEILING PLAN

DRAWN BY: SB DATE: 2025.10.31
CHECKED BY: GL SCALE: 1/4" = 1'-0"

PROJECT NO: 24048

DRAWING NO.: **D1.2**

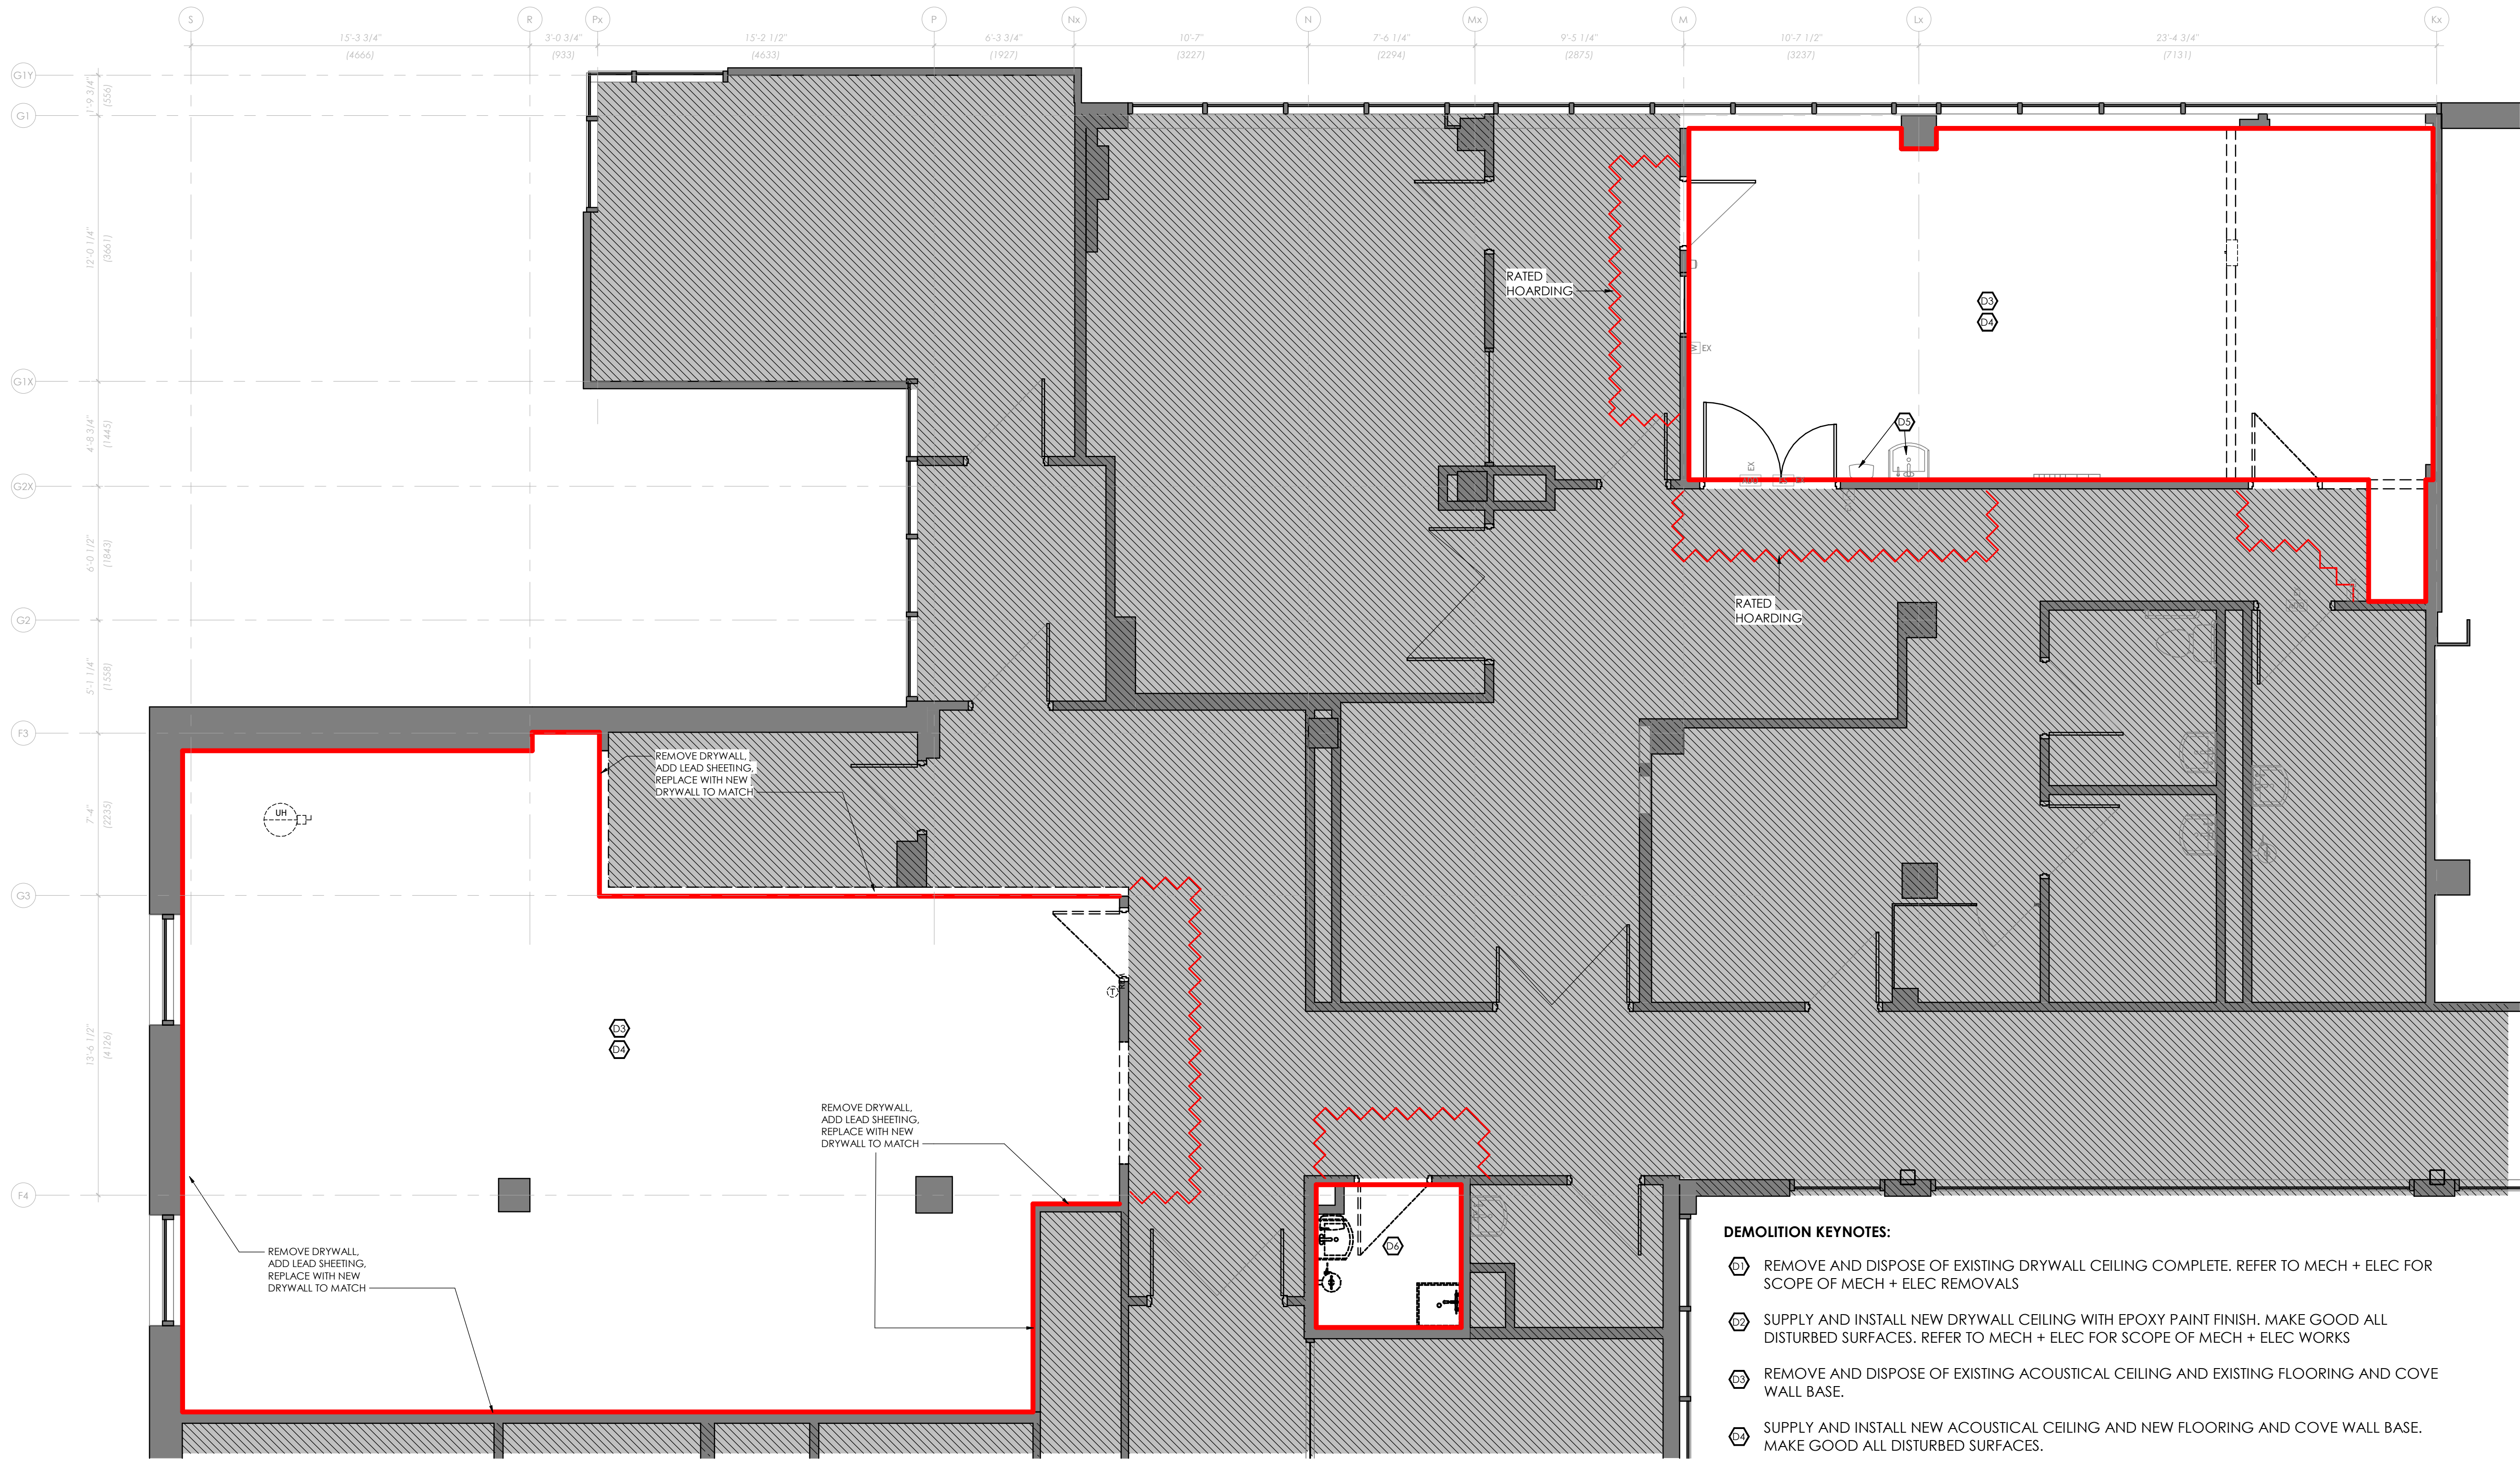



- DEMOLITION KEYNOTES:**
- ① REMOVE AND DISPOSE OF EXISTING DRYWALL CEILING COMPLETE. REFER TO MECH + ELEC FOR SCOPE OF MECH + ELEC REMOVALS
 - ② SUPPLY AND INSTALL NEW DRYWALL CEILING WITH EPOXY PAINT FINISH. MAKE GOOD ALL DISTURBED SURFACES. REFER TO MECH + ELEC FOR SCOPE OF MECH + ELEC WORKS
 - ③ REMOVE AND DISPOSE OF EXISTING ACOUSTICAL CEILING AND EXISTING FLOORING AND COVE WALL BASE.
 - ④ SUPPLY AND INSTALL NEW ACOUSTICAL CEILING AND NEW FLOORING AND COVE WALL BASE. MAKE GOOD ALL DISTURBED SURFACES.
 - ⑤ HSS AND PAPER TOWEL DISPENSER TO REMAIN
 - ⑥ REMOVE AND DISPOSE - EXISTING SINK, MOP SINK AND EYE WASH STATION

NOTE: HOARDING LAYOUT AND SEQUENCE OF WORK TO BE FINALIZED WITH SELECTED PROPONENT AND ADJUSTMENTS MAY BE MADE TO ACCOMMODATE HOSPITAL OPERATIONS

DEMOLITION LEGEND	
EXISTING WALL TO REMAIN	
EXISTING WALL TO BE REMOVED	
EXISTING ITEM (DOOR, FIXTURE, MILLWORK, ETC.) TO BE DEMOLISHED	
EXISTING DOOR & FRAME TO REMAIN	
EXISTING DOOR TO BE REMOVED	
PHASED HOARDING	
AREA OF WORK	
AREA NOT IN SCOPE	



PROJECT LOGO

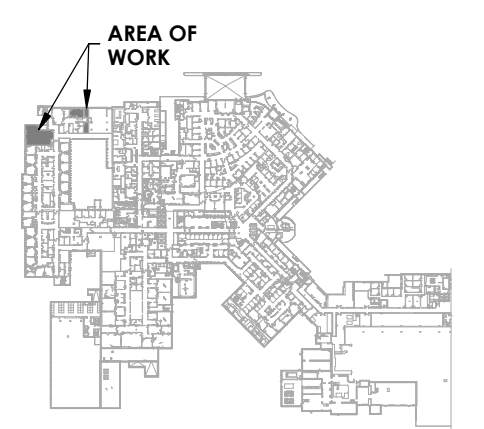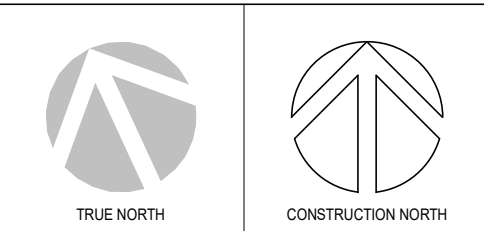

KEY PLAN

ISSUED FOR TENDER
(2026.02.27)

8	ISSUED FOR TENDER	2026-02-27
7	RE- ISSUED FOR PERMIT	2026-02-25
6	ISSUED FOR TENDER	2025-12-12
5	ISSUED FOR PERMIT	2025-11-28
4	FINAL DESIGN DEVELOPMENT SET	2025-11-07
3	FINAL DESIGN DEVELOPMENT SET	2025-10-31
2	100% DESIGN DEVELOPMENT PROGRESS SET	2025-09-29
1	50% DESIGN DEVELOPMENT PROGRESS SET	2025-05-09
No.	DESCRIPTION	DATE

REVISIONS: 2025.09.29

DISCREPANCIES MUST BE REPORTED IMMEDIATELY TO THE ARCHITECT / ENGINEER BEFORE PROCEEDING.
ONLY FIGURED DIMENSIONS MUST BE USED.
THE CONTRACTOR MUST CHECK THE DIMENSIONS ON SITE.
THE DRAWING IS PROTECTED BY COPYRIGHT.
ALL DIMENSIONS ARE SHOWN IN MILLIMETERS.
DO NOT SCALE THE DRAWINGS.

mcCallumSather
Westinghouse HQ, 2nd Floor
286 Sanford Ave. N
Hamilton, ON L8L 6A1
905.526.6700
www.mccallumsather.com



SEAL

CONSULTANTS:

PROJECT:
WATERLOO REGIONAL HEALTH NETWORK @ MIDTOWN - PET CT


835 KING ST W, KITCHENER, ON N2G 1G3

DRAWING TITLE:
DEMOLITION L2 ENLARGED FLOOR PLAN

DRAWN BY: SB DATE: 10/08/25
CHECKED BY: GL SCALE: 1/4" = 1'-0"

PROJECT NO: **24048**

DRAWING NO.: **D1.3**

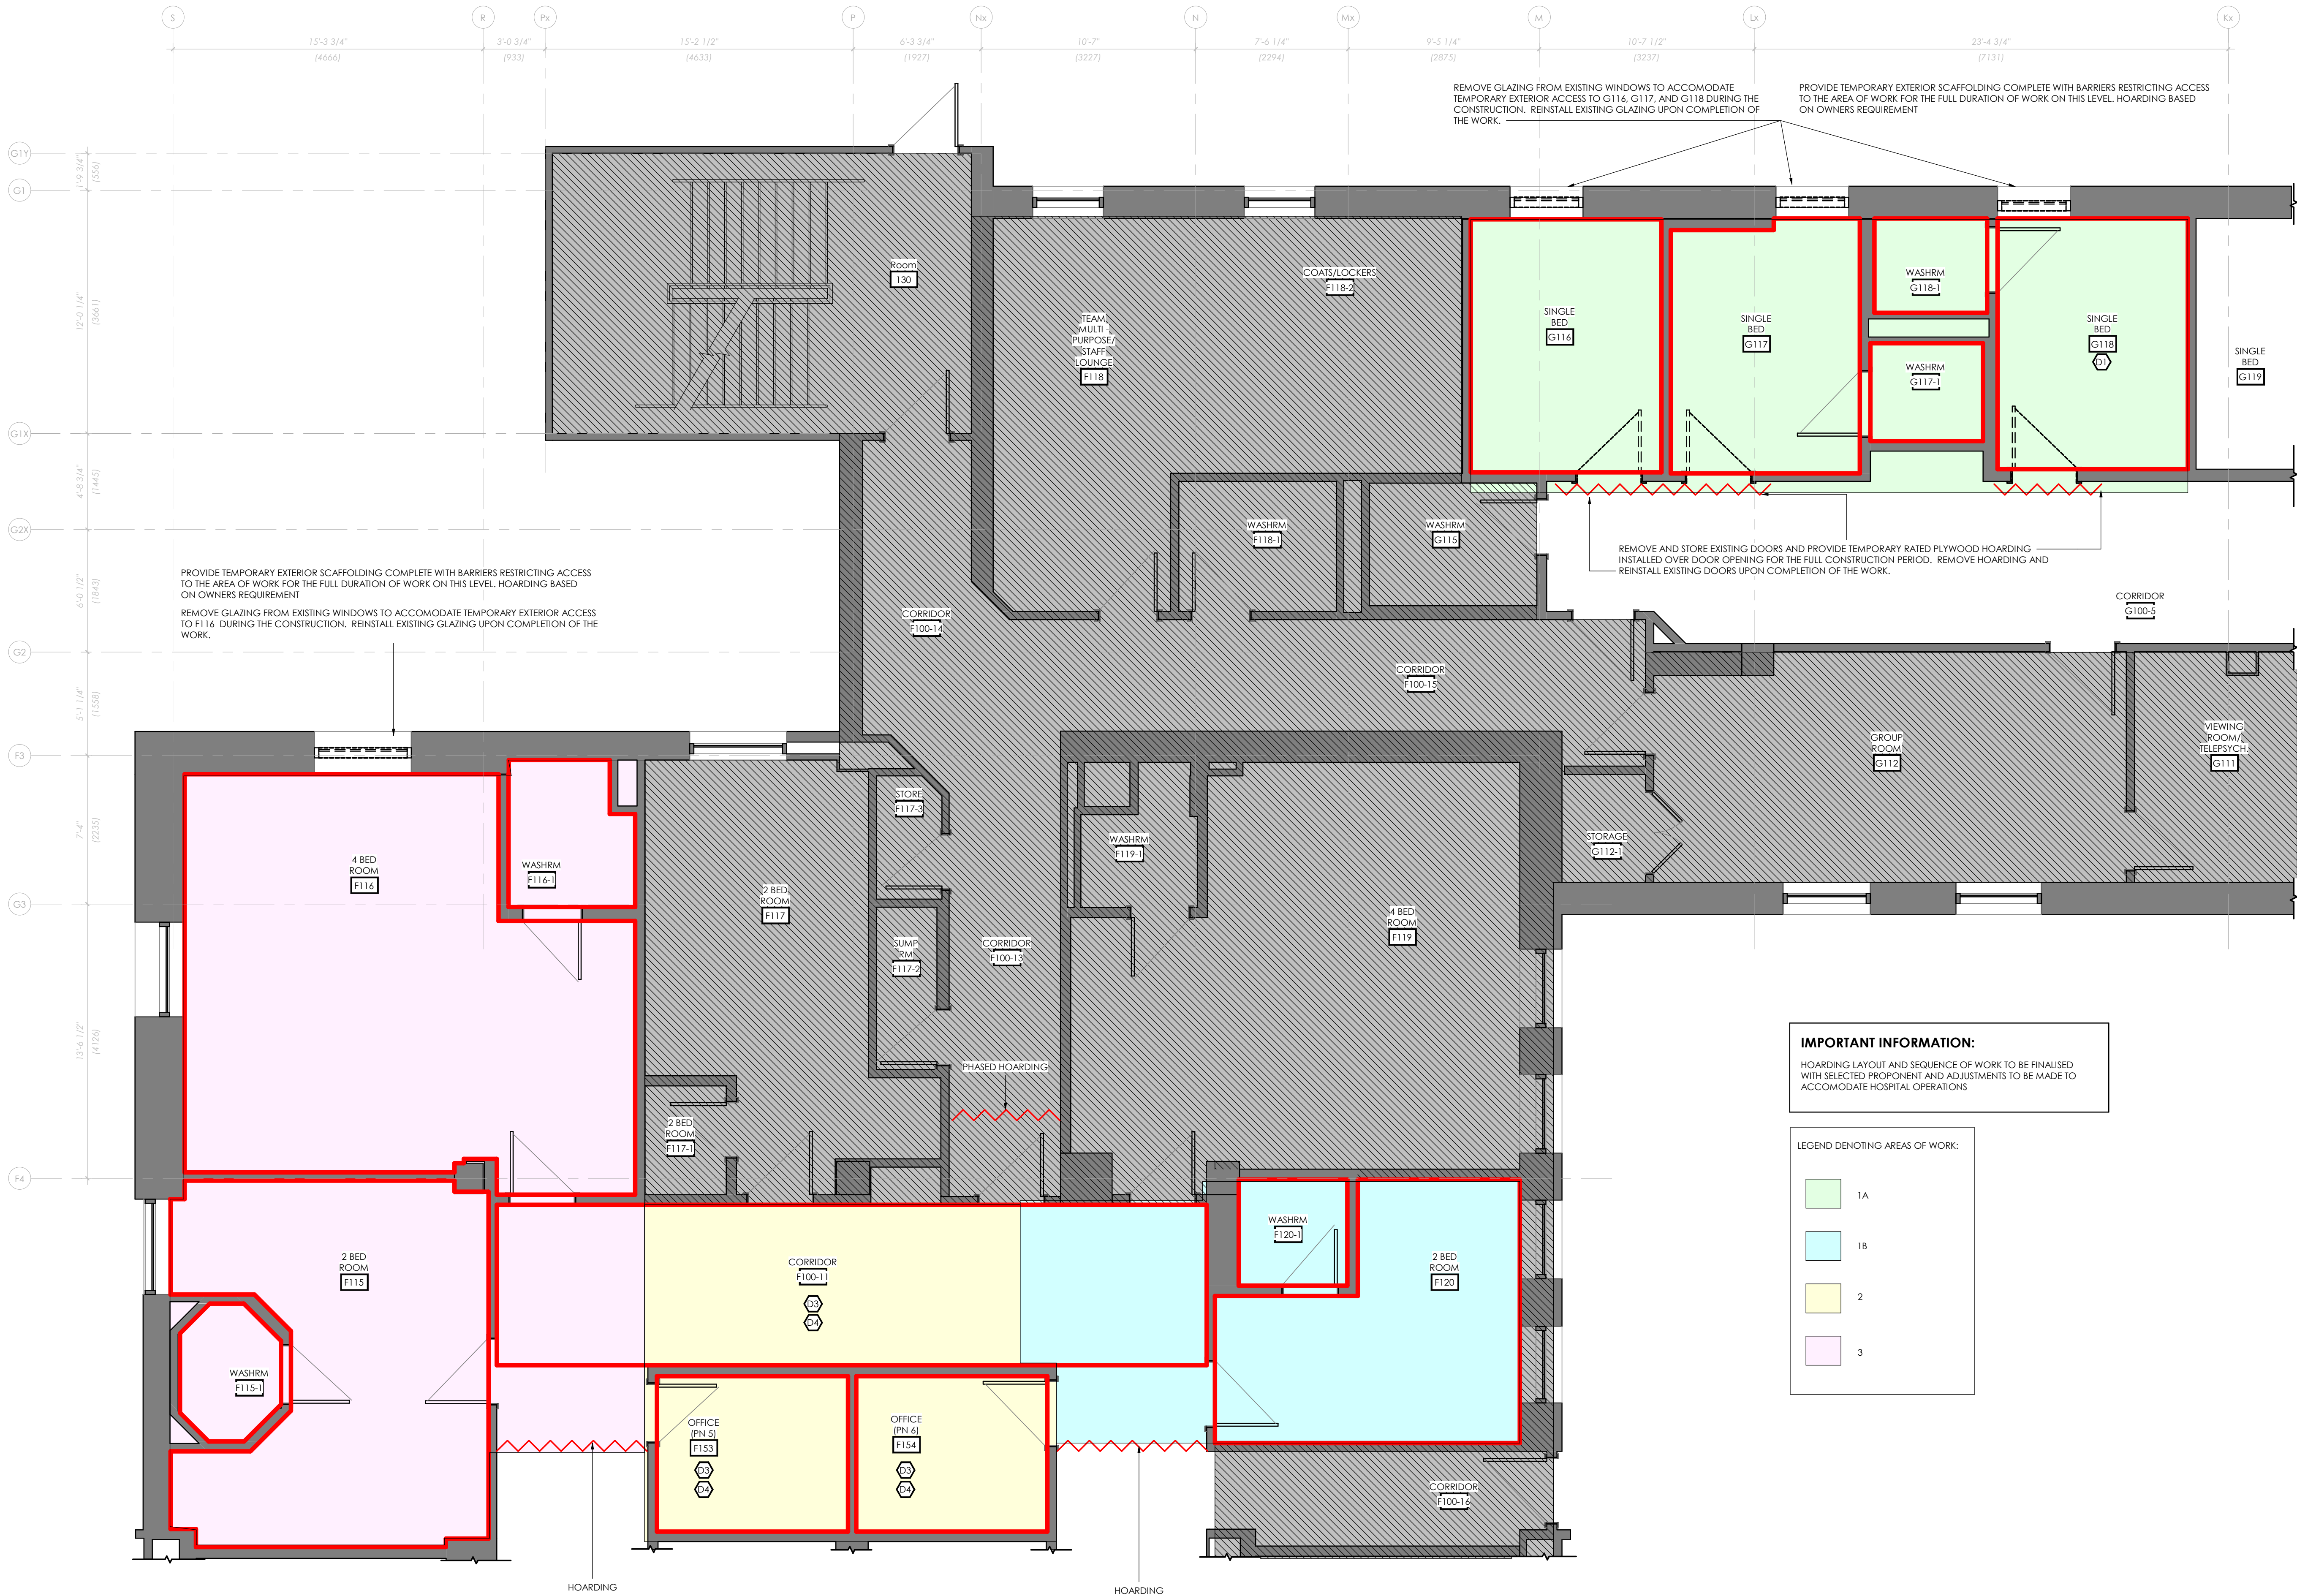

1
A2.1
LEVEL 1 - PHASING PLAN

1/4" = 1'-0"

IMPORTANT INFORMATION:



HOARDING LAYOUT AND SEQUENCE OF WORK TO BE FINALISED WITH SELECTED PROPONENT AND ADJUSTMENTS TO BE MADE TO ACCOMMODATE HOSPITAL OPERATIONS

LEGEND DENOTING AREAS OF WORK:

- 1A
- 1B
- 2
- 3



PROJECT LOGO

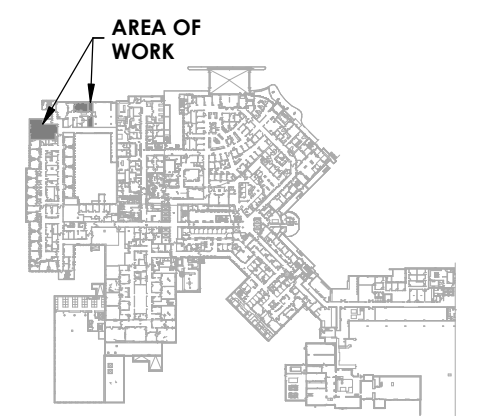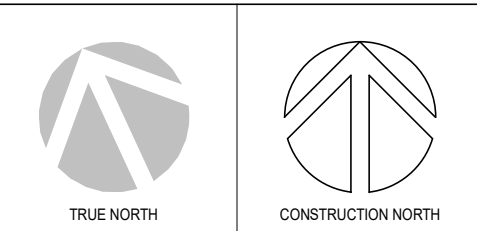

KEY PLAN

ISSUED FOR TENDER
(2026.02.27)

8	ISSUED FOR TENDER	2026-02-27
7	RE- ISSUED FOR PERMIT	2026-02-25
6	ISSUED FOR TENDER	2025-12-12
5	ISSUED FOR PERMIT	2025-11-28
4	FINAL DESIGN DEVELOPMENT SET	2025-11-07
3	FINAL DESIGN DEVELOPMENT SET	2025-10-31
2	100% DESIGN DEVELOPMENT SET	2025-09-29
1	50% DESIGN DEVELOPMENT PROGRESS SET	2025-05-09
No.	DESCRIPTION	DATE

REVISIONS: 2025.09.29

DISCREPANCIES MUST BE REPORTED IMMEDIATELY TO THE ARCHITECT / ENGINEER BEFORE PROCEEDING.

ONLY FIGURED DIMENSIONS MUST BE USED.

THE CONTRACTOR MUST CHECK THE DIMENSIONS ON SITE.

THE DRAWING IS PROTECTED BY COPYRIGHT.

ALL DIMENSIONS ARE SHOWN IN MILLIMETERS.

DO NOT SCALE THE DRAWINGS.

McCallumSather
Westinghouse HQ, 2nd Floor
286 Sanford Ave. N
Hamilton, ON L8L 6A1
905.526.6700
www.mccallumsather.com



SEAL

CONSULTANTS:

PROJECT:
WATERLOO REGIONAL HEALTH NETWORK @ MIDTOWN - PET CT


835 KING ST W, KITCHENER, ON N2G 1G3

DRAWING TITLE:
PROPOSED L1 ENLARGED PHASING / HOARDING PLAN

DRAWN BY: SB DATE: 2025.10.31
CHECKED BY: GL SCALE: 1/4" = 1'-0"

PROJECT NO: **24048**

DRAWING NO: **A2.1**

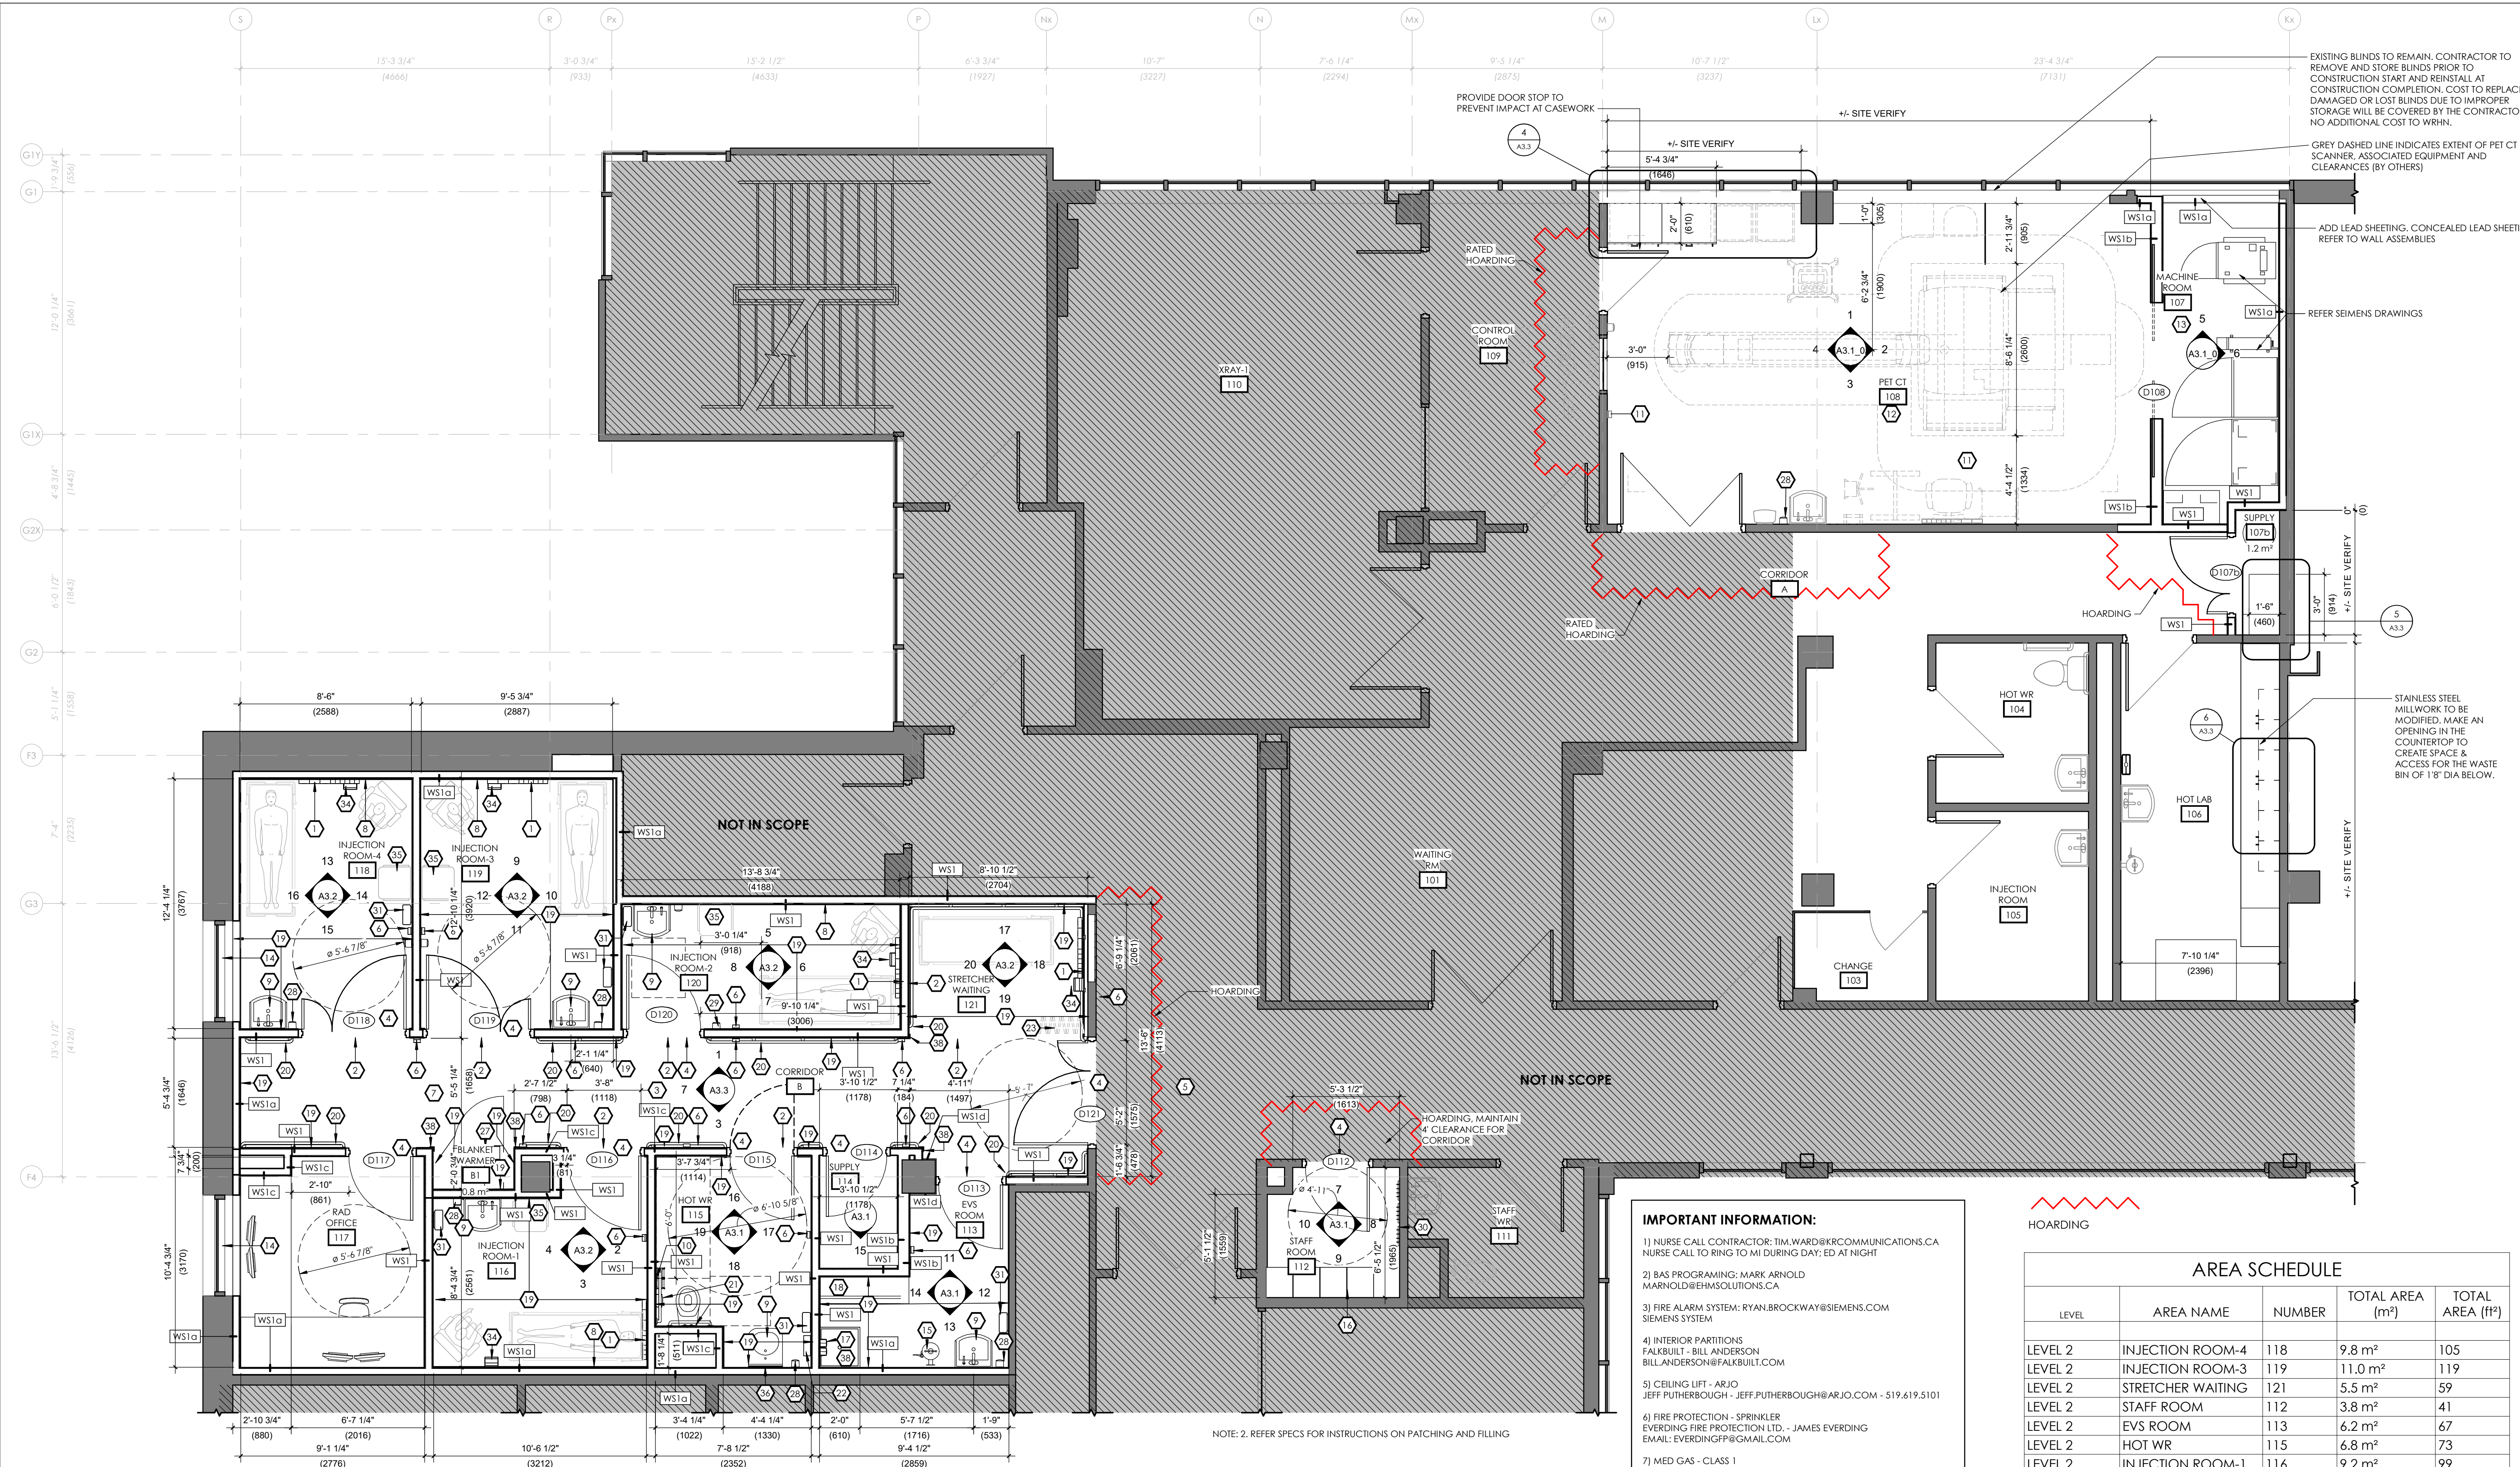

- KEYNOTES:**
- 1 HEADWALL WITH OXYGEN AND VACUUM:
 - 2 EMERGENCY POWER OUTLETS
 - 2 NORMAL POWER OUTLETS
 - 1 DATA OUTLET
 - 1 NURSE CALL EMERGENCY CALL
 - 1 STANDARD CALL
 - 1 OXYGEN OUTLET
 - 1 VACUUM OUTLET
 - 2 NEW NURSE CALL DOME LIGHT, CENTERED ABOVE DOOR FRAME
 - 3 NEW CEILING MOUNTED NURSE CALL DISPLAY, COORDINATE WITH OTHER CEILING MOUNTED DEVICES
 - 4 ALUMINUM PROTECTION ON ALL DOOR FRAMES, 10" KICK PLATES TO BE ALUMINUM.
 - 5 HALLWAY MIRROR THAT SHOWS 3 PATHS OF TRAVEL. MOUNTED TO CEILING, COORDINATE WITH OTHER CEILING MOUNTED DEVICES
 - 6 AUTOMATIC DOOR OPENER
 - 7 WIRELESS ACCESS POINT - DATA CONNECTION (CEILING)
 - 8 FULL HEIGHT WALL PROTECTION (WP3), REFER TO INTERIOR ELEVATIONS AND ROOM FINISH SCHEDULE FOR DETAILS.
 - 9 TPAC DEEP HAND WASHING SINK - SENSOR FAUCET DIRECTLY CONNECTED TO POWER - NO BATTERY. (TYP.) REFER TO MECH AND ELEC DRAWINGS FOR DETAILS.
 - 10 EMERGENCY NURSE CALL AND STANDARD NURSE CALL FULL CORD.
 - 11 EXISTING CEILING LIFT TO BE RELOCATED FOR EQUIPMENT.
 - 12 EXISTING O2 AND VACUUM TO REMAIN. NURSE CALL TO REMAIN. MEDICAL AIR TO REMAIN.
 - 13 FOR EQUIPMENTS - REFER TO SIEMENS DRAWING
 - 14 NEW BLINDS TO MATCH BASE BUILDING STANDARD
 - 15 EMERGENCY EYE WASH SINK.
 - 16 NEW STAFF LOCKER. REFER TO INTERIOR ELEVATIONS
 - 17 CLEANING CHEMICAL DISPENSER
 - 18 STEEL SHELVING, PRODUCT OF ULINE 6 ft (L) x 3 ft (W) x 1.5 ft (D) - SUPPLIED AND INSTALLED BY OWNER
 - 19 WALL PROTECTION TO 4'-0" HIGH, REFER TO INTERIOR ELEVATIONS AND ROOM FINISH SCHEDULE FOR DETAILS.
 - 20 NEW WALL MT. HAND RAIL (HRB-4C)
 - 21 SANITARY NAPKIN DISPOSAL
 - 22 WALL MOUNTED STAINLESS STEEL SHELF 100 D X 305 L, MOUNTED BETWEEN 900-1000MM AFF
 - 23 SILENTIA - FIXED SCREEN LONG PANEL WALL, STANDARD DAYLIGHT, DAYLIGHT 2.4 M (L) X 1.85M (H) DEPTH AND WIDTH FOLDED WALL DISTANCE 0 M WEIGHT 15.3 KG PRODUCT ART. NO. 04355-D SUPPLIED AND INSTALLED BY OWNER
 - 24 INSTALL STUD WALL HOARDING AT END OF WORK
 - 25 REMOVE DRYWALL, ADD LEAD SHEETING, REPLACE WITH NEW DRYWALL AND FINISH TO MATCH ADJACENT SURFACES
 - 26 2" FURRING WALL TO ACCOMMODATE ELECTRICAL PANEL
 - 27 BLANKET WARMER, SUPPLIED AND INSTALLED BY OWNER
 - 28 SOAP DISPENSER, OWNER SUPPLIED, INSTALLED BY CONTRACTOR
 - 29 HAND SANITIZER, OWNER SUPPLIED, INSTALLED BY CONTRACTOR
 - 30 NEW WALL MT. STAINLESS STEEL COAT HOOKS
 - 31 PAPER TOWEL DISPENSER, OWNER SUPPLIED, INSTALLED BY CONTRACTOR
 - 32 GRAB BAR (REFER TO A1.1 & A1.4 - TYPICAL DETAILS)
 - 33 REFER TO ELECTRICAL
 - 34 SHARPS CONTAINER, OWNER SUPPLIED, INSTALLED BY CONTRACTORS
 - 35 SOILED LINEN HAMPER
 - 36 MIRROR WITH TASK LIGHT ABOVE
 - 37 MOP SINK
 - 38 RECESSED SS CORNER GUARD, REFER SPECS
 - 39 ROOFTOP GUARD RAIL, REFER SPECS

IMPORTANT INFORMATION:

- 1) NURSE CALL CONTRACTOR: TIM.WARD@KRCOMMUNICATIONS.CA NURSE CALL TO RING TO MI DURING DAY; ED AT NIGHT
- 2) BAS PROGRAMING: MARK ARNOLD MARK.ARNOLD@EHSOLUTIONS.CA
- 3) FIRE ALARM SYSTEM: RYAN.BROCKWAY@SIEMENS.COM SIEMENS SYSTEM
- 4) INTERIOR PARTITIONS: FALKBUILT - BILL ANDERSON BILL.ANDERSON@FALKBUILT.COM
- 5) CEILING LIFT - ARJO JEFF.PUTERBOUGH - JEFF.PUTERBOUGH@ARJO.COM - 519.619.5101
- 6) FIRE PROTECTION - SPRINKLER EVERDING FIRE PROTECTION LTD. - JAMES EVERDING EMAIL: EVERDINGFP@GMAIL.COM
- 7) MED GAS - CLASS 1 ALLISON ROSS INSIDE SERVICE SALES REPRESENTATIVE - EASTERN CANADA C: 647.949.8553, E: ALLISON.ROSS@CLASS1INC.COM
- 8) FLYNN (ROOFING) - MARCO ROBERTI MARCO.ROBERTI@FLYNNCOMPANIES.COM C: 519.465.7087 T: 519.568.5396





AREA SCHEDULE				
LEVEL	AREA NAME	NUMBER	TOTAL AREA (m²)	TOTAL AREA (ft²)
LEVEL 2	INJECTION ROOM-4	118	9.8 m²	105
LEVEL 2	INJECTION ROOM-3	119	11.0 m²	119
LEVEL 2	STRETCHER WAITING	121	5.5 m²	59
LEVEL 2	STAFF ROOM	112	3.8 m²	41
LEVEL 2	EV'S ROOM	113	6.2 m²	67
LEVEL 2	HOT WR	115	6.8 m²	73
LEVEL 2	INJECTION ROOM-1	116	9.2 m²	99
LEVEL 2	RAD OFFICE	117	8.9 m²	96
LEVEL 2	HOT LAB	106	12.9 m²	139
LEVEL 2	MACHINE ROOM	107	9.5 m²	102
LEVEL 2	PET CT	108	39.8 m²	429
LEVEL 2	SUPPLY	107b	1.3 m²	14
LEVEL 2	INJECTION ROOM-2	120	8.0 m²	86
LEVEL 2	SUPPLY	114	2.1 m²	22
LEVEL 2	BLANKET WARMER	B1	0.7 m²	8
Grand total			135.4 m²	1457

G.G.S.F = 177 m² 1905 ft²



PROJECT LOGO

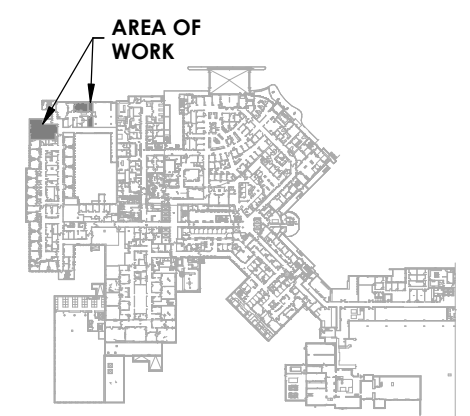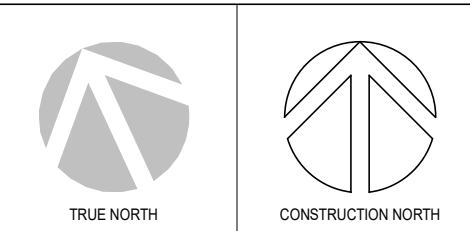

KEY PLAN

ISSUED FOR TENDER
(2026.02.27)

NO.	REVISIONS	DESCRIPTION	DATE
1	50% DESIGN DEVELOPMENT PROGRESS SET	2025.05.09	
2	100% DESIGN DEVELOPMENT PROGRESS SET	2025.09.29	
3	FINAL DESIGN DEVELOPMENT SET	2025.10.31	
4	FINAL DESIGN DEVELOPMENT SET	2025.11.07	
5	ISSUED FOR PERMIT	2025.11.28	
6	ISSUED FOR TENDER	2025.12.12	
7	RE- ISSUED FOR PERMIT	2026.02.25	
8	ISSUED FOR TENDER	2026.02.27	

DISCREPANCIES MUST BE REPORTED IMMEDIATELY TO THE ARCHITECT / ENGINEER BEFORE PROCEEDING.
ONLY FIGURED DIMENSIONS MUST BE USED.
THE CONTRACTOR MUST CHECK THE DIMENSIONS ON SITE.
THE DRAWING IS PROTECTED BY COPYRIGHT.
ALL DIMENSIONS ARE SHOWN IN MILLIMETERS.
DO NOT SCALE THE DRAWINGS.

McCallumSather
Westinghouse HQ, 2nd Floor
286 Sanford Ave. N
Hamilton, ON L8L 6A1
905.526.6700
www.mccallumsather.com



SEAL

CONSULTANTS:

PROJECT:
WATERLOO REGIONAL HEALTH NETWORK @ MIDTOWN - PET CT

835 KING ST W, KITCHENER, ON
N2G 1G3

DRAWING TITLE:
PROPOSED L2 ENLARGED FLOOR PLAN

DRAWN BY: SB DATE: 2025.10.31
CHECKED BY: GL SCALE: 1/4" = 1'-0"

PROJECT NO: **24048**

DRAWING NO: **A2.2**



NOTE:
1. ACCESS PANELS SHALL BE PROVIDED AT ALL FIRE DAMPER LOCATIONS. COORDINATE EXACT LOCATIONS WITH MECHANICAL DRAWINGS 1/M503
2. REFER SPECS FOR INSTRUCTIONS ON PATCHING AND FILLING



REMOVE AND SALVAGE EXISTING CEILING TILES. REINSTALL T-BARS AS REQUIRED. COORDINATE WITH MECHANICAL DRAWINGS. (1/M502)

NOTE:
1. THE CONTRACTOR SHALL REPAIR OR REPLACE, AT NO ADDITIONAL COST TO WRHN, ANY DAMAGE CAUSED TO EXISTING WALLS, WALL PROTECTION SYSTEMS, FINISHES, FURNITURE, EQUIPMENT, DEVICES, OR ADJACENT BUILDING ELEMENTS RESULTING FROM THE PERFORMANCE OF THE WORK.
2. MECHANICAL WORK IN CEILING FOR THE AIR SUPPLY IN HOT LAB TO BE COMPLETED ON NIGHTS ONLY AS THIS IS AN OPERATIONAL DEPARTMENT NOT BEING DECONTAMINATED, CEILING TILES CAN BE REMOVED AND POLYCEILING TO CONCEAL ABOVE CEILING DURING DAYTIME HOURS TO BE IMPLEMENTED.

KEYNOTES:

- | | | | | | | | |
|--|--|--|--|---|--|--|---|
| <p>1 HEADWALL WITH OXYGEN AND VACUUM:
• 2 EMERGENCY POWER OUTLETS
• 2 NORMAL POWER OUTLETS
• 1 DATA OUTLET
• 1 NURSE CALL EMERGENCY CALL
• 1 STANDARD CALL
• 1 OXYGEN OUTLET
• 1 VACUUM OUTLET</p> | <p>5 HALLWAY MIRROR THAT SHOWS 3 PATHS OF TRAVEL. MOUNTED TO CEILING. COORDINATE WITH OTHER CEILING MOUNTED DEVICES</p> <p>6 AUTOMATIC DOOR OPENER.</p> <p>7 WIRELESS ACCESS POINT - DATA CONNECTION (CEILING)</p> <p>8 FULL HEIGHT WALL PROTECTION (WP3). REFER TO INTERIOR ELEVATIONS AND ROOM FINISH SCHEDULE FOR DETAILS.</p> <p>9 IPAC DEEP HAND WASHING SINK - SENSOR FAUCET DIRECTLY CONNECTED TO POWER - NO BATTERY. (TYP.) REFER TO MECH AND ELEC DRAWINGS FOR DETAILS.</p> <p>10 EMERGENCY NURSE CALL AND STANDARD NURSE CALL PULL CORD.</p> | <p>11 EXISTING CEILING LIFT TO BE RELOCATED FOR EQUIPMENT.</p> <p>12 EXISTING O2 AND VACUUM TO REMAIN, NURSE CALL TO REMAIN, MEDICAL AIR TO REMAIN.</p> <p>13 FOR EQUIPMENTS - REFER TO SIEMENS DRAWING</p> <p>14 NEW BLINDS TO MATCH BASE BUILDING STANDARD</p> <p>15 EMERGENCY EYE WASH SINK.</p> <p>16 NEW STAFF LOCKER, REFER TO INTERIOR ELEVATIONS</p> | <p>17 CLEANING CHEMICAL DISPENSER</p> <p>18 STEEL SHELVING, PRODUCT OF ULINE 6 ft (L) x 3 ft (W) x 1.5 ft (D) - SUPPLIED AND INSTALLED BY OWNER</p> <p>19 WALL PROTECTION TO 4'-0" HIGH. REFER TO INTERIOR ELEVATIONS AND ROOM FINISH SCHEDULE FOR DETAILS.</p> <p>20 NEW WALL MT. HAND RAIL (HRB-4C)</p> <p>21 SANITARY NAPKIN DISPOSAL</p> <p>22 WALL MOUNTED STAINLESS STEEL SHELF 100 D X 305 L MOUNTED BETWEEN 900-1000MM AFF</p> | <p>23 SILENTIA - FIXED SCREEN LONG PANEL DAYLIGHT, DAYLIGHT 2.4 M (L) X 1.85M (H) DEPTH AND WIDTH: FOLDED WALL DISTANCE 0 M WEIGHT 15.3 KG PRODUCT ART. NO. 04355-D SUPPLIED AND INSTALLED BY OWNER</p> <p>24 INSTALL STUD WALL HOARDING AT END OF WORK</p> <p>25 REMOVE DRYWALL, ADD LEAD SHEETING, REPLACE WITH NEW DRYWALL AND FINISH TO MATCH ADJACENT SURFACES</p> | <p>26 2" FURRING WALL TO ACCOMMODATE ELECTRICAL PANEL</p> <p>27 BLANKET WARMER, SUPPLIED AND INSTALLED BY OWNER</p> <p>28 SOAP DISPENSER, OWNER SUPPLIED, INSTALLED BY CONTRACTOR</p> <p>29 HAND SANITIZER, OWNER SUPPLIED, INSTALLED BY CONTRACTOR</p> <p>30 NEW WALL MT. STAINLESS STEEL COAT HOOKS</p> <p>31 PAPER TOWEL DISPENSER, OWNER SUPPLIED, INSTALLED BY CONTRACTOR</p> | <p>32 GRAB BAR (REFER TO A1.1 & A1.4 - TYPICAL DETAILS)</p> <p>33 REFER TO ELECTRICAL</p> <p>34 SHARPS CONTAINER, OWNER SUPPLIED, INSTALLED BY CONTRACTORS</p> <p>35 SOILED LINEN HAMPER</p> <p>36 MIRROR WITH TASK LIGHT ABOVE</p> <p>37 MOP SINK</p> <p>38 RECESSED SS CORNER GUARD, REFER SPECS</p> | <p>39 ROOFTOP GUARD RAIL, REFER SPECS</p> |
|--|--|--|--|---|--|--|---|

PROJECT LOGO

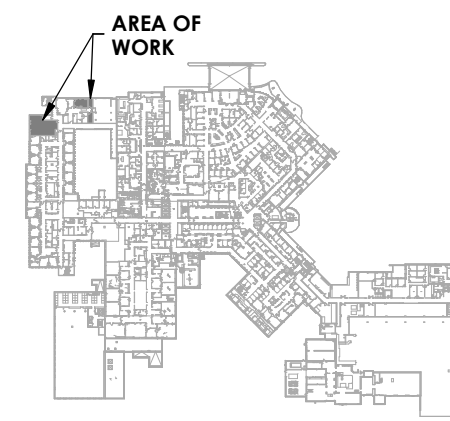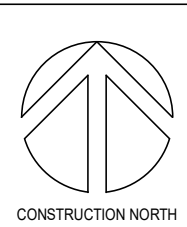

KEY PLAN

ISSUED FOR TENDER
(2026.02.27)

8	ISSUED FOR TENDER	2026-02-27
7	RE- ISSUED FOR PERMIT	2026-02-25
6	ISSUED FOR TENDER	2025-12-12
5	ISSUED FOR PERMIT	2025-11-28
4	FINAL DESIGN DEVELOPMENT SET	2025-11-07
3	FINAL DESIGN DEVELOPMENT SET	2025-10-31
2	100% DESIGN DEVELOPMENT SET	2025-09-29
1	50% DESIGN DEVELOPMENT PROGRESS SET	2025-05-09
No.	DESCRIPTION	DATE
REVISIONS		
		2025-09-29

DISCREPANCIES MUST BE REPORTED IMMEDIATELY TO THE ARCHITECT / ENGINEER BEFORE PROCEEDING.
ONLY FIGURED DIMENSIONS MUST BE USED.
THE CONTRACTOR MUST CHECK THE DIMENSIONS ON SITE.
THE DRAWING IS PROTECTED BY COPYRIGHT.
ALL DIMENSIONS ARE SHOWN IN MILLIMETERS.
DO NOT SCALE THE DRAWINGS.

McCallumSather
Westinghouse HQ, 2nd Floor
286 Sanford Ave. N
Hamilton, ON L8L 6A1
905.526.6700
www.mccallumsather.com



SEAL

CONSULTANTS:

PROJECT:
**WATERLOO REGIONAL HEALTH
NETWORK @ MIDTOWN - PET CT**


**835 KING ST W, KITCHENER, ON
N2G 1G3**

DRAWING TITLE:
**ENLARGED L2 REFLECTED
CEILING PLAN**



DRAWN BY: SB DATE: 2025.10.31
CHECKED BY: GL SCALE: 1/4" = 1'-0"

PROJECT NO: **24048**

DRAWING NO: **A2.3**

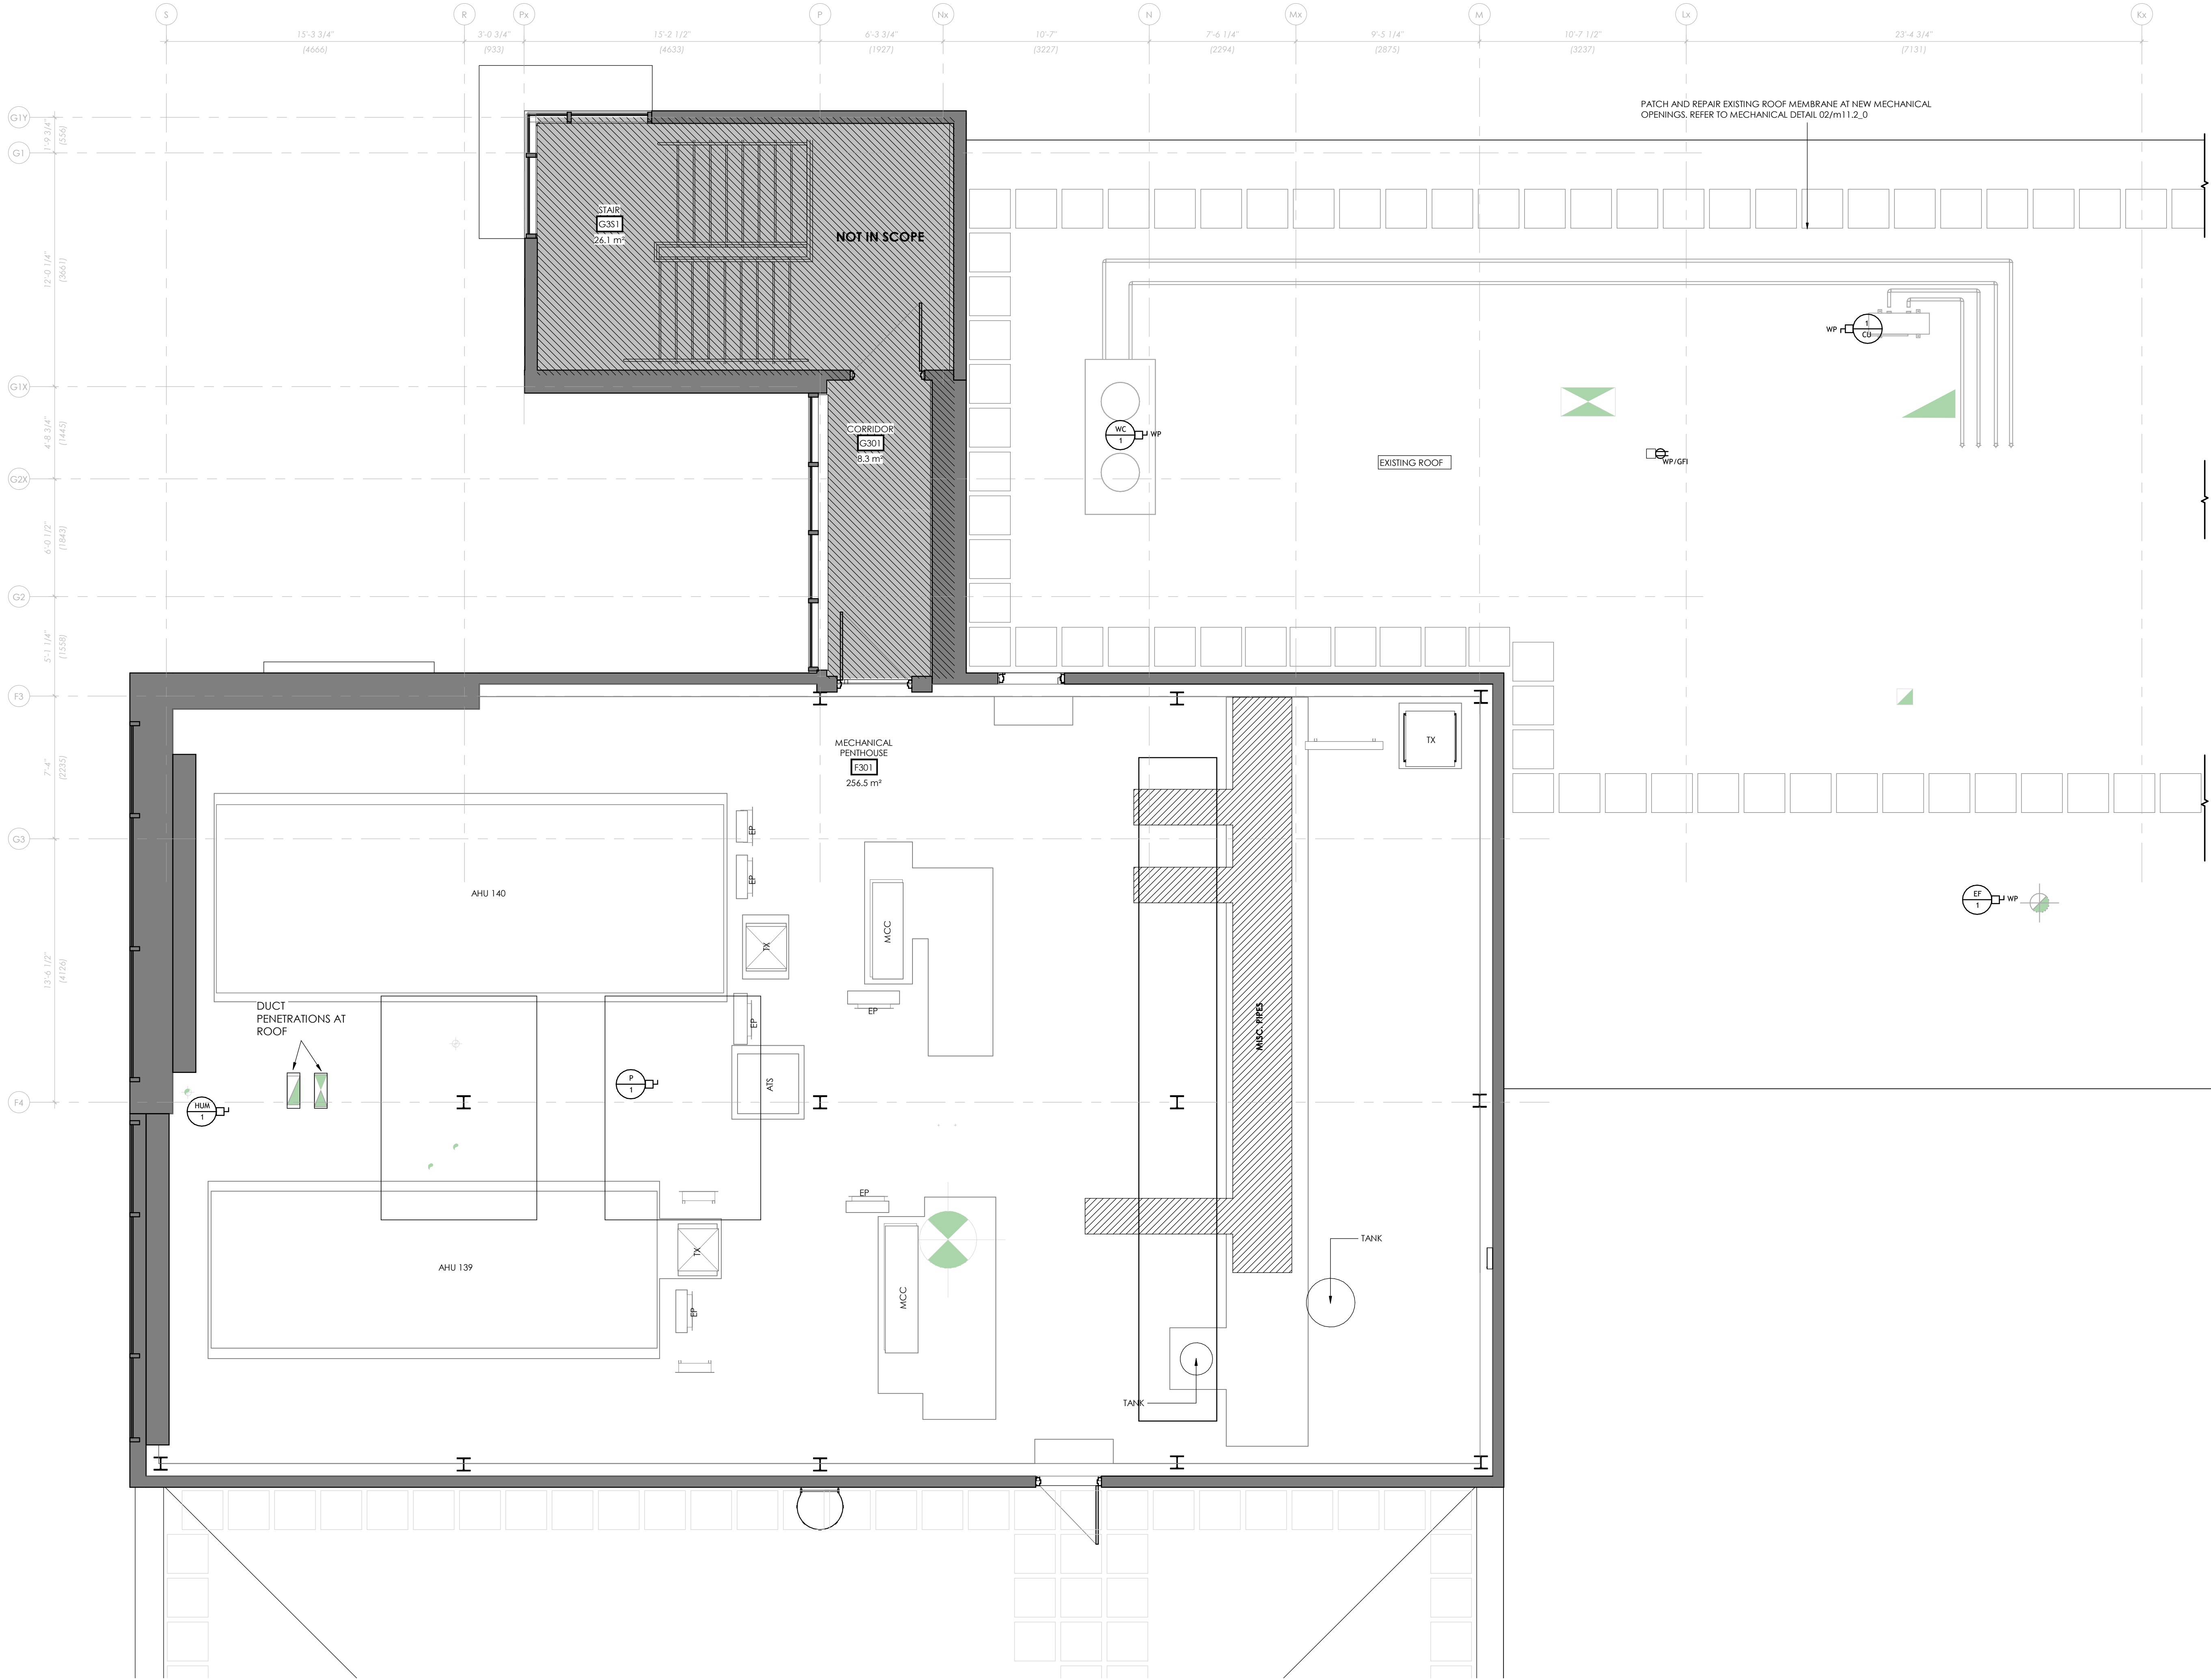

PROJECT LOGO

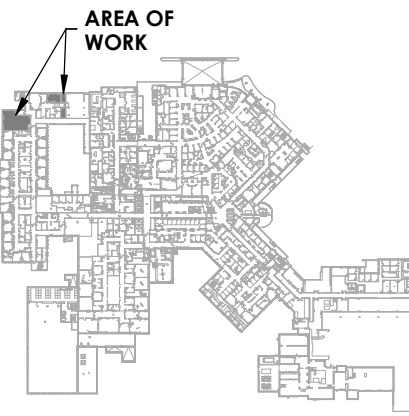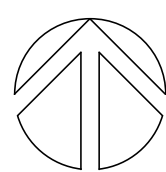

KEY PLAN

ISSUED FOR TENDER
(2026.02.27)

8	ISSUED FOR TENDER	2026-02-27
7	RE- ISSUED FOR PERMIT	2026-02-25
6	ISSUED FOR TENDER	2025-12-12
5	ISSUED FOR PERMIT	2025-11-28
4	FINAL DESIGN DEVELOPMENT SET	2025-11-07
3	FINAL DESIGN DEVELOPMENT SET	2025-10-31
2	100% DESIGN DEVELOPMENT PROGRESS SET	2025-09-29
1	50% DESIGN DEVELOPMENT PROGRESS SET	2025-05-09
No.	DESCRIPTION	DATE

REVISIONS: 2025.09.29

DISCREPANCIES MUST BE REPORTED IMMEDIATELY TO THE ARCHITECT / ENGINEER BEFORE PROCEEDING.

ONLY FIGURED DIMENSIONS MUST BE USED.

THE CONTRACTOR MUST CHECK THE DIMENSIONS ON SITE.

THE DRAWING IS PROTECTED BY COPYRIGHT.

ALL DIMENSIONS ARE SHOWN IN MILLIMETERS.

DO NOT SCALE THE DRAWINGS.

mcCallumSather
Westinghouse HQ, 2nd Floor
286 Sanford Ave. N
Hamilton, ON L8L 6A1
905.526.6700
www.mccallumsather.com



SEAL

CONSULTANTS:

PROJECT:
WATERLOO REGIONAL HEALTH NETWORK @ MIDTOWN - PET CT


835 KING ST W, KITCHENER, ON N2G 1G3

DRAWING TITLE:
EXISTING ENLARGED THIRD FLOOR PLAN

DRAWN BY: SB DATE: 10/07/25
CHECKED BY: GL SCALE: 1/4" = 1'-0"

PROJECT NO. **24048**

DRAWING NO. **A2.4**

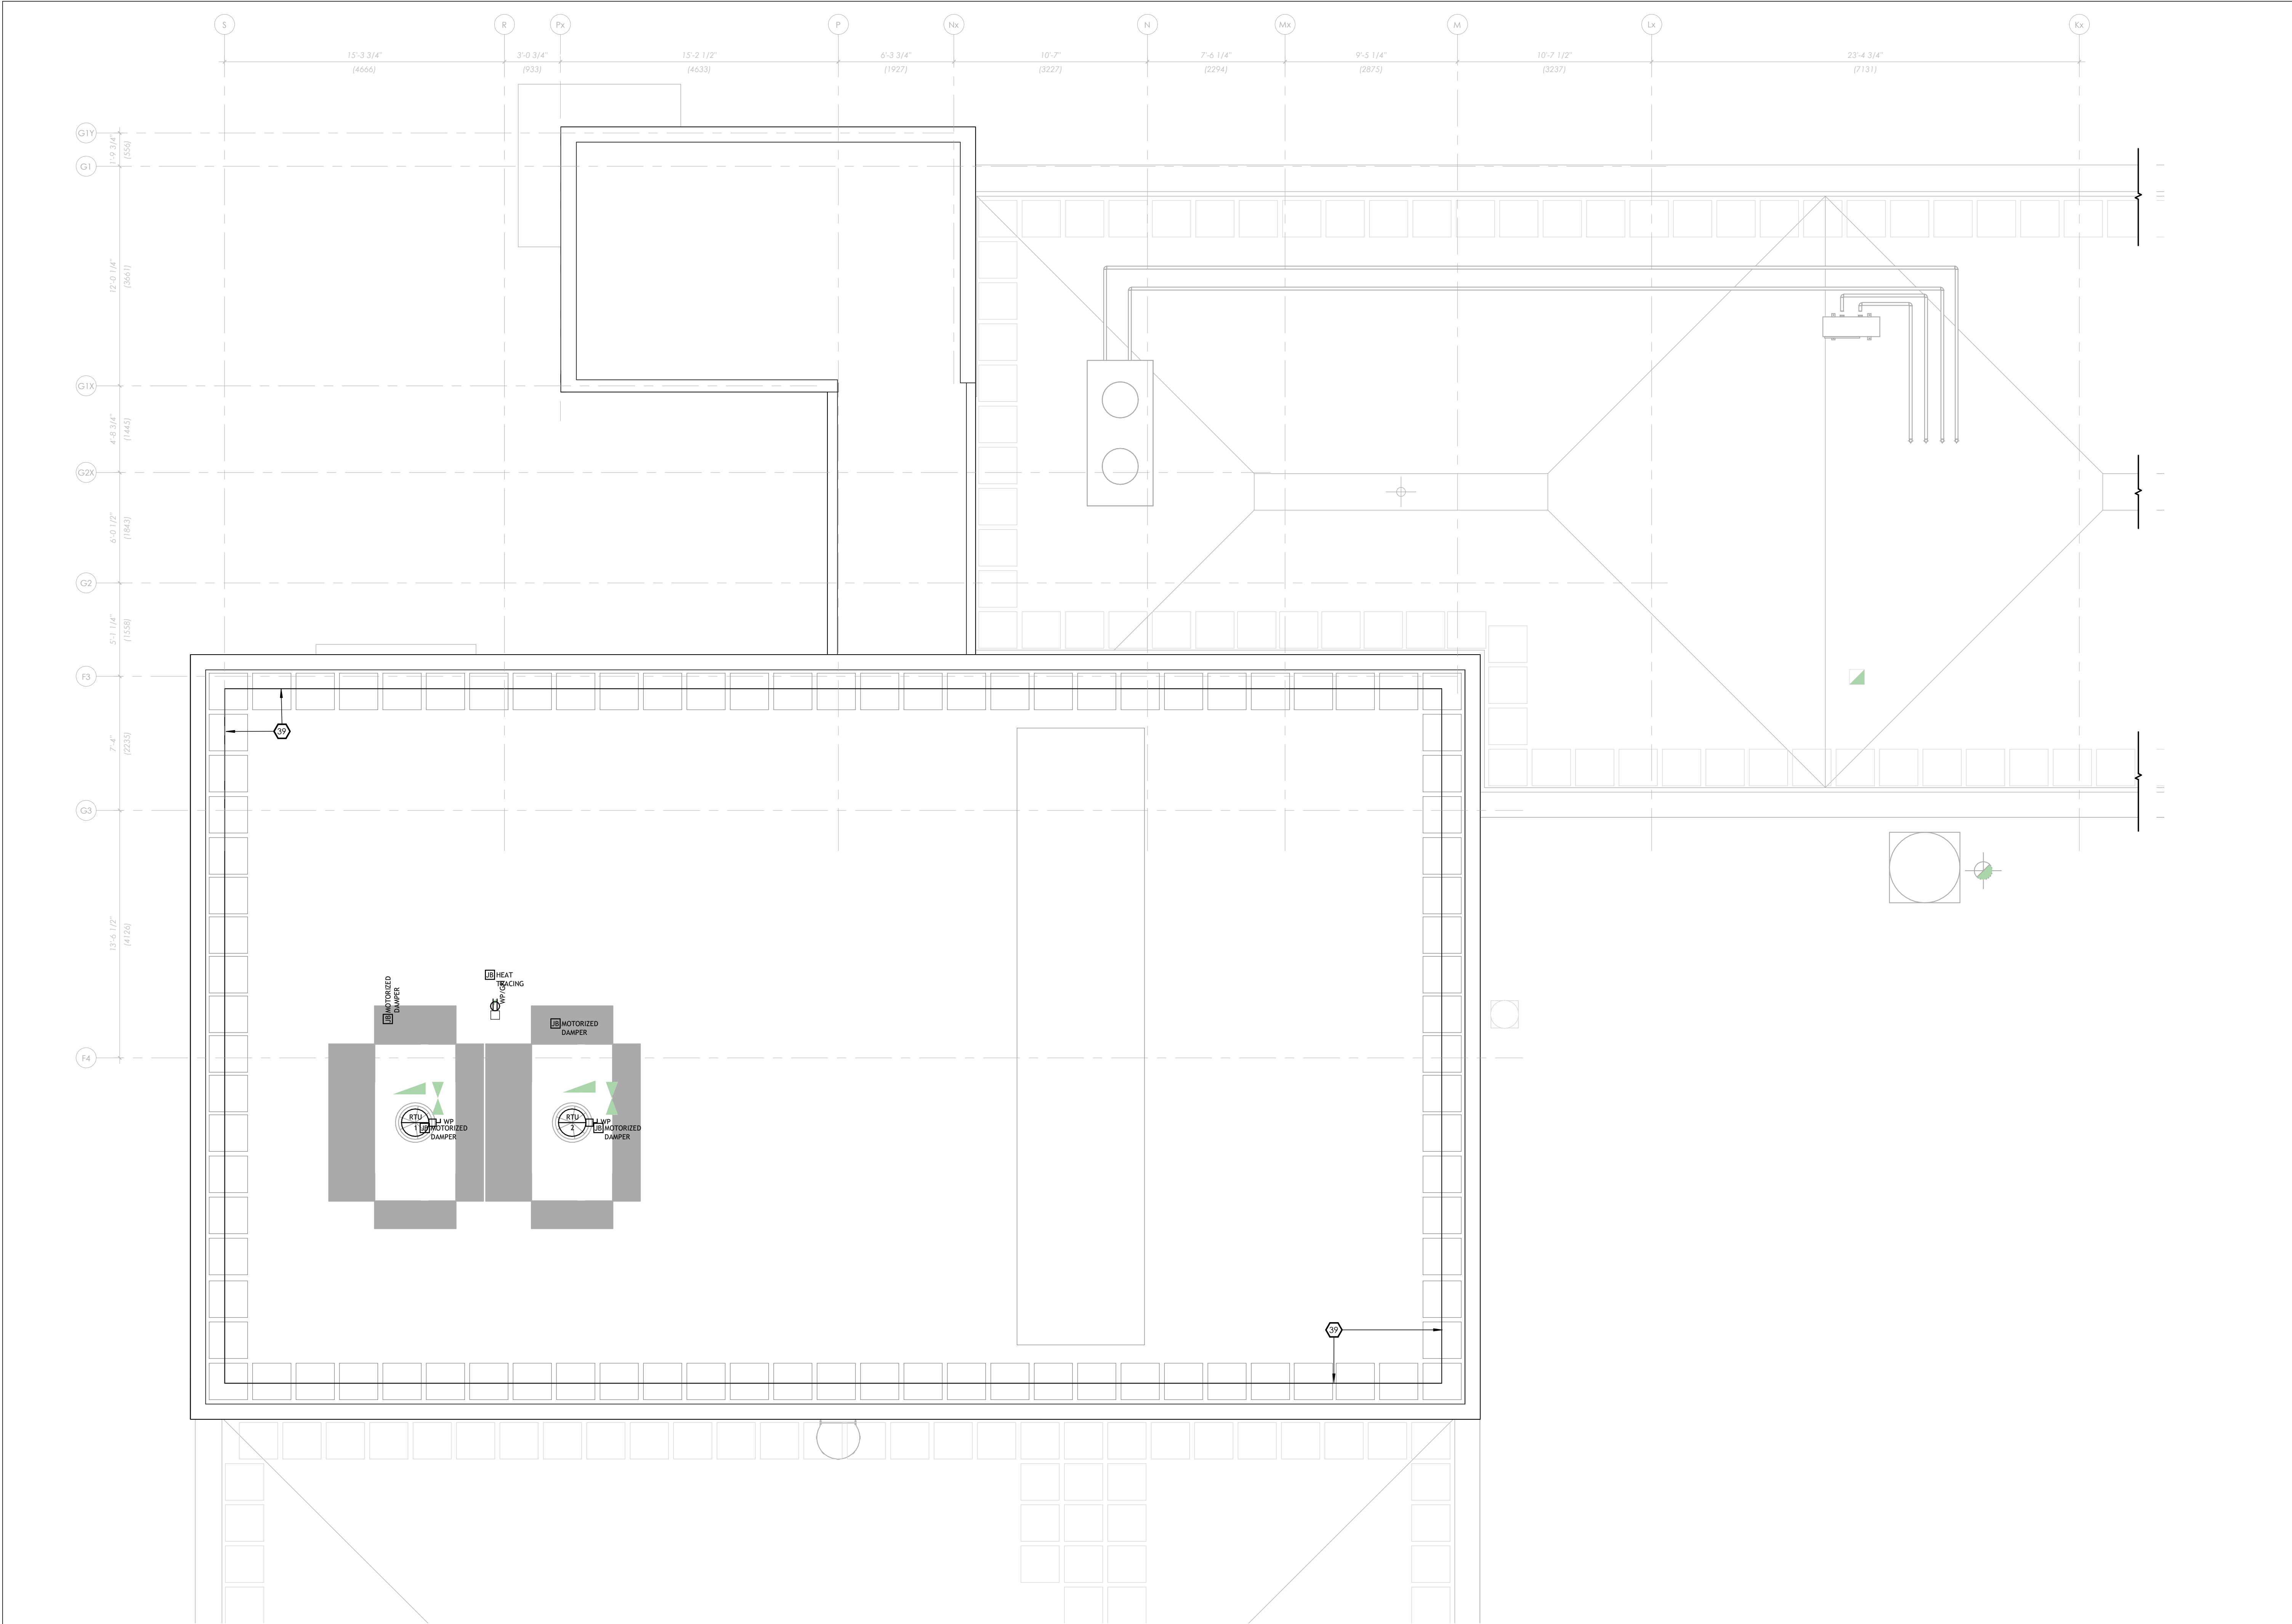




Waterloo Regional Health Network

PROJECT LOGO




TRUE NORTH

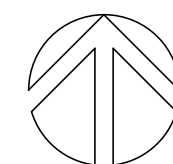

CONSTRUCTION NORTH

AREA OF WORK

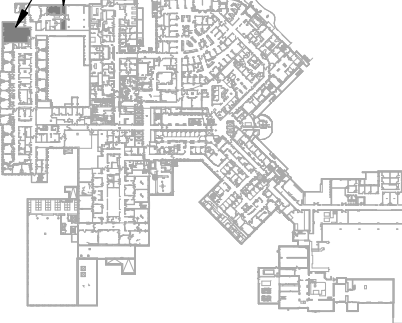

KEY PLAN

ISSUED FOR TENDER
(2026.02.27)

8	ISSUED FOR TENDER	2026-02-27
7	RE- ISSUED FOR PERMIT	2026-02-25
6	ISSUED FOR TENDER	2025-12-12
5	ISSUED FOR PERMIT	2025-11-28
4	FINAL DESIGN DEVELOPMENT SET	2025-11-07
3	FINAL DESIGN DEVELOPMENT SET	2025-10-31
2	100% DESIGN DEVELOPMENT PROGRESS SET	2025-09-29
1	50% DESIGN DEVELOPMENT PROGRESS SET	2025-05-09

No.	DESCRIPTION	DATE
REVISIONS:		
		2025-09-29

DISCREPANCIES MUST BE REPORTED IMMEDIATELY TO THE ARCHITECT / ENGINEER BEFORE PROCEEDING.
ONLY FIGURED DIMENSIONS MUST BE USED.
THE CONTRACTOR MUST CHECK THE DIMENSIONS ON SITE.
THE DRAWING IS PROTECTED BY COPYRIGHT.
ALL DIMENSIONS ARE SHOWN IN MILLIMETERS.
DO NOT SCALE THE DRAWINGS.

mcCallumSather
Westinghouse HQ, 2nd Floor
286 Sanford Ave. N
Hamilton, ON L8L 6A1
905.526.6700
www.mccallumsather.com



ONTARIO ASSOCIATION OF ARCHITECTS
GREGORY LATIMER
LICENCE 4772

SEAL

CONSULTANTS:

PROJECT:
WATERLOO REGIONAL HEALTH NETWORK @ MIDTOWN - PET CT

835 KING ST W, KITCHENER, ON N2G 1G3




















DRAWING TITLE:
EXISTING ENLARGED ROOF PLAN

DRAWN BY:	SB	DATE:	10/07/25
CHECKED BY:	MT	SCALE:	1/4" = 1'-0"

PROJECT NO. **24048**

DRAWING NO.: **A2.5**

PROJECT NO. 24048
DRAWING NO. A2.5
DATE 2025-09-13 13:39:44

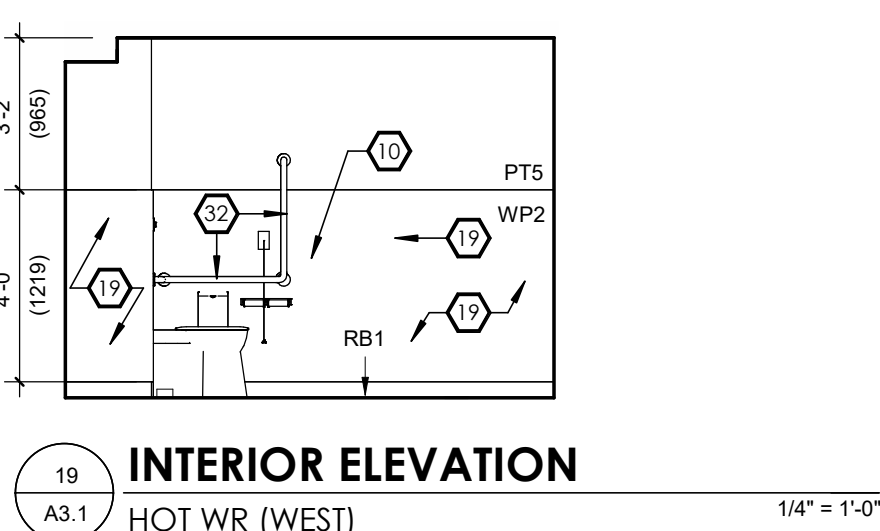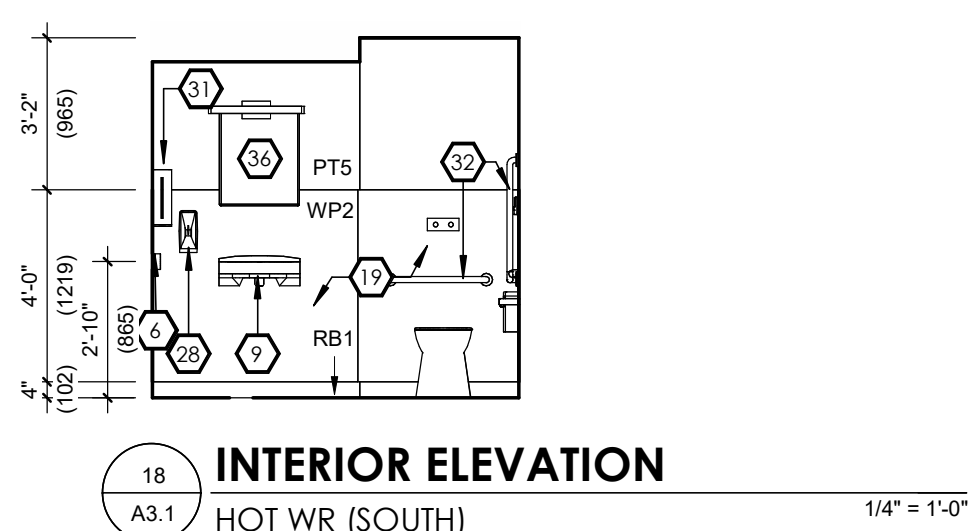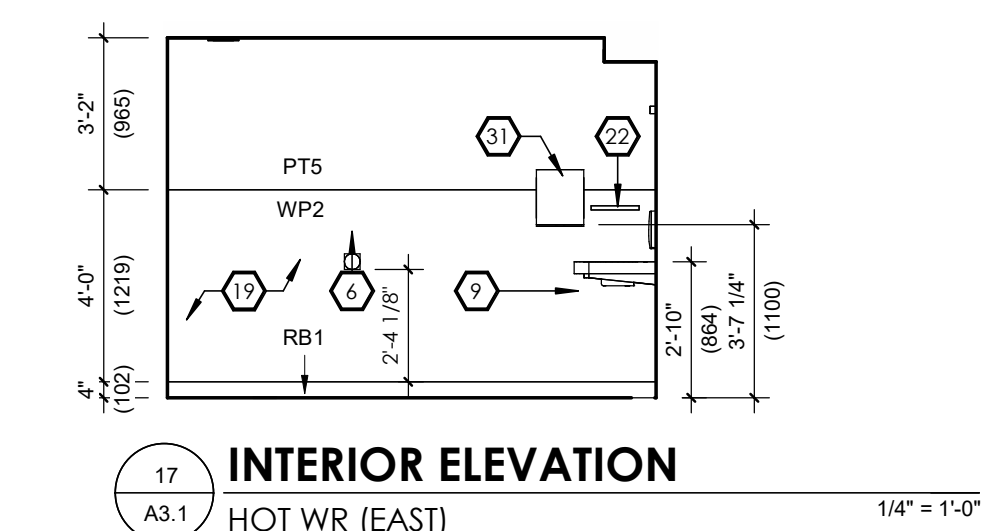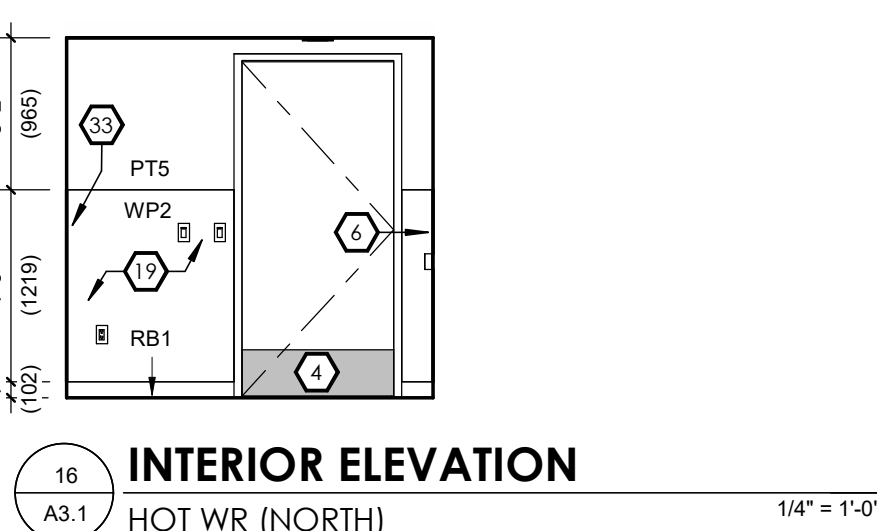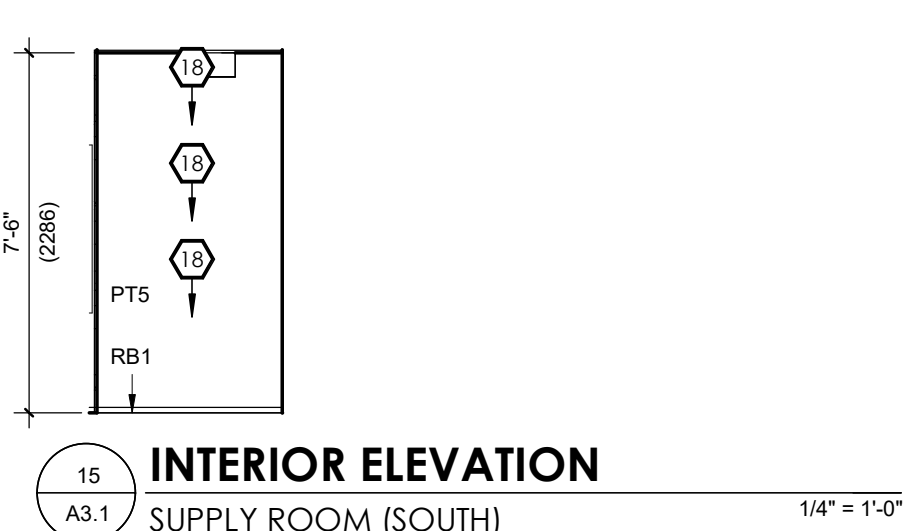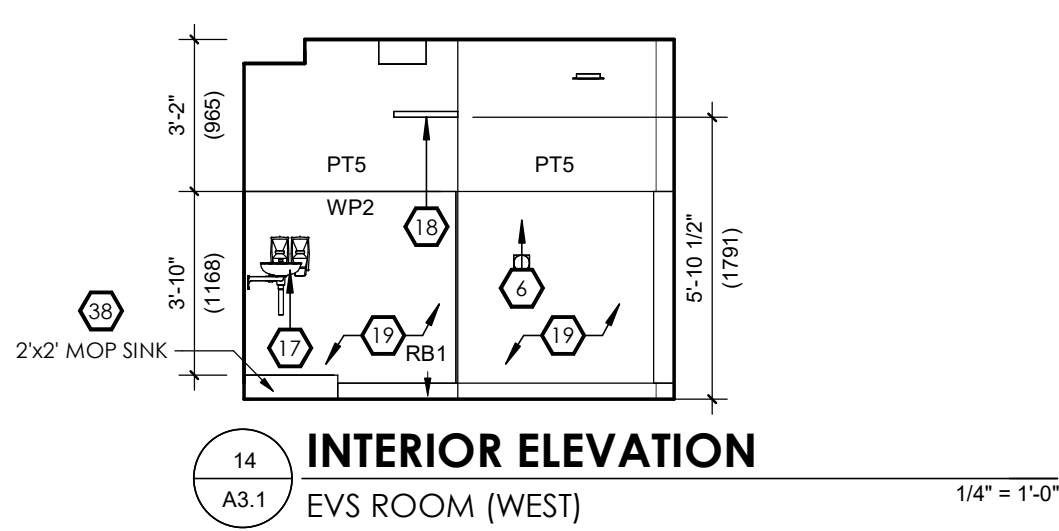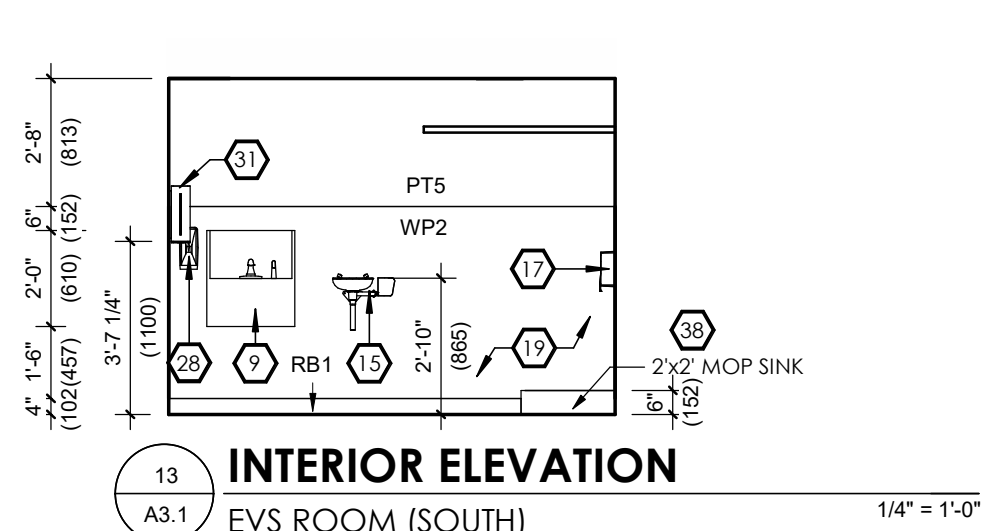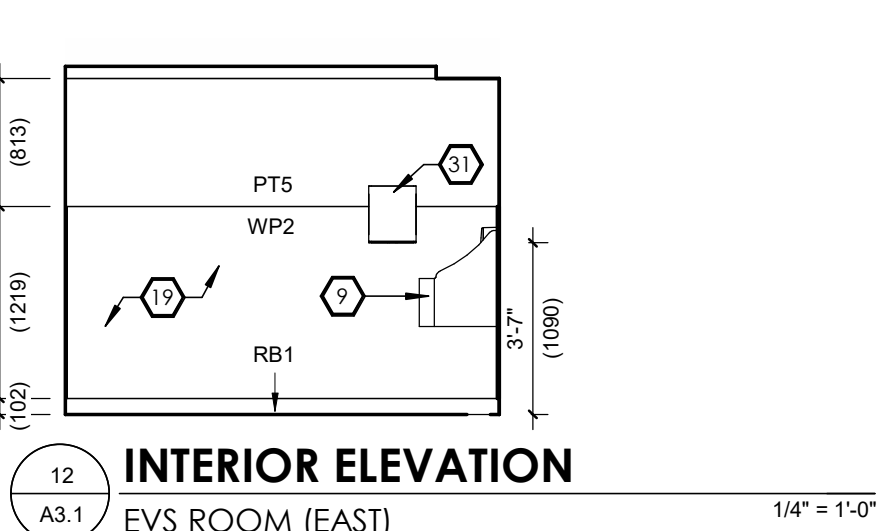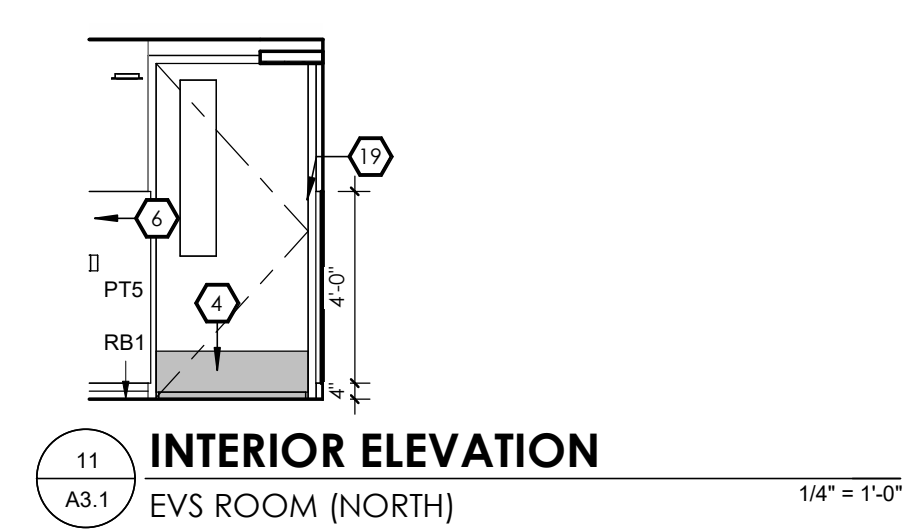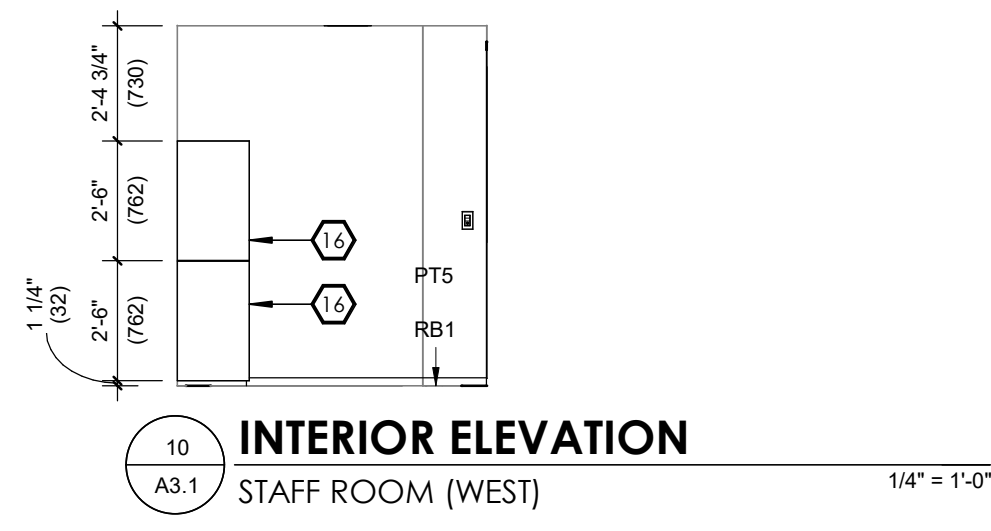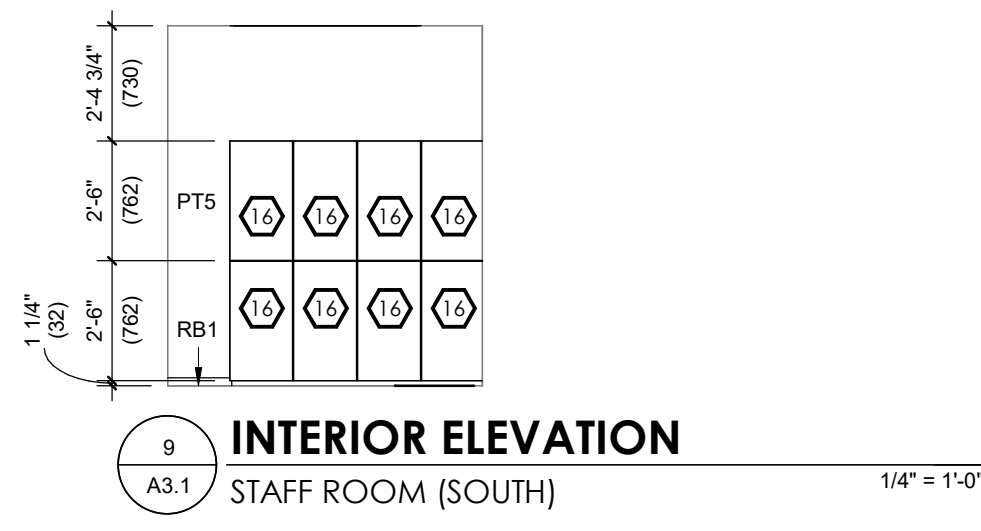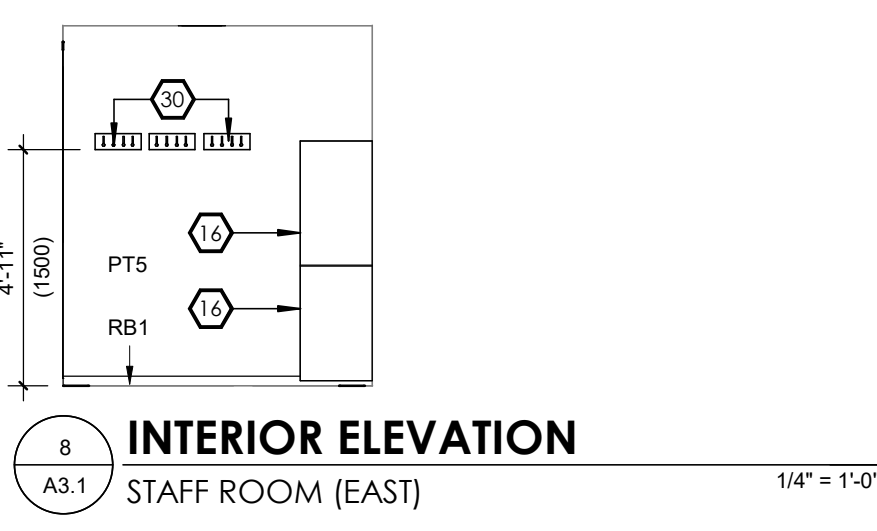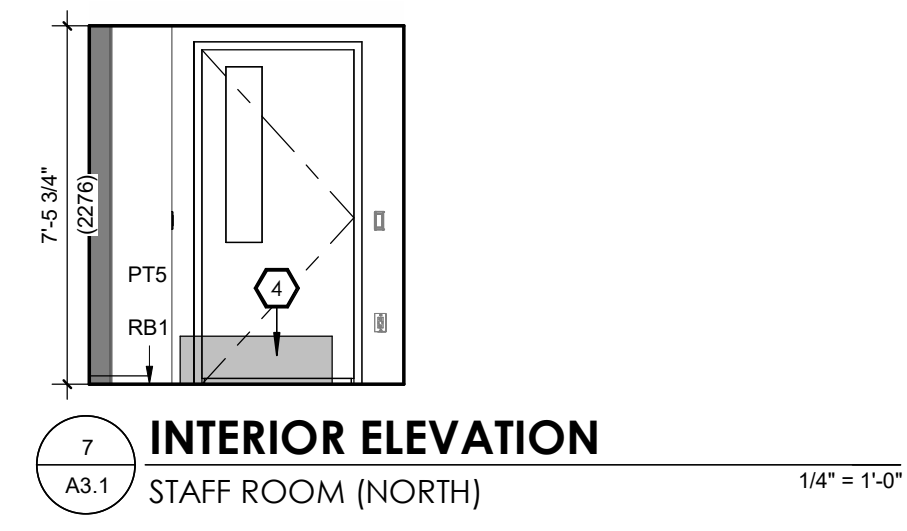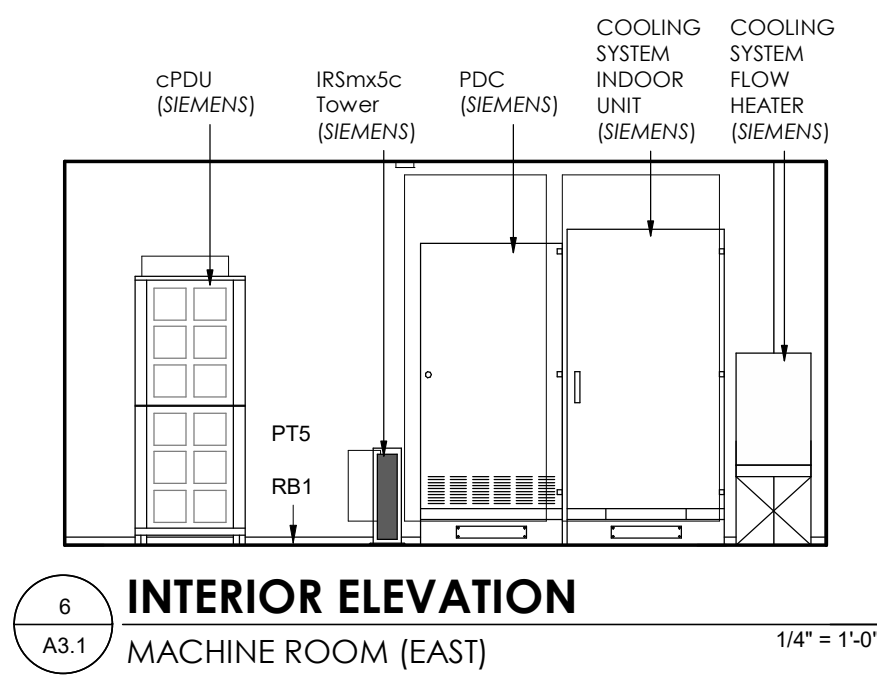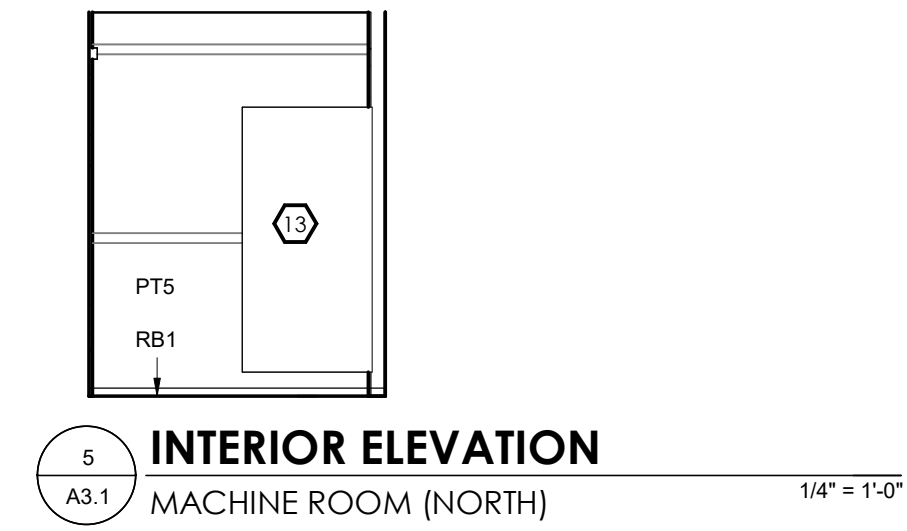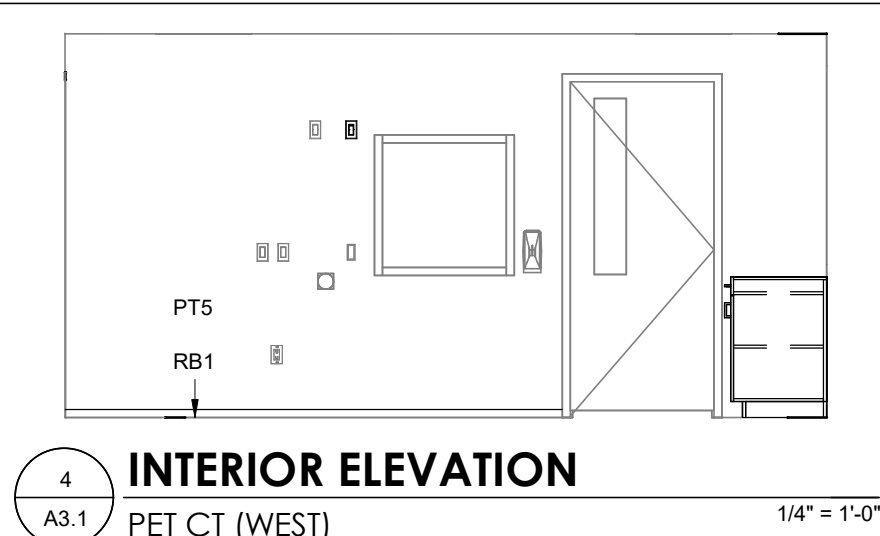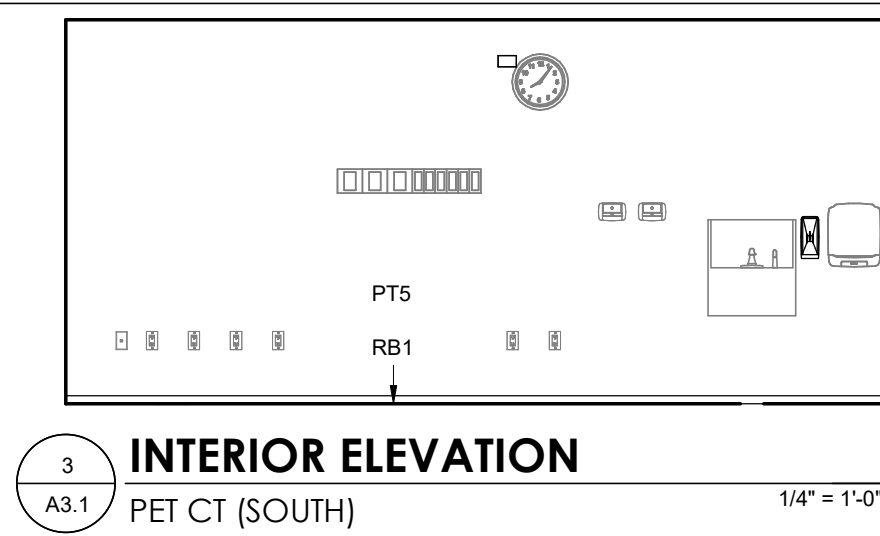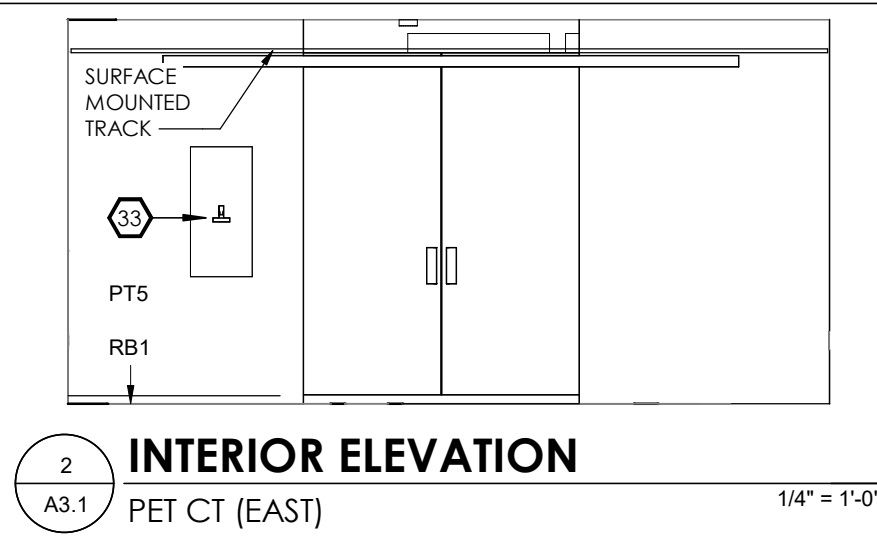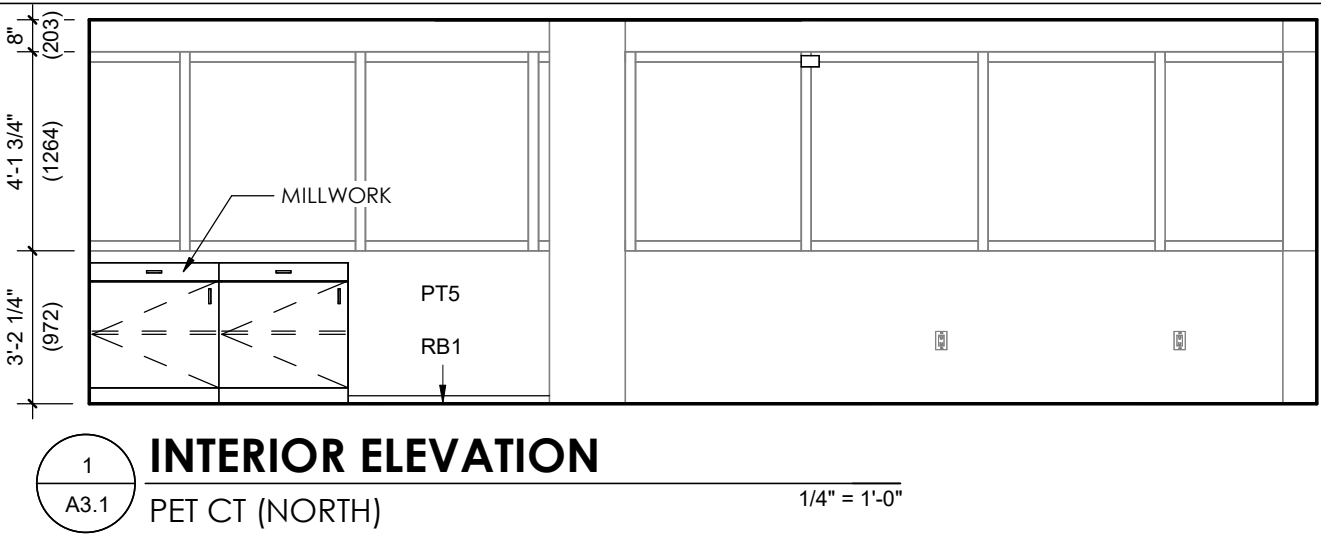

KEYNOTES:									
1	HEADWALL WITH OXYGEN AND VACUUM: 2 EMERGENCY POWER OUTLETS 2 NORMAL POWER OUTLETS 1 DATA OUTLET 1 NURSE CALL EMERGENCY CALL 1 STANDARD CALL 1 OXYGEN OUTLET 1 VACUUM OUTLET	5	HALLWAY MIRROR THAT SHOWS 3 PATHS OF TRAVEL. MOUNTED TO CEILING; COORDINATE WITH OTHER CEILING MOUNTED DEVICES	11	EXISTING CEILING LIFT TO BE RELOCATED FOR EQUIPMENT.	17	CLEANING CHEMICAL DISPENSER	23	SILENTIA - FIXED SCREEN LONG PANEL DAYLIGHT, DAYLIGHT 2.4 M (L) X 1.85M (H) DEPTH AND WIDTH: FOLDED WALL DISTANCE 0 M WEIGHT 15.3 KG PRODUCT ART. NO. 04355-D SUPPLIED AND INSTALLED BY OWNER
2	NEW NURSE CALL DOME LIGHT, CENTERED ABOVE DOOR FRAME	6	WIRELESS ACCESS POINT - DATA CONNECTION (CEILING)	12	EXISTING O2 AND VACUUM TO REMAIN, NURSE CALL TO REMAIN, MEDICAL AIR TO REMAIN.	18	STEEL SHELVING, PRODUCT OF ULINE 6 FT (L) X 3 FT (W) X 1.5 FT (D) - SUPPLIED AND INSTALLED BY OWNER	24	INSTALL STUD WALL HOARDING AT END OF WORK
3	NEW CEILING MOUNTED NURSE CALL DISPLAY, COORDINATE WITH OTHER CEILING MOUNTED DEVICES	7	FULL HEIGHT WALL PROTECTION (WP3), REFER TO INTERIOR ELEVATIONS AND ROOM FINISH SCHEDULE FOR DETAILS.	13	FOR EQUIPMENTS - REFER TO SIEMENS DRAWING FOR DETAILS.	19	WALL PROTECTION TO 4'-0\"	25	REMOVE DRYWALL, ADD LEAD SHEETING, REPLACE WITH NEW DRYWALL AND FINISH TO MATCH ADJACENT SURFACES
4	ALUMINUM PROTECTION ON ALL DOOR FRAMES, 10\"	8	IPAC DEEP HAND WASHING SINK - SENSOR FAUCET DIRECTLY CONNECTED TO POWER - NO BATTERY. (TYP.) REFER TO MECH AND ELEC DRAWINGS FOR DETAILS.	14	NEW BLINDS TO MATCH BASE BUILDING STANDARD	20	NEW WALL MT. HAND RAIL (HRB-4C)	26	2\"
		9	EMERGENCY NURSE CALL AND STANDARD NURSE CALL PULL CORD.	15	EMERGENCY EYE WASH SINK.	21	SANITARY NAPKIN DISPOSAL	27	BLANKET WARMER, SUPPLIED AND INSTALLED BY OWNER
		10		16	NEW STAFF LOCKER, REFER TO INTERIOR ELEVATIONS	22	WALL MOUNTED STAINLESS STEEL SHELF 100 D X 305 L MOUNTED BETWEEN 900-1000MM AFF	28	SOAP DISPENSER, OWNER SUPPLIED, INSTALLED BY CONTRACTOR
								29	HAND SANITIZER, OWNER SUPPLIED, INSTALLED BY CONTRACTOR
								30	NEW WALL MT. STAINLESS STEEL COAT HOOKS
								31	PAPER TOWEL DISPENSER, OWNER SUPPLIED, INSTALLED BY CONTRACTOR
								32	GRAB BAR (REFER TO A1.1 & A1.4 - TYPICAL DETAILS)
								33	REFER TO ELECTRICAL.
								34	SHARPS CONTAINER, OWNER SUPPLIED, INSTALLED BY CONTRACTORS
								35	SOILED LINEN HAMPER
								36	MIRROR WITH TASK LIGHT ABOVE
								37	MOP SINK
								38	RECESSED SS CORNER GUARD, REFER SPECS
								39	ROOFTOP GUARD RAIL, REFER SPECS

Waterloo Regional Health Network

PROJECT LOGO

AREA OF WORK

KEY PLAN

ISSUED FOR TENDER (2026.02.27)

8	ISSUED FOR TENDER	2026-02-27
7	RE - ISSUED FOR PERMIT	2026-02-25
6	ISSUED FOR TENDER	2025-12-12
5	ISSUED FOR PERMIT	2025-11-28
4	FINAL DESIGN DEVELOPMENT SET	2025-11-07
3	FINAL DESIGN DEVELOPMENT SET	2025-10-31
2	100% DESIGN DEVELOPMENT SET	2025-09-29
1	50% DESIGN DEVELOPMENT SET	2025-05-09
No.	DESCRIPTION	DATE
REVISIONS		
		2025-09-29

DISCREPANCIES MUST BE REPORTED IMMEDIATELY TO THE ARCHITECT / ENGINEER BEFORE PROCEEDING.

ONLY FIGURED DIMENSIONS MUST BE USED.

THE CONTRACTOR MUST CHECK THE DIMENSIONS ON SITE.

THE DRAWING IS PROTECTED BY COPYRIGHT.

ALL DIMENSIONS ARE SHOWN IN MILLIMETERS.

DO NOT SCALE THE DRAWINGS.

mcCallumSather

Westinghouse HQ, 2nd Floor
286 Sanford Ave. N
Hamilton, ON L8L 6A1
905.526.6700
www.mccallumsather.com

ONARIO ASSOCIATION OF ARCHITECTS
GREEN LAMETER
LICENCE 4772

SEAL

CONSULTANTS:

PROJECT:

WATERLOO REGIONAL HEALTH NETWORK @ MIDTOWN - PET CT

835 KING ST W, KITCHENER, ON N2G 1G3





















DRAWING TITLE:

PROPOSED INTERIOR ELEVATIONS

DRAWN BY:	SB	DATE:	2025.10.31
CHECKED BY:	GL	SCALE:	1/4" = 1'-0"

PROJECT NO. **24048**


DRAWING NO. **A3.1**

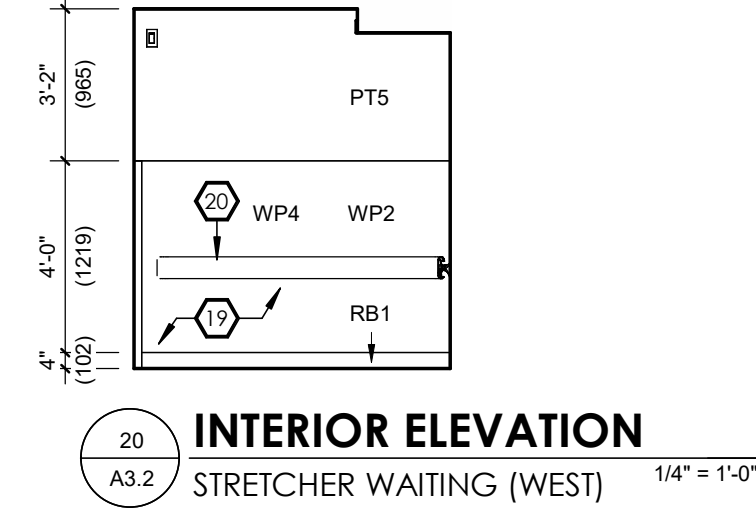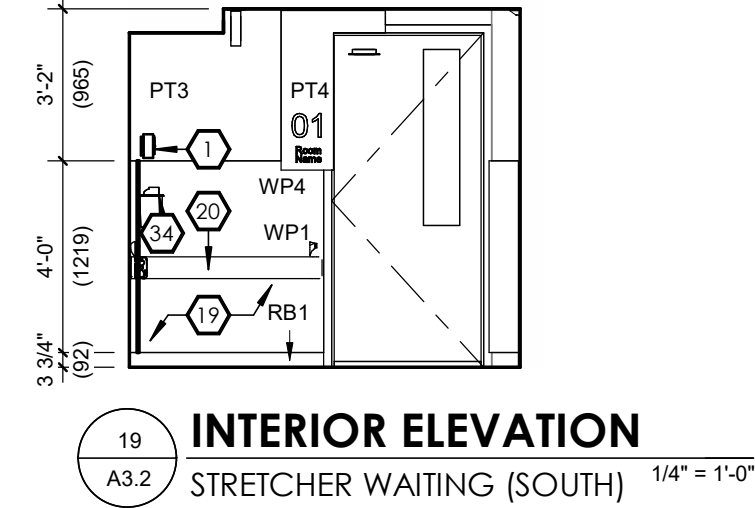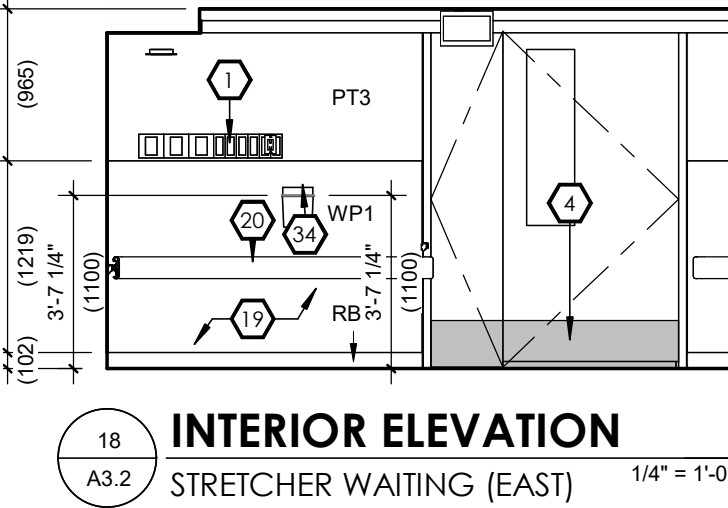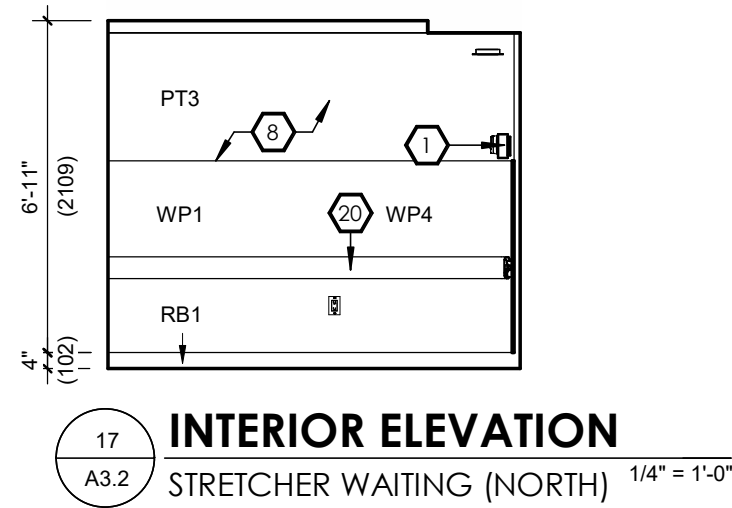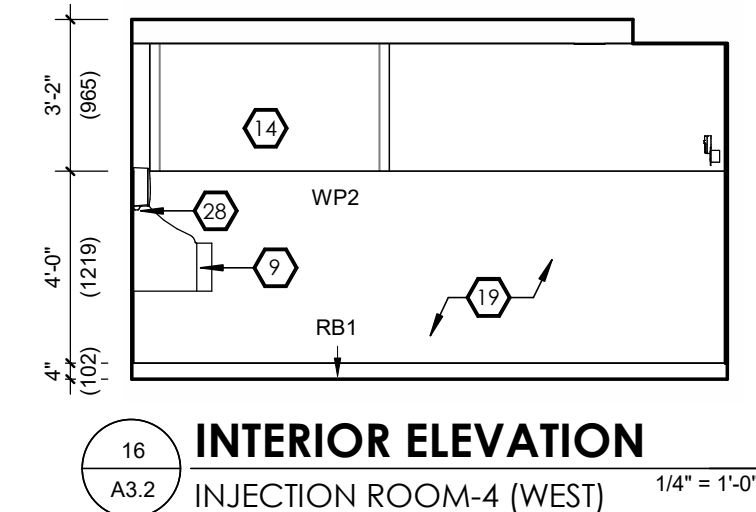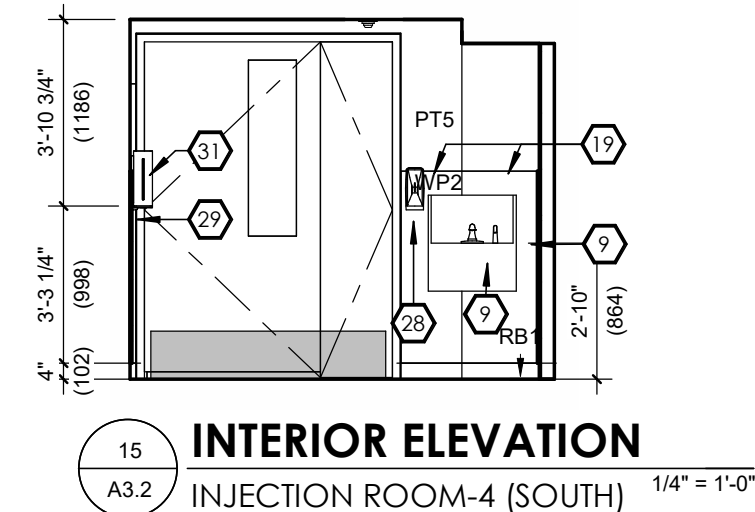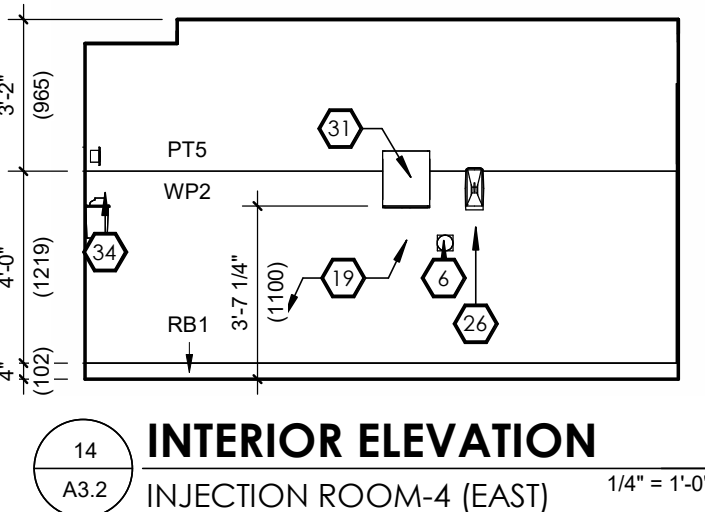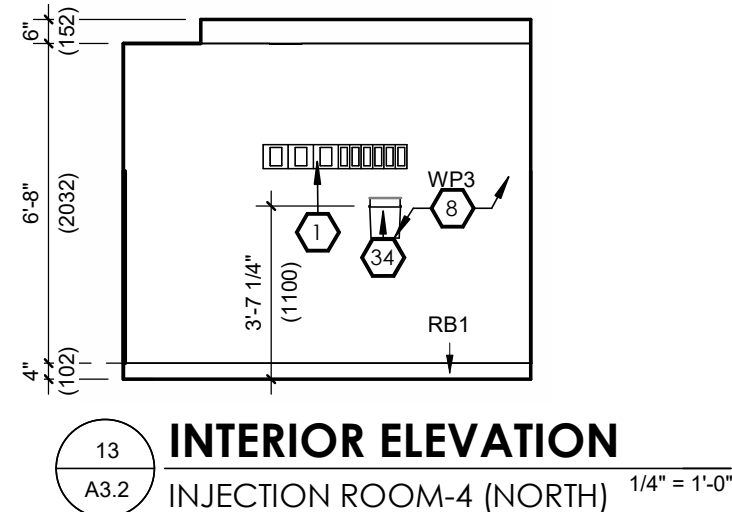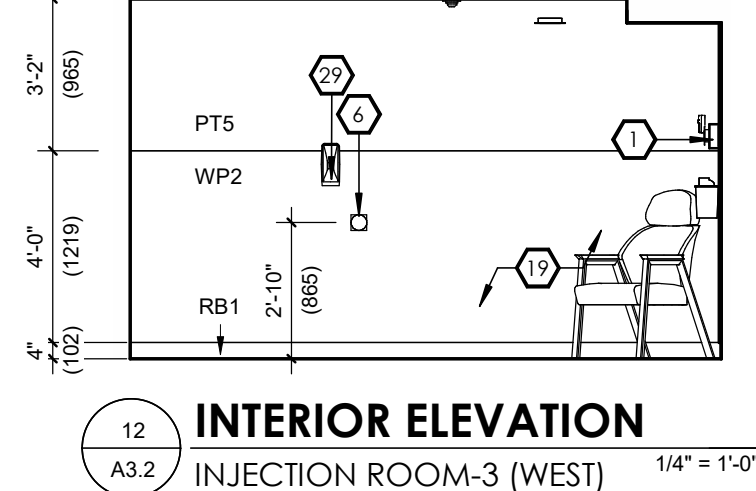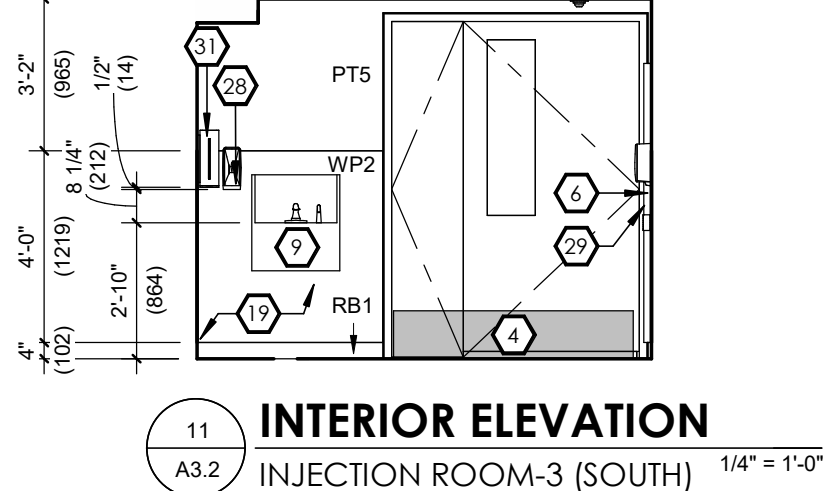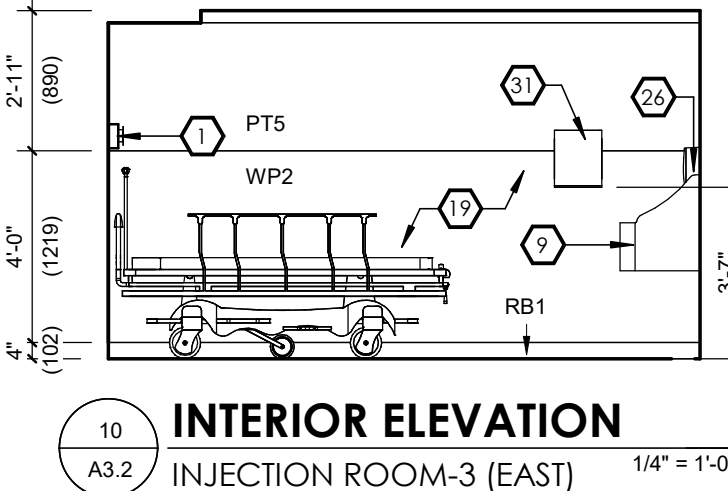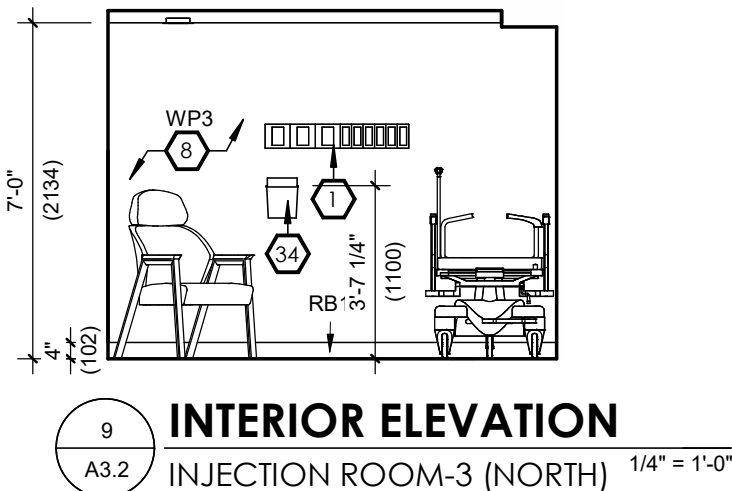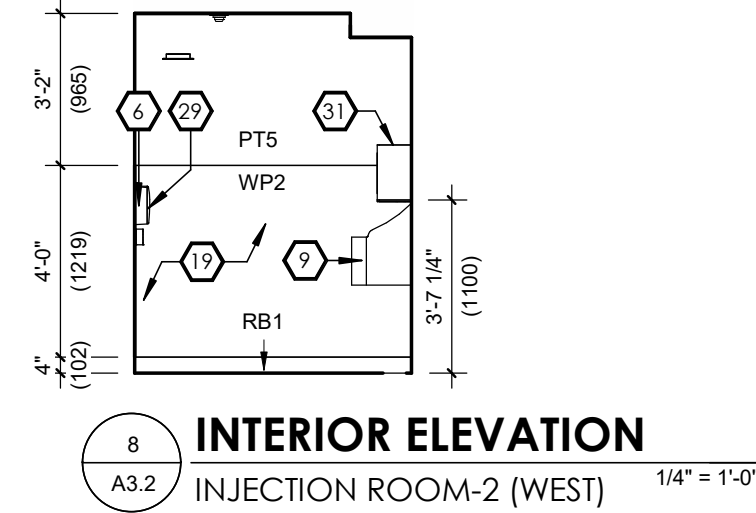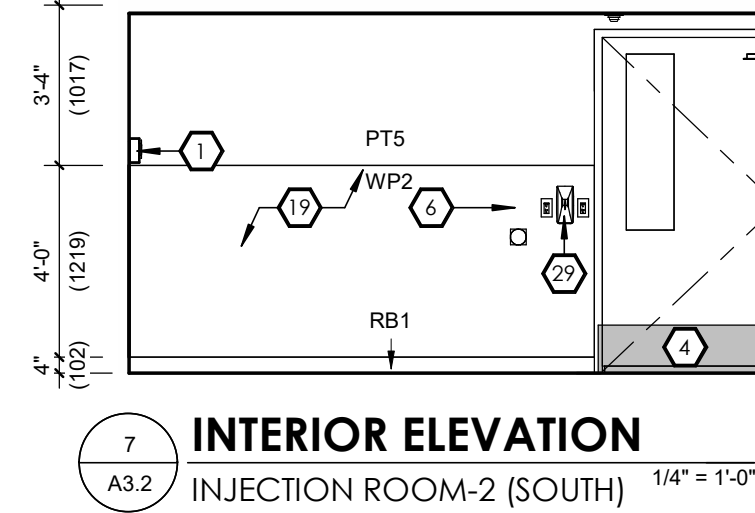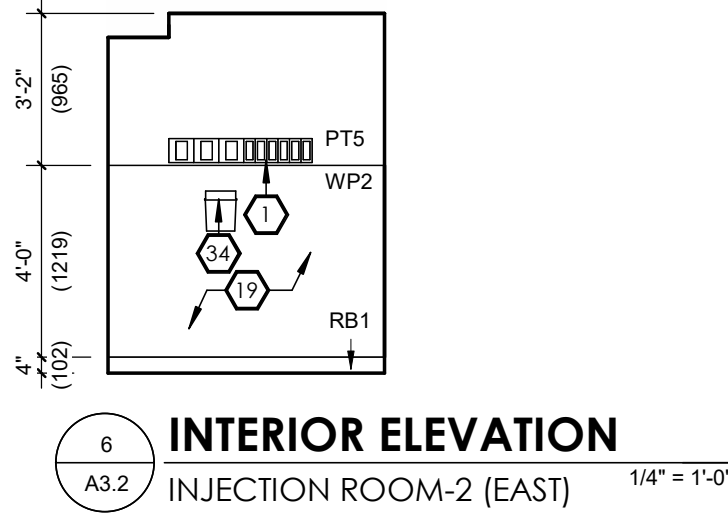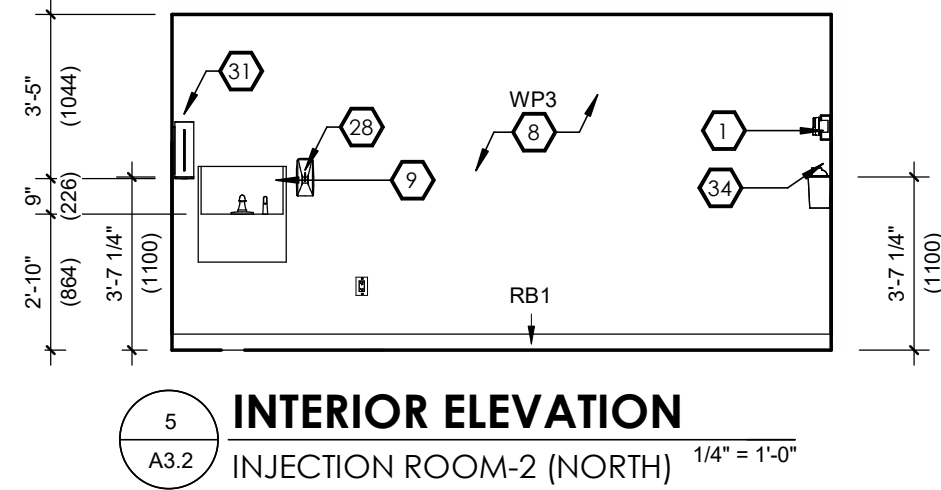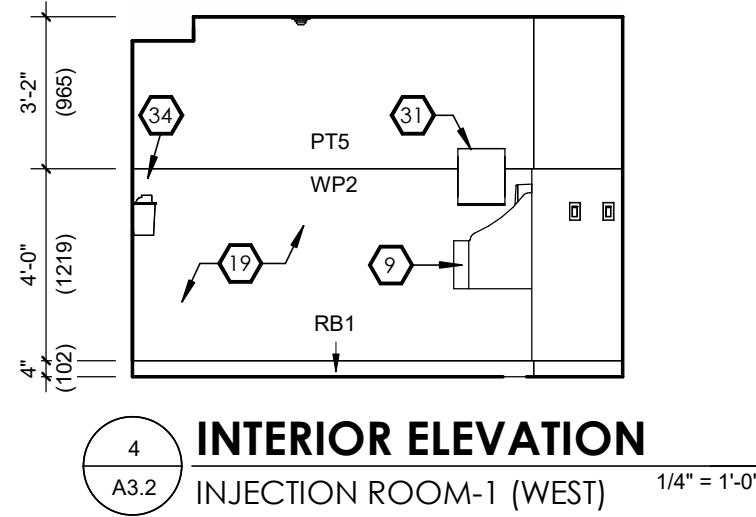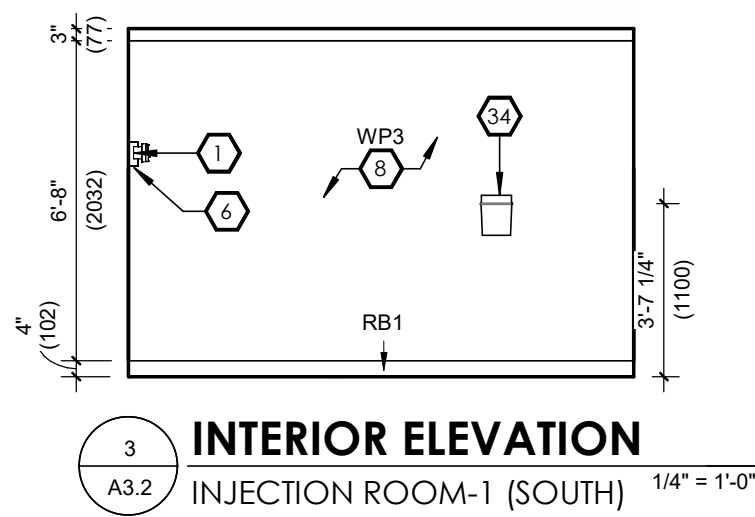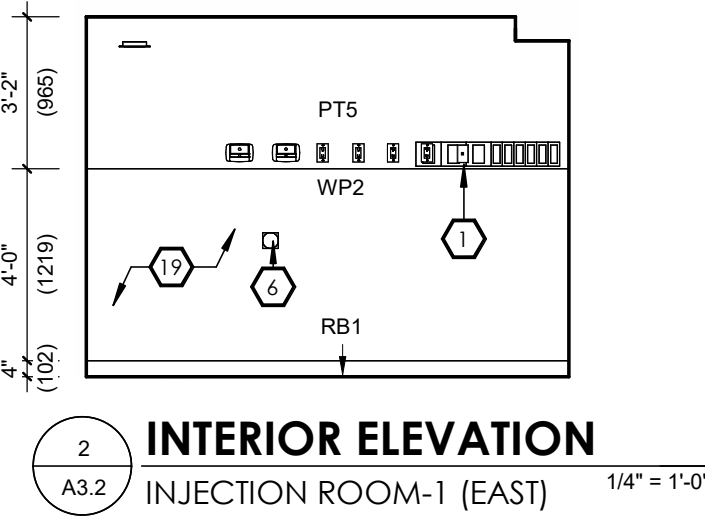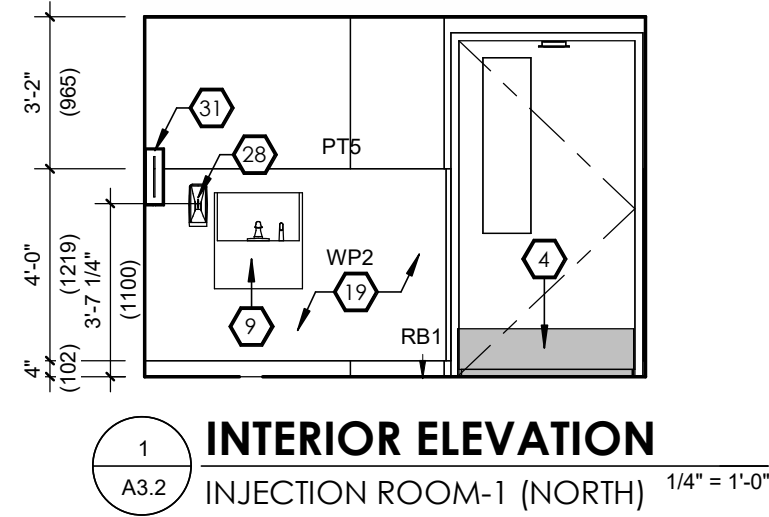

KEYNOTES:

- | | | | | | | | |
|---|---|---|--|--|---|---|------------------------------------|
| 1 HEADWALL WITH OXYGEN AND VACUUM: <ul style="list-style-type: none">2 EMERGENCY POWER OUTLETS2 NORMAL POWER OUTLETS1 DATA OUTLET1 NURSE CALL EMERGENCY CALL1 STANDARD CALL1 OXYGEN OUTLET1 VACUUM OUTLET | 5 HALLWAY MIRROR THAT SHOWS 3 PATHS OF TRAVEL. MOUNTED TO CEILING; COORDINATE WITH OTHER CEILING MOUNTED DEVICES | 11 EXISTING CEILING LIFT TO BE RELOCATED FOR EQUIPMENT. | 17 CLEANING CHEMICAL DISPENSER | 23 SILENTIA - FIXED SCREEN LONG PANEL DAYLIGHT; DAYLIGHT 2.4 M (L) X 1.85M (H) DEPTH AND WIDTH: FOLDED WALL DISTANCE 0 M WEIGHT 15.3 KG PRODUCT ART: NO. 04355-D SUPPLIED AND INSTALLED BY OWNER | 26 2" FURRING WALL TO ACCOMMODATE ELECTRICAL PANEL | 32 GRAB BAR (REFER TO A1.1 & A1.4 - TYPICAL DETAILS) | 39 ROOFTOP GUARD RAIL, REFER SPECS |
| 2 NEW NURSE CALL DOME LIGHT, CENTERED ABOVE DOOR FRAME | 6 WIRELESS ACCESS POINT - DATA CONNECTION (CEILING) | 12 EXISTING O2 AND VACUUM TO REMAIN, NURSE CALL TO REMAIN, MEDICAL AIR TO REMAIN. | 18 STEEL SHELVING, PRODUCT OF ULINE 6 FT (L) X 3 FT (W) X 1.5 FT (D) - SUPPLIED AND INSTALLED BY OWNER | 24 INSTALL STUD WALL HOARDING AT END OF WORK | 27 BLANKET WARMER, SUPPLIED AND INSTALLED BY OWNER | 33 REFER TO ELECTRICAL | |
| 3 NEW CEILING MOUNTED NURSE CALL DISPLAY, COORDINATE WITH OTHER CEILING MOUNTED DEVICES | 8 FULL HEIGHT WALL PROTECTION (WP3), REFER TO INTERIOR ELEVATIONS AND ROOM FINISH SCHEDULE FOR DETAILS. | 13 FOR EQUIPMENTS - REFER TO SIEMENS DRAWING | 19 WALL PROTECTION TO 4'-0" HIGH, REFER TO INTERIOR ELEVATIONS AND ROOM FINISH SCHEDULE FOR DETAILS. | 25 REMOVE DRYWALL, ADD LEAD SHEETING, REPLACE WITH NEW DRYWALL AND FINISH TO MATCH ADJACENT SURFACES | 28 SOAP DISPENSER, OWNER SUPPLIED, INSTALLED BY CONTRACTOR | 34 SHARPS CONTAINER, OWNER SUPPLIED, INSTALLED BY CONTRACTORS | |
| 4 ALUMINUM PROTECTION ON ALL DOOR FRAMES, 10" KICK PLATES TO BE ALUMINUM. (TYP.) | 9 IPAC DEEP HAND WASHING SINK - SENSOR FAUCET DIRECTLY CONNECTED TO POWER - NO BATTERY. (TYP.) REFER TO MECH AND ELEC DRAWINGS FOR DETAILS. | 14 NEW BLINDS TO MATCH BASE BUILDING STANDARD | 20 NEW WALL MT. HAND RAIL (HRB-4C) | | 29 HAND SANITIZER, OWNER SUPPLIED, INSTALLED BY CONTRACTOR | 35 SOILED LINEN HAMPER | |
| | 10 EMERGENCY NURSE CALL AND STANDARD NURSE CALL PULL CORD. | 15 EMERGENCY EYE WASH SINK. | 21 SANITARY NAPKIN DISPOSAL | | 30 NEW WALL MT. STAINLESS STEEL COAT HOOKS | 36 MIRROR WITH TASK LIGHT ABOVE | |
| | | | 22 WALL MOUNTED STAINLESS STEEL SHELF 100 D X 305 L MOUNTED BETWEEN 900-1000MM AFF | | 31 PAPER TOWEL DISPENSER, OWNER SUPPLIED, INSTALLED BY CONTRACTOR | 37 MOP SINK | |
| | | | | | | 38 RECESSED SS CORNER GUARD, REFER SPECS | |

PROJECT LOGO

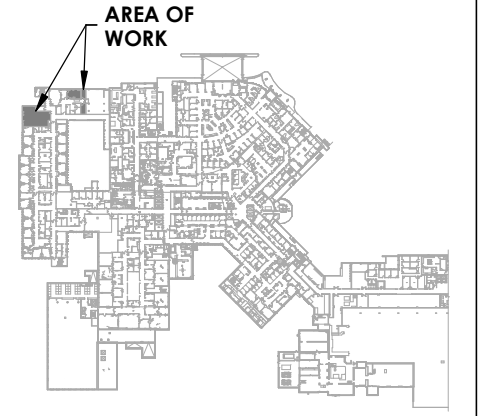

KEY PLAN

ISSUED FOR TENDER
(2026.02.27)

8	ISSUED FOR TENDER	2026-02-27
7	RE - ISSUED FOR PERMIT	2026-02-25
6	ISSUED FOR TENDER	2025-12-12
5	ISSUED FOR PERMIT	2025-11-28
4	FINAL DESIGN DEVELOPMENT SET	2025-11-07
3	FINAL DESIGN DEVELOPMENT SET	2025-10-31
2	100% DESIGN DEVELOPMENT PROGRESS SET	2025-09-29
1	50% DESIGN DEVELOPMENT PROGRESS SET	2025-05-09
No.	DESCRIPTION	DATE

DISCREPANCIES MUST BE REPORTED IMMEDIATELY TO THE ARCHITECT / ENGINEER BEFORE PROCEEDING.
ONLY FIGURED DIMENSIONS MUST BE USED.
THE CONTRACTOR MUST CHECK THE DIMENSIONS ON SITE.
THE DRAWING IS PROTECTED BY COPYRIGHT.
ALL DIMENSIONS ARE SHOWN IN MILLIMETERS.
DO NOT SCALE THE DRAWINGS.

mcCallumSather
Westinghouse HQ, 2nd Floor
286 Sanford Ave. N
Hamilton, ON L8L 6A1
905.526.6700
www.mccallumsather.com



SEAL

CONSULTANTS:

PROJECT:
**WATERLOO REGIONAL HEALTH
NETWORK @ MIDTOWN - PET CT**


**835 KING ST W, KITCHENER, ON
N2G 1G3**

**PROPOSED INTERIOR
ELEVATIONS**


DRAWN BY: SB DATE: 2025.10.31
CHECKED BY: GL SCALE: 1/4" = 1'-0"

PROJECT NO: **24048**


DRAWING NO: **A3.2**

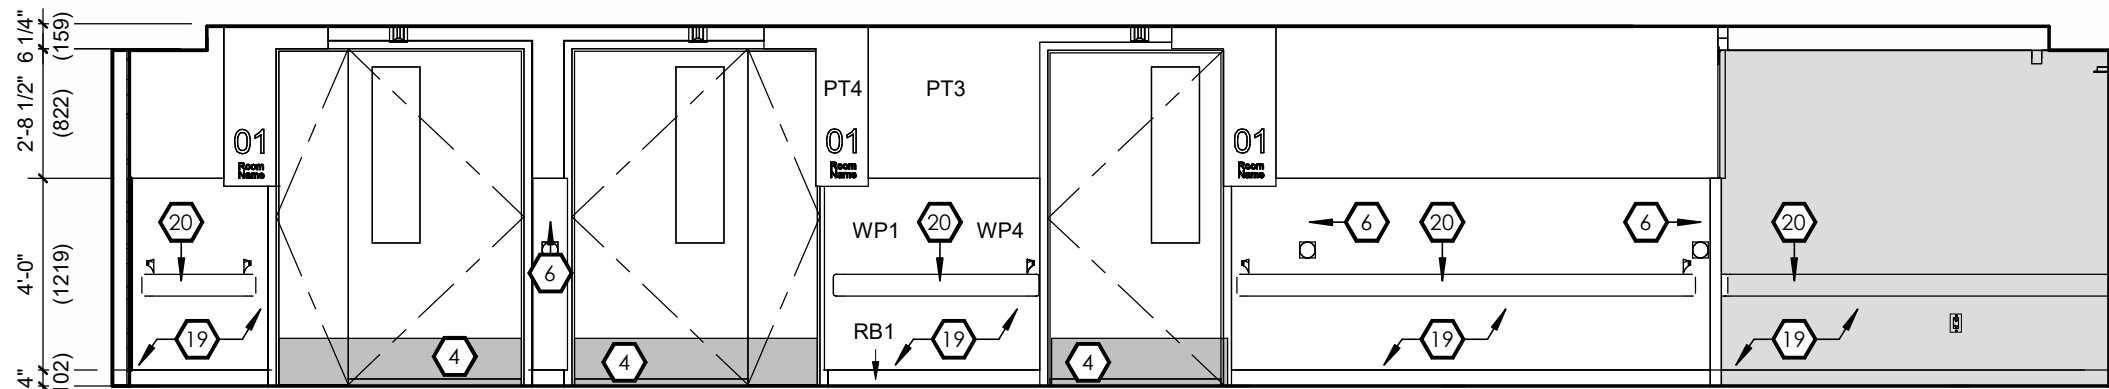


1
A3.3
INTERIOR ELEVATION
CORRIDOR (NORTH)
1/4" = 1'-0"

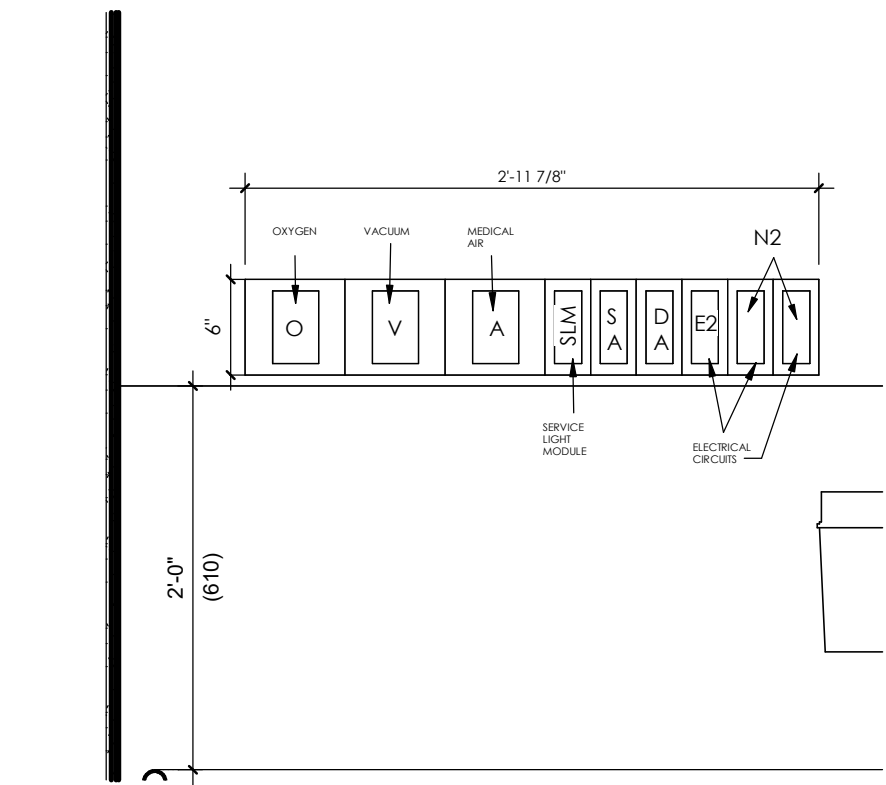


2
A3.3
ENLARGED HEADWALL
1" = 1'-0"

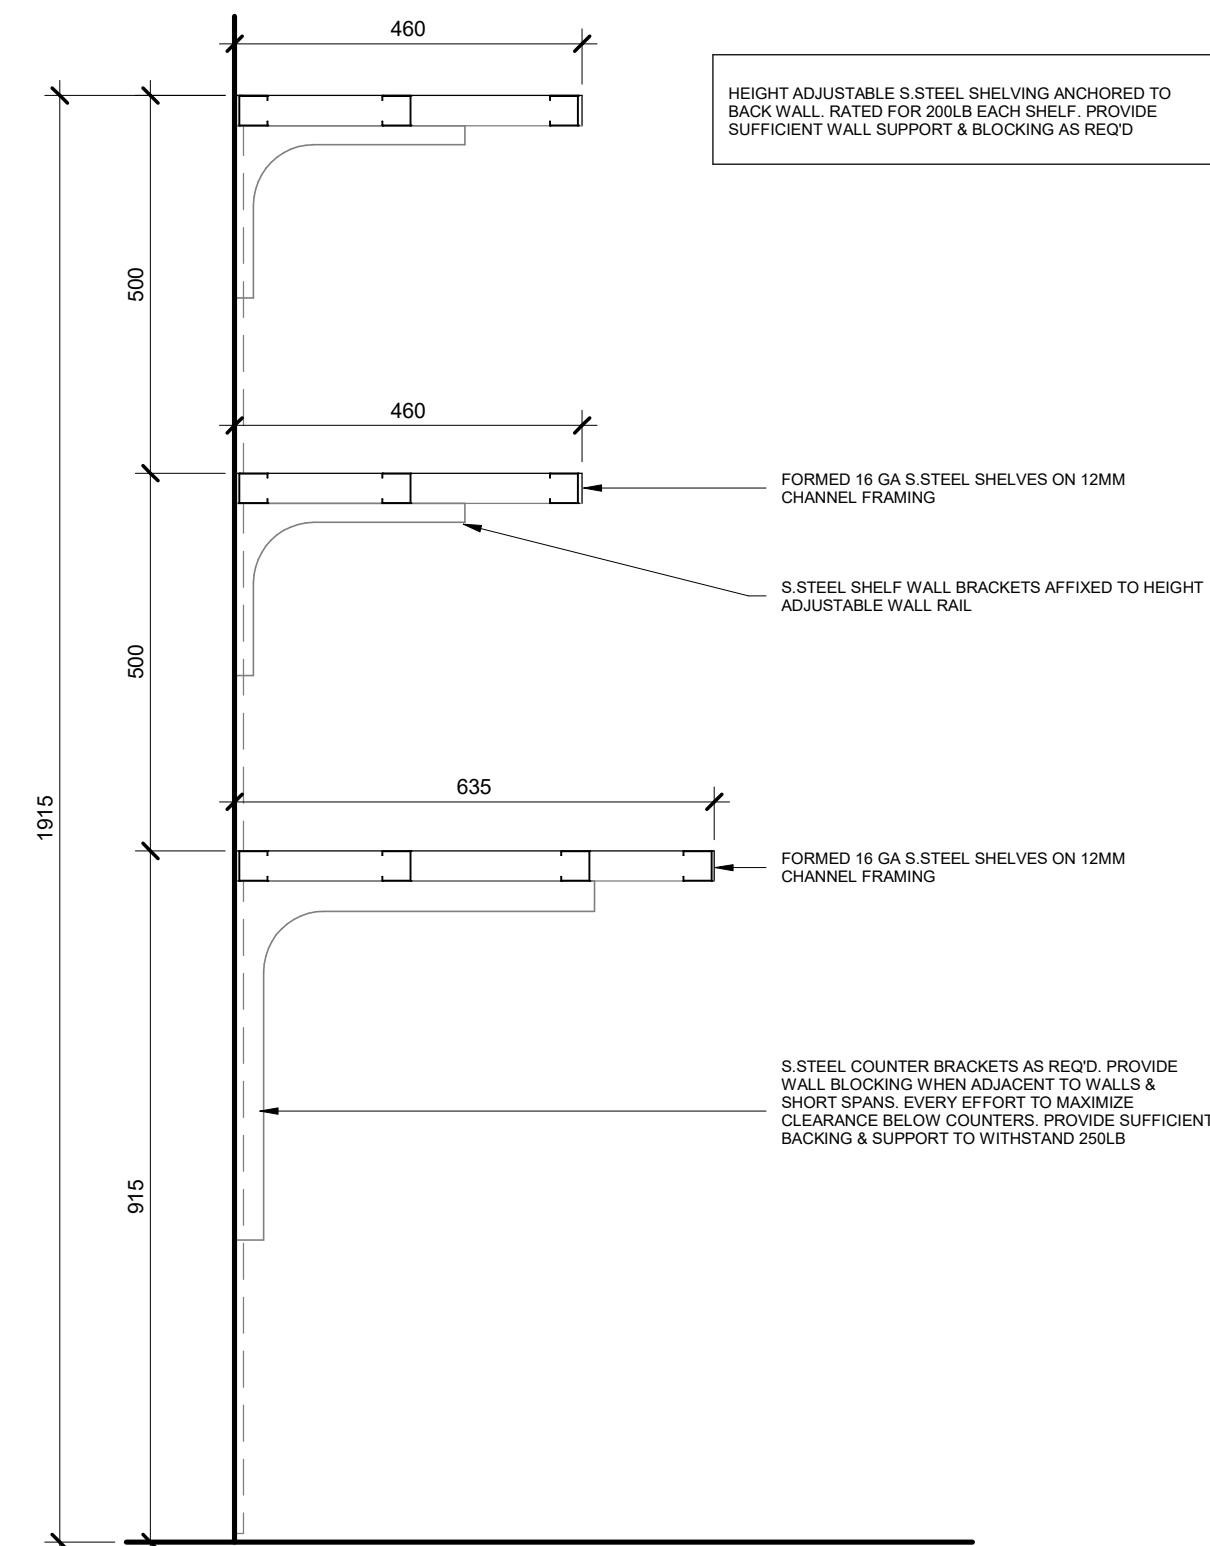


5
A3.3
SS-SHELF - STAINLESS STEEL STORAGE SHELVING
1 : 10

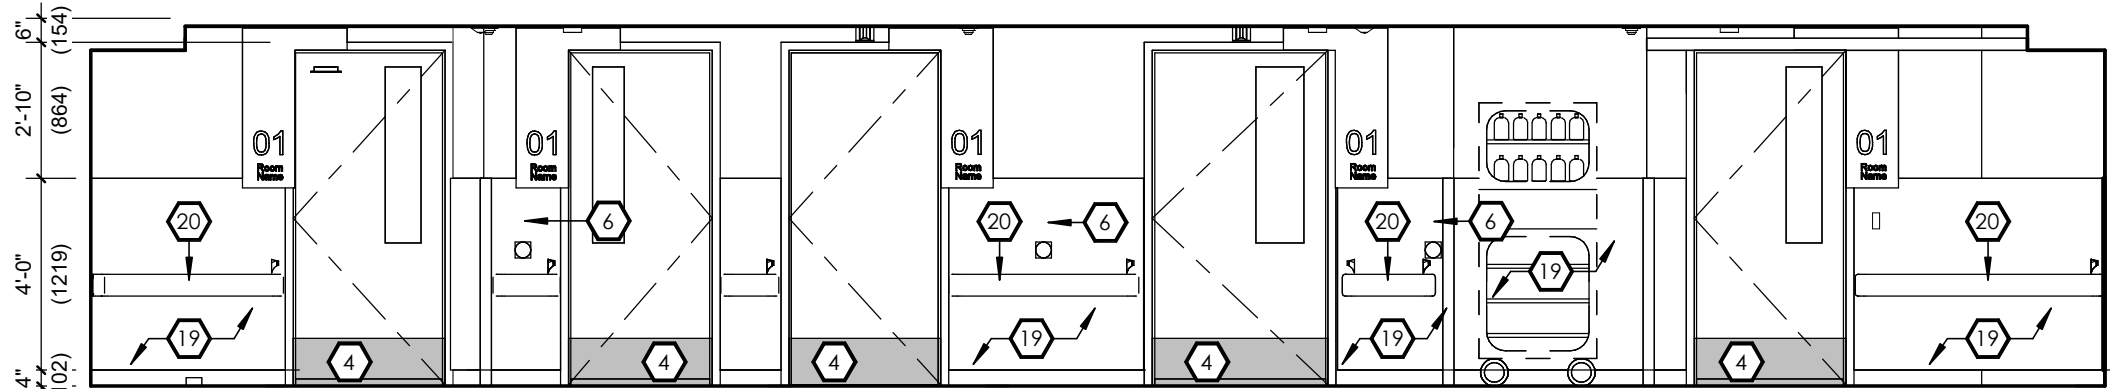

3
A3.3
INTERIOR ELEVATION
CORRIDOR (SOUTH)
1/4" = 1'-0"

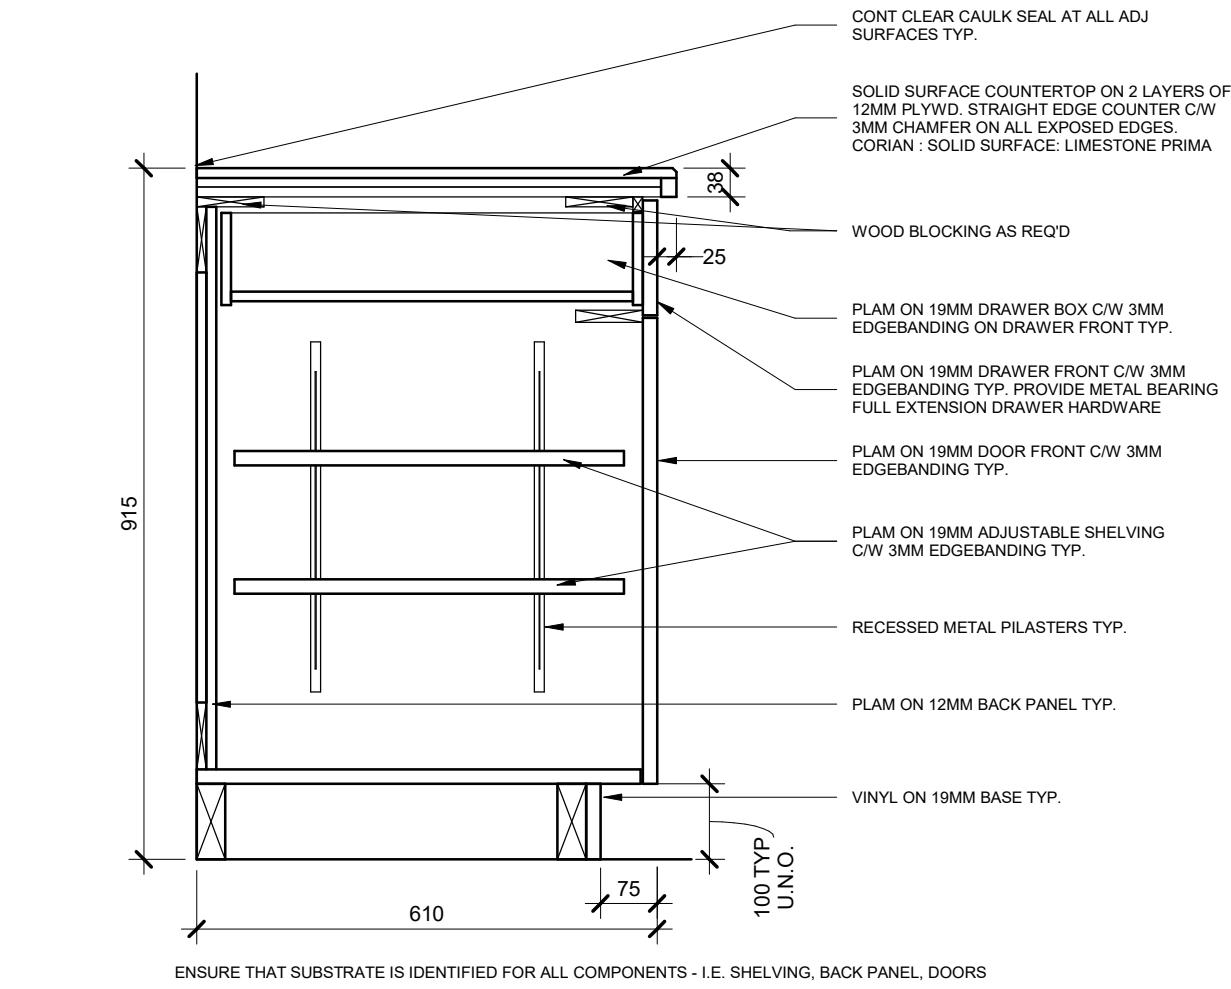

4
A3.3
LC-ID - LOWER CABINET W/ 1 DRAWER
1 : 10

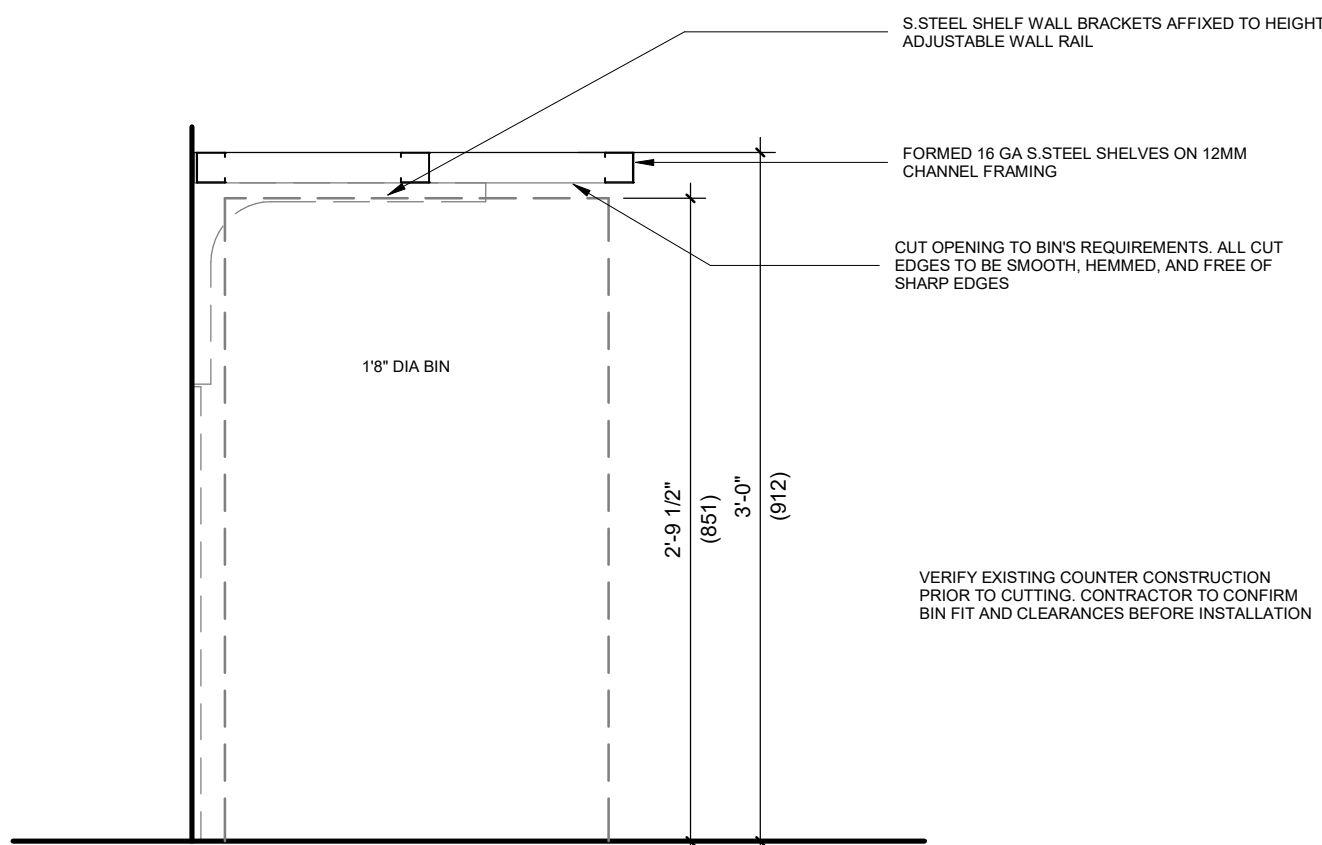


6
A3.3
SS- MILLWORK IN HOTLAB
1 : 10

KEYNOTES:

- HEADWALL WITH OXYGEN AND VACUUM:
 - 2 EMERGENCY POWER OUTLETS
 - 2 NORMAL POWER OUTLETS
 - 1 DATA OUTLET
 - 1 NURSE CALL EMERGENCY CALL
 - 1 STANDARD CALL
 - 1 OXYGEN OUTLET
 - 1 VACUUM OUTLET
- NEW NURSE CALL DOME LIGHT, CENTERED ABOVE DOOR FRAME
- NEW CEILING MOUNTED NURSE CALL DISPLAY, COORDINATE WITH OTHER CEILING MOUNTED DEVICES
- ALUMINUM PROTECTION ON ALL DOOR FRAMES, 10" KICK PLATES TO BE ALUMINUM, (TYP.)
- HALLWAY MIRROR THAT SHOWS 3 PATHS OF TRAVEL, MOUNTED TO CEILING; COORDINATE WITH OTHER CEILING MOUNTED DEVICES
- AUTOMATIC DOOR OPENER
- WIRELESS ACCESS POINT - DATA CONNECTION (CEILING)
- FULL HEIGHT WALL PROTECTION (WP3), REFER TO INTERIOR ELEVATIONS AND ROOM FINISH SCHEDULE FOR DETAILS
- IPAC DEEP HAND WASHING SINK - SENSOR FAUCET DIRECTLY CONNECTED TO POWER - NO BATTERY, (TYP.) REFER TO MECH AND ELEC DRAWINGS FOR DETAILS
- EMERGENCY NURSE CALL AND STANDARD NURSE CALL PULL CORD
- EXISTING CEILING LIFT TO BE RELOCATED FOR EQUIPMENT
- EXISTING O2 AND VACUUM TO REMAIN, NURSE CALL TO REMAIN, MEDICAL AIR TO REMAIN
- FOR EQUIPMENTS - REFER TO SIEMENS DRAWING FOR DETAILS
- NEW BLINDS TO MATCH BASE BUILDING STANDARD
- EMERGENCY EYE WASH SINK
- NEW STAFF LOCKER, REFER TO INTERIOR ELEVATIONS
- CLEANING CHEMICAL DISPENSER
- STEEL SHELVING, PRODUCT OF ULINE 6 ft (L) x 3 ft (W) x 1.5 ft (D) - SUPPLIED AND INSTALLED BY OWNER
- WALL PROTECTION TO 4'-0" HIGH, REFER TO INTERIOR ELEVATIONS AND ROOM FINISH SCHEDULE FOR DETAILS
- NEW WALL MT. HAND RAIL (HRB-4C)
- SANITARY NAPKIN DISPOSAL
- WALL MOUNTED STAINLESS STEEL SHELF 100 D X 305 L MOUNTED BETWEEN 900-1000MM AFF
- SILENTIA - FIXED SCREEN LONG PANEL WALL, STANDARD DAYLIGHT, DAYLIGHT 2.4 M (L) X 1.85M (H) DEPTH AND WIDTH: FOLDED WALL DISTANCE 0 M WEIGHT 15.3 KG PRODUCT ART. NO. 04355-D SUPPLIED AND INSTALLED BY OWNER
- INSTALL STUD WALL HOARDING AT END OF WORK
- REMOVE DRYWALL, ADD LEAD SHEETING, REPLACE WITH NEW DRYWALL AND FINISH TO MATCH ADJACENT SURFACES
- 2" FURRING WALL TO ACCOMMODATE ELECTRICAL PANEL
- BLANKET WARMER, SUPPLIED AND INSTALLED BY OWNER
- SOAP DISPENSER, OWNER SUPPLIED, INSTALLED BY CONTRACTOR
- HAND SANITIZER, OWNER SUPPLIED, INSTALLED BY CONTRACTOR
- NEW WALL MT. STAINLESS STEEL COAT HOOKS
- PAPER TOWEL DISPENSER, OWNER SUPPLIED, INSTALLED BY CONTRACTOR
- GRAB BAR (REFER TO A1.1 & A1.4 - TYPICAL DETAILS)
- REFER TO ELECTRICAL
- SHARPS CONTAINER, OWNER SUPPLIED, INSTALLED BY CONTRACTORS
- SOILED LINEN HAMPER
- MIRROR WITH TASK LIGHT ABOVE
- MOP SINK
- RECESSED SS CORNER GUARD, REFER SPECS
- ROOFTOP GUARD RAIL, REFER SPECS



PROJECT LOGO

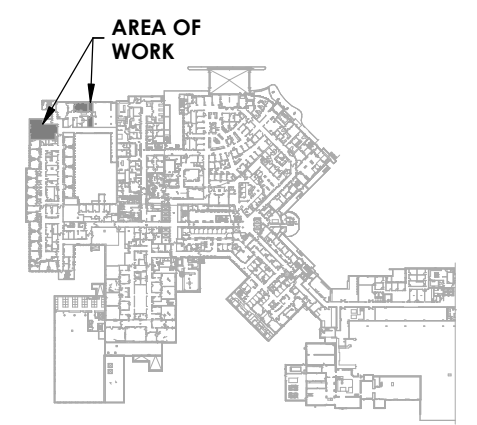

KEY PLAN

ISSUED FOR TENDER
(2026.02.27)

8	ISSUED FOR TENDER	2026-02-27
7	RE- ISSUED FOR PERMIT	2026-02-25
6	ISSUED FOR TENDER	2025-12-12
5	ISSUED FOR PERMIT	2025-11-28
4	FINAL DESIGN DEVELOPMENT SET	2025-11-07
3	FINAL DESIGN DEVELOPMENT SET	2025-10-31
2	100% DESIGN DEVELOPMENT PROGRESS SET	2025-09-29
1	50% DESIGN DEVELOPMENT PROGRESS SET	2025-05-09
No.	DESCRIPTION	DATE

REVISIONS: 2025.09.29

DISCREPANCIES MUST BE REPORTED IMMEDIATELY TO THE ARCHITECT / ENGINEER BEFORE PROCEEDING.

ONLY FIGURED DIMENSIONS MUST BE USED.

THE CONTRACTOR MUST CHECK THE DIMENSIONS ON SITE.

THE DRAWING IS PROTECTED BY COPYRIGHT.

ALL DIMENSIONS ARE SHOWN IN MILLIMETERS.

DO NOT SCALE THE DRAWINGS.

mcCallumSather
Westinghouse HQ, 2nd Floor
286 Sanford Ave. N
Hamilton, ON L8L 6A1
905.526.6700
www.mccallumsather.com



SEAL

CONSULTANTS:

PROJECT:
WATERLOO REGIONAL HEALTH NETWORK @ MIDTOWN - PET CT

835 KING ST W, KITCHENER, ON N2G 1G3

DRAWING TITLE:
PROPOSED INTERIOR ELEVATIONS AND DETAILS

DRAWN BY: SB DATE: 2025.10.31
CHECKED BY: GL SCALE: 1/4"=1'-0"

PROJECT NO: **24048**

DRAWING NO.:
A3.3