

GENERAL NOTES
1. THE CONTRACTOR SHALL CO-ORDINATE WITH THE STRUCTURAL TO PROVIDE OPENINGS AND SLEEVES THROUGH STRUCTURAL ELEMENTS WHERE REQUIRED. 2. DO NOT SCALE DRAWINGS FOR INSTALLATION PURPOSES. OBTAIN ALL DIMENSIONS FROM ARCHITECTURAL PLANS, MANUFACTURER'S SHOP DRAWINGS, AND ON SITE INSPECTIONS. 3. MECHANICAL, DIV. 2-14 AND ELECTRICAL TRADES SHALL WORK IN CONJUNCTION WITH ONE ANOTHER SO AS TO AVOID INTERFERENCE'S BETWEEN PIPING, DUCTWORK, CONDUIT, LIGHTING FIXTURES, ETC. 4. WORK SHALL BE CO-ORDINATED THROUGH THE GENERAL CONTRACTOR PRIOR TO INSTALLATION OF ANY EQUIPMENT, DUCTWORK AND CONTROLS. CO-ORDINATE WITH ARCHITECTURAL ELEVATIONS FOR ARCHITECTURAL, MECHANICAL, AND ELECTRICAL SPACE ALLOCATIONS. 5. PROPERLY SUPPORT CEILING MOUNTED EQUIPMENT AND ANY OTHER EQUIPMENT INDEPENDENT OF CEILING SUPPORT SYSTEM. REFER TO ARCHITECTURAL DETAILS AND CO-ORDINATE WITH STRUCTURAL TRADE. 6. REFER TO ARCHITECTURAL FOR OWNER SUPPLIED EQUIPMENT. CONFIRM ALL MECHANICAL REQUIREMENTS AND PROVIDE TO SUIT. 7. REVIEW ARCHITECTURAL, ELECTRICAL, AND STRUCTURAL DRAWINGS AND PROVIDE ON SITE INSPECTIONS TO DETERMINE FULL EXTENT OF PROJECT PRIOR TO SUBMITTING BID. 8. ALL INSTALLATIONS SHALL BE IN ACCORDANCE WITH CODES, BULLETINS ETC. AND REQUIREMENTS OF ALL INSPECTION AUTHORITIES FOR THE CITY OF HAMILTON. 9. CONTRACTOR IS RESPONSIBLE FOR MAINTAINING ALL MECHANICAL SERVICES TO THE OCCUPIED AREA THROUGHOUT THE PHASING OF THE WORK. PROVIDE CONSTRUCTION VALVES, TEMPORARY DUCTWORK AND PIPING AS REQUIRED TO LIMIT THE SHUT DOWN OF SERVICES TO ONE TIME. 10. REFER TO ARCHITECTURAL REFLECTED CEILING PLAN FOR CO-ORDINATION OF GRILLES, DIFFUSERS AND OTHER ELEMENTS. 11. AIR BALANCE TECHNICIAN TO TAKE ALL MEASUREMENTS NECESSARY TO DETERMINE CURRENT SYSTEMS PERFORMANCE IN AREAS THAT WILL CONTINUE TO BE SERVED BY EXISTING AIR HANDLING EQUIPMENT AND SHALL REPORT ALL MEASUREMENTS MADE PRIOR TO START OF DEMOLITION. 12. ON COMPLETION OF EACH PHASE OF DUCT ALTERATIONS, AIR BALANCE TECHNICIAN SHALL REBALANCE ALL EXISTING SYSTEMS TO DELIVER PRE-CONSTRUCTION FLOWS. 13. EXISTING MECHANICAL SERVICES SHOWN ON THESE DRAWINGS WERE TAKEN FROM THE ORIGINAL CONTRACT DRAWINGS. THE CONTRACTOR SHALL VERIFY EXACT SIZE AND LOCATION OF ALL EXISTING SERVICES ON SITE AND SHALL REMOVE ALL REDUNDANT SERVICES IN THE AREAS OF CONSTRUCTION.

GENERAL DEMOLITION NOTES
1. CONTRACTOR IS TO ENSURE THAT ALL EXISTING PIPING AND DUCTWORK SERVING EXISTING AREAS REMAIN IN SERVICE UNTIL THESE AREAS ARE RECONNECTED TO NEW SERVICES. ONLY THEN OBSOLETE PIPING IS TO BE REMOVED AS SHOWN. 2. ALL DISTURBED SURFACES AFTER PIPE AND DUCT REMOVAL OR REROUTING TO BE FILLED-IN WITH APPROPRIATE MATERIAL TO MAINTAIN FIRE SEPARATION AND PATCHED TO MATCH EXISTING OR NEW MATERIALS AND FINISHES. 3. CONTRACTOR IS TO ENSURE THAT ALL EXISTING REMOVED FIXTURES AND EQUIPMENT REMAIN THE PROPERTY OF THE OWNER. IF THE OWNER DECLARES NO INTEREST IN THE REMOVED ITEMS, ASSUME OWNERSHIP AND REMOVE THE ITEMS FROM THE SITE. 4. PROTECT ALL AREAS AFFECTED BY CONSTRUCTION FROM DIRT, DUST AND DEBRIS. 5. REMOVE ALL RUBBISH AND CLEAN SITE DAILY. 6. DEMOLITION AND REMOVAL OF PLUMBING AND DRAINAGE PIPING SHALL BE TAKEN BACK TO THE NEAREST WORKING MAIN AND BE CAPPED AS CLOSE TO THE WORKING MAIN AS POSSIBLE TO AVOID DEAD LEG LENGTHS OF PIPING.

PLUMBING NOTES
1. CONTRACTOR IS TO VERIFY CONNECTION POINTS TO EXISTING SERVICES ON SITE. 2. CONTRACTOR IS TO CLEAR EXISTING DUCTWORK WHEN INSTALLING NEW PIPING. CLEARANCES TO BE VERIFIED ON SITE. 3. PROVIDE A CLEANOUT FROM EACH PLUMBING FIXTURE WHERE REQUIRED BY LATEST ONTARIO BUILDING CODE. 4. ALL PLUMBING FIXTURES INCLUDING FLOOR DRAINS (HUB, FUNNEL FLOOR DRAINS) TO BE TRAPPED AND VENTED AS REQUIRED BY ONTARIO LATEST BUILDING CODE. 5. CONTRACTOR IS TO REMOVE ALL OBSOLETE PIPING WHEREVER POSSIBLE. 6. BEFORE CUTTING ANY HOLES THROUGH THE EXISTING SLAB REFER TO STRUCTURAL DRAWINGS FOR GENERAL REQUIREMENTS. 7. AFTER PIPE REMOVAL ALL EXISTING OPENINGS IN FIRE SEPARATION ARE TO BE FILLED-IN TO MAINTAIN INTEGRITY OF THAT FIRE SEPARATION. 8. RECONNECT VENTS FROM EXISTING EQUIPMENT AND PLUMBING FIXTURES WHICH ARE TO REMAIN TO NEW VENTS AS REQUIRED. 9. PROVIDE A CLEANOUT AT THE BOTTOM OF EVERY SOIL AND WASTE STACK THAT CONNECTS TO A HORIZONTAL DRAINAGE PIPE. 10. CHECK AND VERIFY LOCATION OF ALL PIPES, DUCTS AND EQUIPMENT WITH ALL OTHER TRADES TO PREVENT INTERFERENCE. REMOVAL OR RELOCATION OF ANY SUCH WORK INTERFERING WITH WORK OF OTHER TRADES IS THE RESPONSIBILITY OF THE MECHANICAL TRADE CONCERNED UNLESS OTHERWISE APPROVED IN WRITING. 11. FOR MOUNTING HEIGHT OF ALL PLUMBING FIXTURES REFER TO ARCHITECTURAL DRAWINGS. 12. WHENEVER COLD AND HOT WATER DISTRIBUTION TO LAVATORIES IS TO RUN UNDER COUNTER, PIPING DISTRIBUTION IS TO BE INSTALLED AS TIGHT TO UNDER SIDE OF THE COUNTER AS POSSIBLE. 13. ALL WATER, SANITARY, SEWER AND VENT COPPER PIPING WITH SOLDER JOINTS SHALL BE LEAD FREE. DO NOT INSTALL WATER LINES IN OUTSIDE WALL WHERE THEY MAY FREEZE, UNLESS BOTH THE WALL AND THE PIPES ARE PROPERLY INSULATED. 14. INSTALL SHUT-OFF VALVES AT EACH PLUMBING FIXTURE.



FIRE SUPPRESSION NOTES
1. SPRINKLER CONTRACTOR IS RESPONSIBLE FOR DESIGN OF SPRINKLER SYSTEM IN STRICT ACCORDANCE WITH THE ONTARIO BUILDING CODE, ALL APPLICABLE NFPA STANDARDS, THE REQUIREMENTS OF THE OWNER'S INSURANCE UNDERWRITERS ENGINEERING AUTHORITY (O.I.U.E.A.) AND AUTHORITIES HAVING JURISDICTION. 2. PROVIDE ADDITIONAL SPRINKLER HEADS AS REQUIRED TO SUIT OBSTRUCTIONS GREATER THAN 1200mm (48") [I.E.: DUCTWORK, BULKHEADS, ETC.]. 3. CONTRACTOR SHALL PAY ALL FEES, CHARGES AND COSTS REQUIRED FOR REVIEWS, INSPECTIONS, TESTS OR COMMENTS IN REGARDS TO THIS PROJECT. 4. THE SPRINKLER LAYOUT SHOWN ON THESE DRAWINGS SERVE AS A GENERAL SCOPE OF WORK. THE SPRINKLER CONTRACTOR SHALL MAKE ALL MODIFICATIONS TO THE DESIGN TO COMPLY WITH AUTHORITIES REQUIREMENTS AND TO THE ARCHITECT'S APPROVAL. SPRINKLER HEADS MAY BE ADDED OR DELETED TO PROVIDE ADEQUATE COVERAGE AS DETERMINED BY THE SPRINKLER CONTRACTOR AT NO EXTRA OR CREDIT TO THE CONTRACT, PROVIDED ALL APPROVALS ARE MET IN FULL COORDINATION MECHANICAL, ELECTRICAL, STRUCTURAL AND ARCHITECTURAL ELEMENTS OF THE BUILDINGS. 5. FOR FINAL COORDINATION OF SPRINKLER LAYOUT REFER TO ARCHITECTURAL REFLECTED CEILING PLAN. 6. SPRINKLER CONTRACTOR IS TO SUBMIT LAYOUT OF SPRINKLER HEAD LOCATIONS TO ARCHITECT AND CONSULTANTS FOR REVIEW. 7. IN ACOUSTIC CEILING TILES, LOCATE SPRINKLERS CENTERED LENGTHWISE WITH TILE, AT LEAST 6" FROM "T". 8. SPRINKLER CONTRACTOR SHALL PROVIDE SPRINKLER PERMIT.

HVAC NOTES
1. REFER TO ARCHITECTURAL REFLECTED CEILING PLAN FOR CO-ORDINATION OF GRILLES, DIFFUSERS AND OTHER ELEMENTS. 2. CONTRACTORS SHALL COORDINATE ALL CEILING FINISHES WITH OWNER AND MATCH EXISTING. CONTRACTOR SHALL REVIEW MECHANICAL DRAWINGS, ARCHITECTURAL REFLECTED CEILING PLANS AND ARCHITECTURAL ROOM FINISH SCHEDULES AS SOON AS CONTRACT DOCUMENTS ARE SIGNED. ADVISE CONSULTANT OF ANY CONFLICTS BETWEEN CEILING TYPE AND DIFFUSER/GRILLE TYPE. 3. THE CONTRACTOR SHALL VERIFY ALL CEILING FINISHES WITH ARCHITECTURAL DRAWINGS. CONTRACTOR AND DIFFUSER/GRILLE SUPPLIER ARE RESPONSIBLE TO PROVIDE ALL PLASTER AND FINISHING FRAMES, MOUNTING HARDWARE, AND ACCESSORIES TO SUIT ARCHITECTURAL CEILING TYPES. MECHANICAL CONTRACTOR SHALL CO-ORDINATE AND PROVIDE DETAILS OF MOUNTING REQUIREMENTS OF DIFFUSERS AND GRILLES IN DRYWALL CEILINGS TO DRYWALL TRADE AND ENSURE EDGES OF OPENINGS ARE FRAMED BY DRYWALL TRADE TO SUPPORT DIFFUSERS AND GRILLES PROPERLY. DIFFUSERS AND GRILLES MUST NOT BE SUPPORTED SOLELY BY HANGER WIRES. 4. PROPERLY SUPPORT CEILING MOUNTED EQUIPMENT AND ANY OTHER EQUIPMENT INDEPENDENT OF CEILING SUPPORT SYSTEM. REFER TO ARCHITECTURAL DETAILS AND CO-ORDINATE WITH STRUCTURAL TRADE. 5. FOR USE OF FLEXIBLE DUCTWORK REFER TO MECHANICAL SPECIFICATIONS. 6. CONTRACTOR TO CARRY FOR ADDITIONAL DUCTS AND DUCT FITTING REQUIRED TO CLEAR THE INTERFERENCES IN THE CEILING SPACE. 7. PROVIDE BALANCING DAMPER FOR EACH DIFFUSER AND CHILLED BEAM AND AIR VALVE. ALL LOCATIONS MAY NOT BE SHOWN ON PLANS.

MECHANICAL DRAWING LIST				
DWG. No.	DRAWING NAME	CURRENT REVISION	CURRENT REVISION DESCRIPTION	DATE
M001	GENERAL NOTES & DRAWING LIST	7	ISSUED FOR TENDER	2026.04.10
M002	LEGENDS & ABBREVIATIONS	7	ISSUED FOR TENDER	2026.04.10
M100	LEVEL 1 FIRE PROTECTION DEMO & PROPOSED PLAN	7	ISSUED FOR TENDER	2026.04.10
M101	LEVEL 2 FIRE PROTECTION DEMO & PROPOSED PLAN	7	ISSUED FOR TENDER	2026.04.10
M200	LEVEL 2 PLUMBING DEMO PLAN	7	ISSUED FOR TENDER	2026.04.10
M201	LEVEL 2 PLUMBING PROPOSED PLAN	7	ISSUED FOR TENDER	2026.04.10
M300	LEVEL 1 DRAINAGE DEMO & PROPOSED PLAN	7	ISSUED FOR TENDER	2026.04.10
M301	LEVEL 2 DRAINAGE DEMO & PROPOSED PLAN	7	ISSUED FOR TENDER	2026.04.10
M400	LEVEL 2 MEDICAL GAS DEMO & PROPOSED PLAN	7	ISSUED FOR TENDER	2026.04.10
M500	LEVEL 1 HVAC DEMO & PROPOSED PLAN	7	ISSUED FOR TENDER	2026.04.10
M501	LEVEL 2 HVAC DEMOLITION PLAN	7	ISSUED FOR TENDER	2026.04.10
M502	LEVEL 2 HVAC PROPOSED PLAN - CT SCANNER AREA	7	ISSUED FOR TENDER	2026.04.10
M503	LEVEL 2 HVAC PROPOSED PLAN - INJECTION ROOM AREA	7	ISSUED FOR TENDER	2026.04.10
M600	LEVEL 2 HYDRONIC DEMO & PROPOSED PLAN	7	ISSUED FOR TENDER	2026.04.10
M700	MECHANICAL PENTHOUSE HVAC PLAN	7	ISSUED FOR TENDER	2026.04.10
M800	ROOF - MECHANICAL PLAN	7	ISSUED FOR TENDER	2026.04.10
M900	SCHEMATIC	7	ISSUED FOR TENDER	2026.04.10
M1000	CONTROL DIAGRAMS	7	ISSUED FOR TENDER	2026.04.10
M1100	DETAILS	7	ISSUED FOR TENDER	2026.04.10
M1101	DETAILS	7	ISSUED FOR TENDER	2026.04.10
M1102	DETAILS	7	ISSUED FOR TENDER	2026.04.10
M1200	SCHEDULES	7	ISSUED FOR TENDER	2026.04.10



PROJECT LOGO

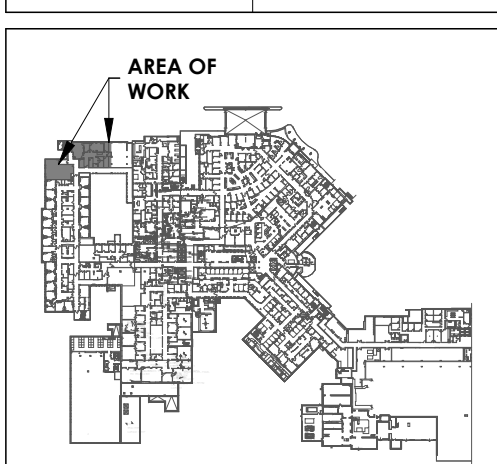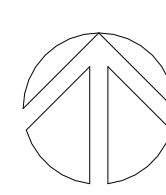

KEY PLAN

ISSUED FOR TENDER
(2026.02.27)

7	ISSUED FOR TENDER	2026.04.10
6	ISSUED FOR TENDER	2025.12.12
5	ISSUED FOR PERMIT	2025.11.26
4	FINAL DESIGN DEVELOPMENT SET	2025.11.07
3	100% DESIGN DEVELOPMENT SET	2025.10.31
2	100% DESIGN DEVELOPMENT PROGRESS SET	2025.09.29
1	50% DESIGN DEVELOPMENT PROGRESS SET	2025.05.09

No.	DESCRIPTION	DATE
-----	-------------	------

REVISIONS:

DISCREPANCIES MUST BE REPORTED IMMEDIATELY TO THE ARCHITECT/ENGINEER BEFORE PROCEEDING.
ONLY FIGURED DIMENSIONS MUST BE USED.
THE CONTRACTOR MUST CHECK THE DIMENSIONS ON SITE.
THE DRAWING IS PROTECTED BY COPYRIGHT.
ALL DIMENSIONS ARE SHOWN IN MILLIMETERS.
DO NOT SCALE THE DRAWINGS.

mc

CallumSather

Westinghouse HQ, 2nd Floor
286 Sanford Ave. N
Hamilton, ON L8L 6A1
905.526.6700
www.mccallumsather.com

SEAL

CONSULTANTS:

PROJECT:

WATERLOO REGIONAL HEALTH NETWORK @ MODTPWN - PET CT

835 KING ST W, KITCHENER, ON N2G 1G


DRAWING TITLE:
GENERAL NOTES & DRAWING LIST

DRAWN BY:	SB, MC	DATE:	2024/09/01
CHECKED BY:	DR, AB	SCALE:	


PROJECT NO: **24048**

DRAWING NO: **M001**

MECHANICAL LEGEND									
SYMBOL	DESCRIPTION	SYMBOL	DESCRIPTION	SYMBOL	DESCRIPTION	ABBREVIATION	DESCRIPTION	SYMBOL	DESCRIPTION
	GAS UTILITY METER & PRV STATION		FLANGED CONNECTION		WATER GONG	AD	ACCESS DOOR		SHEET & VIEW NUMBER
	METER		PLUG CAP		FIRE DEPARTMENT CONNECTION	AFF	ABOVE FINISHED FLOOR		REVISION TAG
	CARBON DIOXIDE SENSOR		FLEXIBLE CONNECTION		THRUST BLOCK	AHU	AIR HANDLING UNIT		ROOM NAME AND NUMBER
	CARBON MONOXIDE SENSOR		LOW WATER CUT OFF		FIRE EXTINGUISHER	AP	MEDICAL GAS ALARM PANEL		
	HUMIDISTAT		THERMOMETER			AT	AIR TERMINAL		
	HEAT DETECTOR		PRESSURE GAUGE			BD	BALANCING DAMPER		
	REVERSE ACTING THERMSTAT		ELECTRICALLY MONITORED SHUT-OFF VALVE			BPW	BEDPAN WASHER		
	OCCUPANCY SENSOR		AIR VENT			CB	CATCHBASIN		
	STATIC PRESSURE SENSOR		AUTOMATIC AIR VENT			CBV	CIRCUIT BALANCING VALVE		
	VENT		PETES PLUG			CFM	CUBIC FEET PER MINUTE		
	TEMPERATURE SENSOR		FLOW METERING DEVICE (FMD)			CTE	CONNECT TO EXISTING		
	HOSE BIBB		MEDICAL GAS OUTLET			DG	DOOR GRILLE		
	FLOOR DRAIN		APPROVED DOUBLE CHECK VALVE			DWF	DISTILLED WATER FAUCET		
	CAP/PLUG		BACKFLOW PREVENTOR ASSEMBLY			EF	EXHAUST FAN		
	CARRIER BACK TO BACK		COOLING COIL			ERV	ENERGY RECOVERY VENTILATOR		
	CLEANOUT- IN LINE OR STACK		HEATING COIL			ESH	EMERGENCY SHOWER		
	FLOOR CLEANOUT		AREA DRAIN			EX	EXISTING		
	PIPE ELBOW DOWN		SHOWER			FD	FIRE DAMPER/FLOOR DRAIN		
	PIPE BOTTOM TAKE OFF		HAND HOLE TRAP			FFD	FUNNEL FLOOR DRAIN		
	PIPE ELBOW UP		RUNNING TRAP			FFH	FAN FORCED HEATER		
	PIPE BOTTOM TAKE OFF		TEMPERATURE CONTROL VALVE			FHC	FIRE HOSE CABINET		
	PIPE SLEEVE		FAN COIL UNIT			FP	FIRE PUMP		
	TRAP		CABINET BLOWER FAN			GPM	GALLONS PER MINUTE		
	UNION		THERMOSTAT			HD	HUB DRAIN		
	PUMP		RELIEF VALVE			HP	HEAT PUMP		
	PIPE FLOW DIRECTION		PLUG VALVE			INV. ELEV.	INVERT ELEVATOIN		
	BALANCING VALVE		NORMALLY CLOSED VALVE			LSV	LOCKED SERVICE VALVE		
	BUTTERFLY VALVE		NORMALLY OPEN VALVE			ME	MECHANICAL EQUIPMENT		
	CHECK VALVE		PIPE ANCHOR			MH	MANHOLE		
	ISOLATING (SHUT-OFF) VALVE		EXPANSION COMPENSATOR c/w GUIDES			NFHB	NON-FREEZE HOSE BIBB		
	STRAINER		PET COCK			OBV. ELEV.	OBVERT ELEVATION		
	PRESSURE INDEPENDENT CONTROL (PIC) VALVE		UNIT HEATERS			PD	PLANTER DRAIN		
	PRESSURE REGULATING VALVE		CONTINUOUS CONVECTORS			PF	PLUMBING FIXTURE		
	2-WAY MODULATING CONTROL VALVE		RADIANT PANELS			REQ'D	REQUIRED		
	3-WAY MODULATING CONTROL VALVE		REHEAT COILS			RF	RETURN FAN		
	2-WAY 2-POSITION CONTROL VALVE		TEMPERATURE SENSOR			RHC	REHEAT COIL		
	FLEXIBLE CONNECTION		PRESSURE SWITCH OR SENSOR			RWL	RAIN WATER LEADER		
	DUCT OFFSET		FLOW SWITCH			S.R.E	AIR DIFFUSERS		
	DUCT OFFSET (SINGLE LINE)		ELECTRIC-PNEUMATIC RELAY			SF	SUPPLY FAN		
	TURNING VANES		PNEUMATIC-ELECTRIC RELAY			SMV	SHOWER MIXING VALVE		
	DUCT-RECTANGULAR		SMOKE DETECTOR			SP	SMOKE PRESENCE DETECTOR		
	DUCT-ROUND		SOLENOID VALVE			SPS	STATIC PRESSURE SENSOR		
	ACOUSTIC LINED DUCT		FIRESTAT			SS	SOIL STACK		
	SUPPLY DUCT DOWN		FREEZESTAT			SWT	SWIVETTE		
	SUPPLY DUCT UP		PRESSURE DIFFERENTIAL SWITCH			TG	TRANSFER GRILLE		
	RETURN DUCT DOWN		PRESSURE GAUGE			Typ.	TYPICAL		
	RETURN DUCT UP		TEMPERATURE GAUGE			UH	UNIT HEATER		
	CEILING SUPPLY DIFFUSER		SPRINKLER RISER			VS	VENT STACK		
	CEILING EXHAUST/RETURN DIFFUSER		HEAT TRACE			WF	WALL FIN HEATER		
	LINEAR DIFFUSER		OXYGEN AND MEDICAL VACUUM OUTLET PORTS			ZV	MEDICAL GAS ZONE VALVE		
	CAPPED END DUCT		MEDICAL GAS ZONE CONTROL BOX WITH ALARM						
	DUCT REDUCER/ENLARGER								
	TRANSITION RECTANGULAR DUCT TO ROUND DUCT								
	FLEXIBLE ROUND DUCT								
	BALANCING DAMPER								
	FIRE DAMPER								
	SPLITTER DAMPER								
	BACKDRAFT DAMPER								
	OPPOSED BLADE DAMPER								
	SMOKE DAMPER								
	MOTORIZED DAMPER								
SYMBOL	DESCRIPTION	SYMBOL	DESCRIPTION	SYMBOL	DESCRIPTION	ABBREVIATION	DESCRIPTION	SYMBOL	DESCRIPTION
	SANITARY ABOVE GRADE		SANITARY BURIED		STORM ABOVE GRADE				STORM BURIED
	DOMESTIC COLD WATER		DOMESTIC HOT WATER		DOMESTIC HOT WATER RETURN				
PIPING SYSTEMS									
SYMBOL	DESCRIPTION	SYMBOL	DESCRIPTION	SYMBOL	DESCRIPTION	SYMBOL	DESCRIPTION	SYMBOL	DESCRIPTION
	ACID SANITARY DRAIN		ARGON		BELOW LEVEL SANITARY DRAIN (IN CEILING LEVEL BELOW)	ACID	ACID		COMPRESSED AIR
	COMPRESSED AIR 15 PSIG		COMPRESSED AIR 30 PSIG		COMPRESSED AIR 50 PSIG	AR	ARGON		COMPRESSED AIR 80 PSIG
	COMPRESSED AIR 100 PSIG		COMPRESSED AIR 150 PSIG		CHILLED BEAM COOLING WATER RETURN	BL SAN	BELOW LEVEL SANITARY DRAIN (IN CEILING LEVEL BELOW)		CHILLED BEAM HEATING WATER RETURN
	CHILLED BEAM COOLING WATER SUPPLY		CHILLED BEAM HEATING WATER SUPPLY		CONDENSATE DRAINAGE, PUMPED	CA	COMPRESSED AIR		CONDENSER WATER RETURN
	CONDENSER WATER SUPPLY		CHILLED WATER SUPPLY		DOMESTIC COLD WATER	CA-15	COMPRESSED AIR 15 PSIG		DOMESTIC HOT WATER
	DOMESTIC COLD WATER		DOMESTIC HOT WATER		DE-IONIZED WATER	CA-30	COMPRESSED AIR 30 PSIG		DISTILLED WATER
	DISTILLED WATER		DOMESTIC RECIRCULATING WATER		DOMESTIC TEMPERED WATER	CA-50	COMPRESSED AIR 50 PSIG		FIRE PROTECTION OTHER
	FIRE PROTECTION OTHER		FIRE PROTECTION DRY		FIRE PROTECTION PRE-ACTION	CA-80	COMPRESSED AIR 80 PSIG		VORTEX FIRE/SPRINKLER PIPING
	VORTEX FIRE/SPRINKLER PIPING		NATURAL GAS		GLYCOL COOLING WATER RETURN	CA-100	COMPRESSED AIR 100 PSIG		GLYCOL HEATING WATER RETURN
	GLYCOL COOLING WATER SUPPLY		GLYCOL HEATING WATER SUPPLY		GREASE WASTE	CA-150	COMPRESSED AIR 150 PSIG		GREASE WASTE, PUMPED
	GREASE WASTE		GEO HX WATER RETURN		GEO HX WATER SUPPLY	CBCH	CHILLED BEAM HEATING WATER RETURN		HEATING WATER RETURN
	HEATING WATER RETURN		HEATING WATER SUPPLY		HEAT PUMP WATER RETURN	CBHS	CHILLED BEAM HEATING WATER SUPPLY		HEAT PUMP WATER SUPPLY
	HEAT PUMP WATER RETURN		HEAT PUMP WATER SUPPLY		HEATING WATER RETURN REVERSE	CD-G	CONDENSATE DRAINAGE, GRAVITY		HEATING WATER SUPPLY
	HEATING WATER SUPPLY		HEATING WATER RETURN		HEATING WATER SUPPLY	CD-P	CONDENSATE DRAINAGE, PUMPED		HEAT PUMP WATER RETURN
	HEATING WATER RETURN		HEATING WATER SUPPLY		HEATING WATER RETURN	CDS	CONDENSER WATER SUPPLY		HEATING WATER SUPPLY
	HEATING WATER SUPPLY		HEATING WATER RETURN		HEATING WATER SUPPLY	CWR	CHILLED WATER RETURN		HEATING WATER RETURN
	HEATING WATER RETURN		HEATING WATER SUPPLY		HEATING WATER RETURN	CWS	CHILLED WATER SUPPLY		HEATING WATER SUPPLY
	HEATING WATER SUPPLY		HEATING WATER RETURN		HEATING WATER SUPPLY	DCW	DOMESTIC COLD WATER		HEATING WATER RETURN
	HEATING WATER RETURN		HEATING WATER SUPPLY		HEATING WATER RETURN	DGW	GREY COLD WATER		HEATING WATER SUPPLY
	HEATING WATER SUPPLY		HEATING WATER RETURN		HEATING WATER SUPPLY	DHW	DOMESTIC HOT WATER		HEATING WATER RETURN
	HEATING WATER RETURN		HEATING WATER SUPPLY		HEATING WATER RETURN	DI	DE-IONIZED WATER		HEATING WATER SUPPLY
	HEATING WATER SUPPLY		HEATING WATER RETURN		HEATING WATER SUPPLY	DIST	DISTILLED WATER		HEATING WATER RETURN
	HEATING WATER RETURN		HEATING WATER SUPPLY		HEATING WATER RETURN	DRW	DOMESTIC RECIRCULATING WATER		HEATING WATER SUPPLY
	HEATING WATER SUPPLY		HEATING WATER RETURN		HEATING WATER SUPPLY	DTW	DOMESTIC TEMPERED WATER		HEATING WATER RETURN
	HEATING WATER RETURN		HEATING WATER SUPPLY		HEATING WATER RETURN	FP	FIRE PROTECTION OTHER		HEATING WATER SUPPLY
	HEATING WATER SUPPLY		HEATING WATER RETURN		HEATING WATER SUPPLY	FP-DRY	FIRE PROTECTION DRY		HEATING WATER RETURN
	HEATING WATER RETURN		HEATING WATER SUPPLY		HEATING WATER RETURN	FP-PRE	FIRE PROTECTION PRE-ACTION		HEATING WATER SUPPLY
	HEATING WATER SUPPLY		HEATING WATER RETURN		HEATING WATER SUPPLY	FV	VORTEX FIRE/SPRINKLER PIPING		HEATING WATER RETURN
	HEATING WATER RETURN		HEATING WATER SUPPLY		HEATING WATER RETURN	G	NATURAL GAS		HEATING WATER SUPPLY
	HEATING WATER SUPPLY		HEATING WATER RETURN		HEATING WATER SUPPLY	GLCR	GLYCOL COOLING WATER RETURN		HEATING WATER RETURN
	HEATING WATER RETURN		HEATING WATER SUPPLY		HEATING WATER RETURN	GLCS	GLYCOL COOLING WATER SUPPLY		HEATING WATER SUPPLY
	HEATING WATER SUPPLY		HEATING WATER RETURN		HEATING WATER SUPPLY	GLHR	GLYCOL HEATING WATER RETURN		HEATING WATER RETURN
	HEATING WATER RETURN		HEATING WATER SUPPLY		HEATING WATER RETURN	GLHS	GLYCOL HEATING WATER SUPPLY		HEATING WATER SUPPLY
	HEATING WATER SUPPLY		HEATING WATER RETURN		HEATING WATER SUPPLY	GW	GREASE WASTE		HEATING WATER RETURN
	HEATING WATER RETURN		HEATING WATER SUPPLY		HEATING WATER RETURN	GW-P	GREASE WASTE, PUMPED		HEATING WATER SUPPLY
	HEATING WATER SUPPLY		HEATING WATER RETURN		HEATING WATER SUPPLY	GXR	GEO HX WATER RETURN		HEATING WATER RETURN
	HEATING WATER RETURN		HEATING WATER SUPPLY		HEATING WATER RETURN	GXS	GEO HX WATER SUPPLY		HEATING WATER SUPPLY
	HEATING WATER SUPPLY		HEATING WATER RETURN		HEATING WATER SUPPLY	HGR	HEATING WATER RETURN		HEATING WATER RETURN
	HEATING WATER RETURN		HEATING WATER SUPPLY		HEATING WATER RETURN	HGS	HEATING WATER SUPPLY		HEATING WATER SUPPLY
	HEATING WATER SUPPLY		HEATING WATER RETURN		HEATING WATER SUPPLY	HPR	HEAT PUMP WATER RETURN		HEATING WATER RETURN
	HEATING WATER RETURN		HEATING WATER SUPPLY		HEATING WATER RETURN	HPS	HEAT PUMP WATER SUPPLY		HEATING WATER SUPPLY
	HEATING WATER SUPPLY		HEATING WATER RETURN		HEATING WATER SUPPLY	HWR	HEATING WATER RETURN		HEATING WATER RETURN
	HEATING WATER RETURN		HEATING WATER SUPPLY		HEATING WATER RETURN	HWRR	HEATING WATER RETURN REVERSE		HEATING WATER SUPPLY
	HEATING WATER SUPPLY		HEATING WATER RETURN		HEATING WATER SUPPLY	HWS	HEATING WATER SUPPLY		HEATING WATER RETURN
	HEATING WATER RETURN		HEATING WATER SUPPLY		HEATING WATER RETURN	LPS	STEAM 15 PSIG LOW PRESSURE		HEATING WATER SUPPLY
	HEATING WATER SUPPLY		HEATING WATER RETURN		HEATING WATER SUPPLY	MA	MEDICAL AIR		HEATING WATER RETURN
	HEATING WATER RETURN		HEATING WATER SUPPLY		HEATING WATER RETURN	MV	MEDICAL VACUUM		HEATING WATER SUPPLY
	HEATING WATER SUPPLY		HEATING WATER RETURN		HEATING WATER SUPPLY	N2	NITROGEN		HEATING WATER RETURN
	HEATING WATER RETURN		HEATING WATER SUPPLY		HEATING WATER RETURN	NOx	NITROGEN OXIDE		HEATING WATER SUPPLY
	HEATING WATER SUPPLY		HEATING WATER RETURN		HEATING WATER RETURN	NPWC	NON-POTABLE COLD WATER		HEATING WATER RETURN
	HEATING WATER RETURN		HEATING WATER SUPPLY		HEATING WATER SUPPLY	NPHR	NON-POTABLE HOT WATER RECIRCULATING		HEATING WATER RETURN
	HEATING WATER SUPPLY		HEATING WATER RETURN		HEATING WATER SUPPLY	NPHW	NON-POTABLE HOT WATER		HEATING WATER RETURN
	HEATING WATER RETURN		HEATING WATER SUPPLY		HEATING WATER RETURN	O2	OXYGEN		HEATING WATER SUPPLY
	HEATING WATER SUPPLY		HEATING WATER RETURN		HEATING WATER RETURN	PCW	POTABLE COLD WATER		HEATING WATER SUPPLY
	HEATING WATER RETURN		HEATING WATER SUPPLY		HEATING WATER RETURN	PHW	POTABLE HOT WATER		HEATING WATER RETURN
	HEATING WATER SUPPLY		HEATING WATER RETURN		HEATING WATER SUPPLY	PPCW	PROTECTED POTABLE COLD WATER		HEATING WATER RETURN
	HEATING WATER RETURN		HEATING WATER SUPPLY		HEATING WATER RETURN	PPHR	PROTECTED HOT WATER RECIRCULATING		HEATING WATER SUPPLY
	HEATING WATER SUPPLY		HEATING WATER RETURN		HEATING WATER RETURN	PPHW	PROTECTED POTABLE HOT WATER		HEATING WATER SUPPLY
	HEATING WATER RETURN		HEATING WATER SUPPLY		HEATING WATER RETURN	PPTW	PROTECTED POTABLE TEMPERED WATER		HEATING WATER RETURN
	HEATING WATER SUPPLY		HEATING WATER RETURN		HEATING WATER SUPPLY	PRCW	PROCESS COLD WATER		HEATING WATER RETURN
	HEATING WATER RETURN		HEATING WATER SUP						

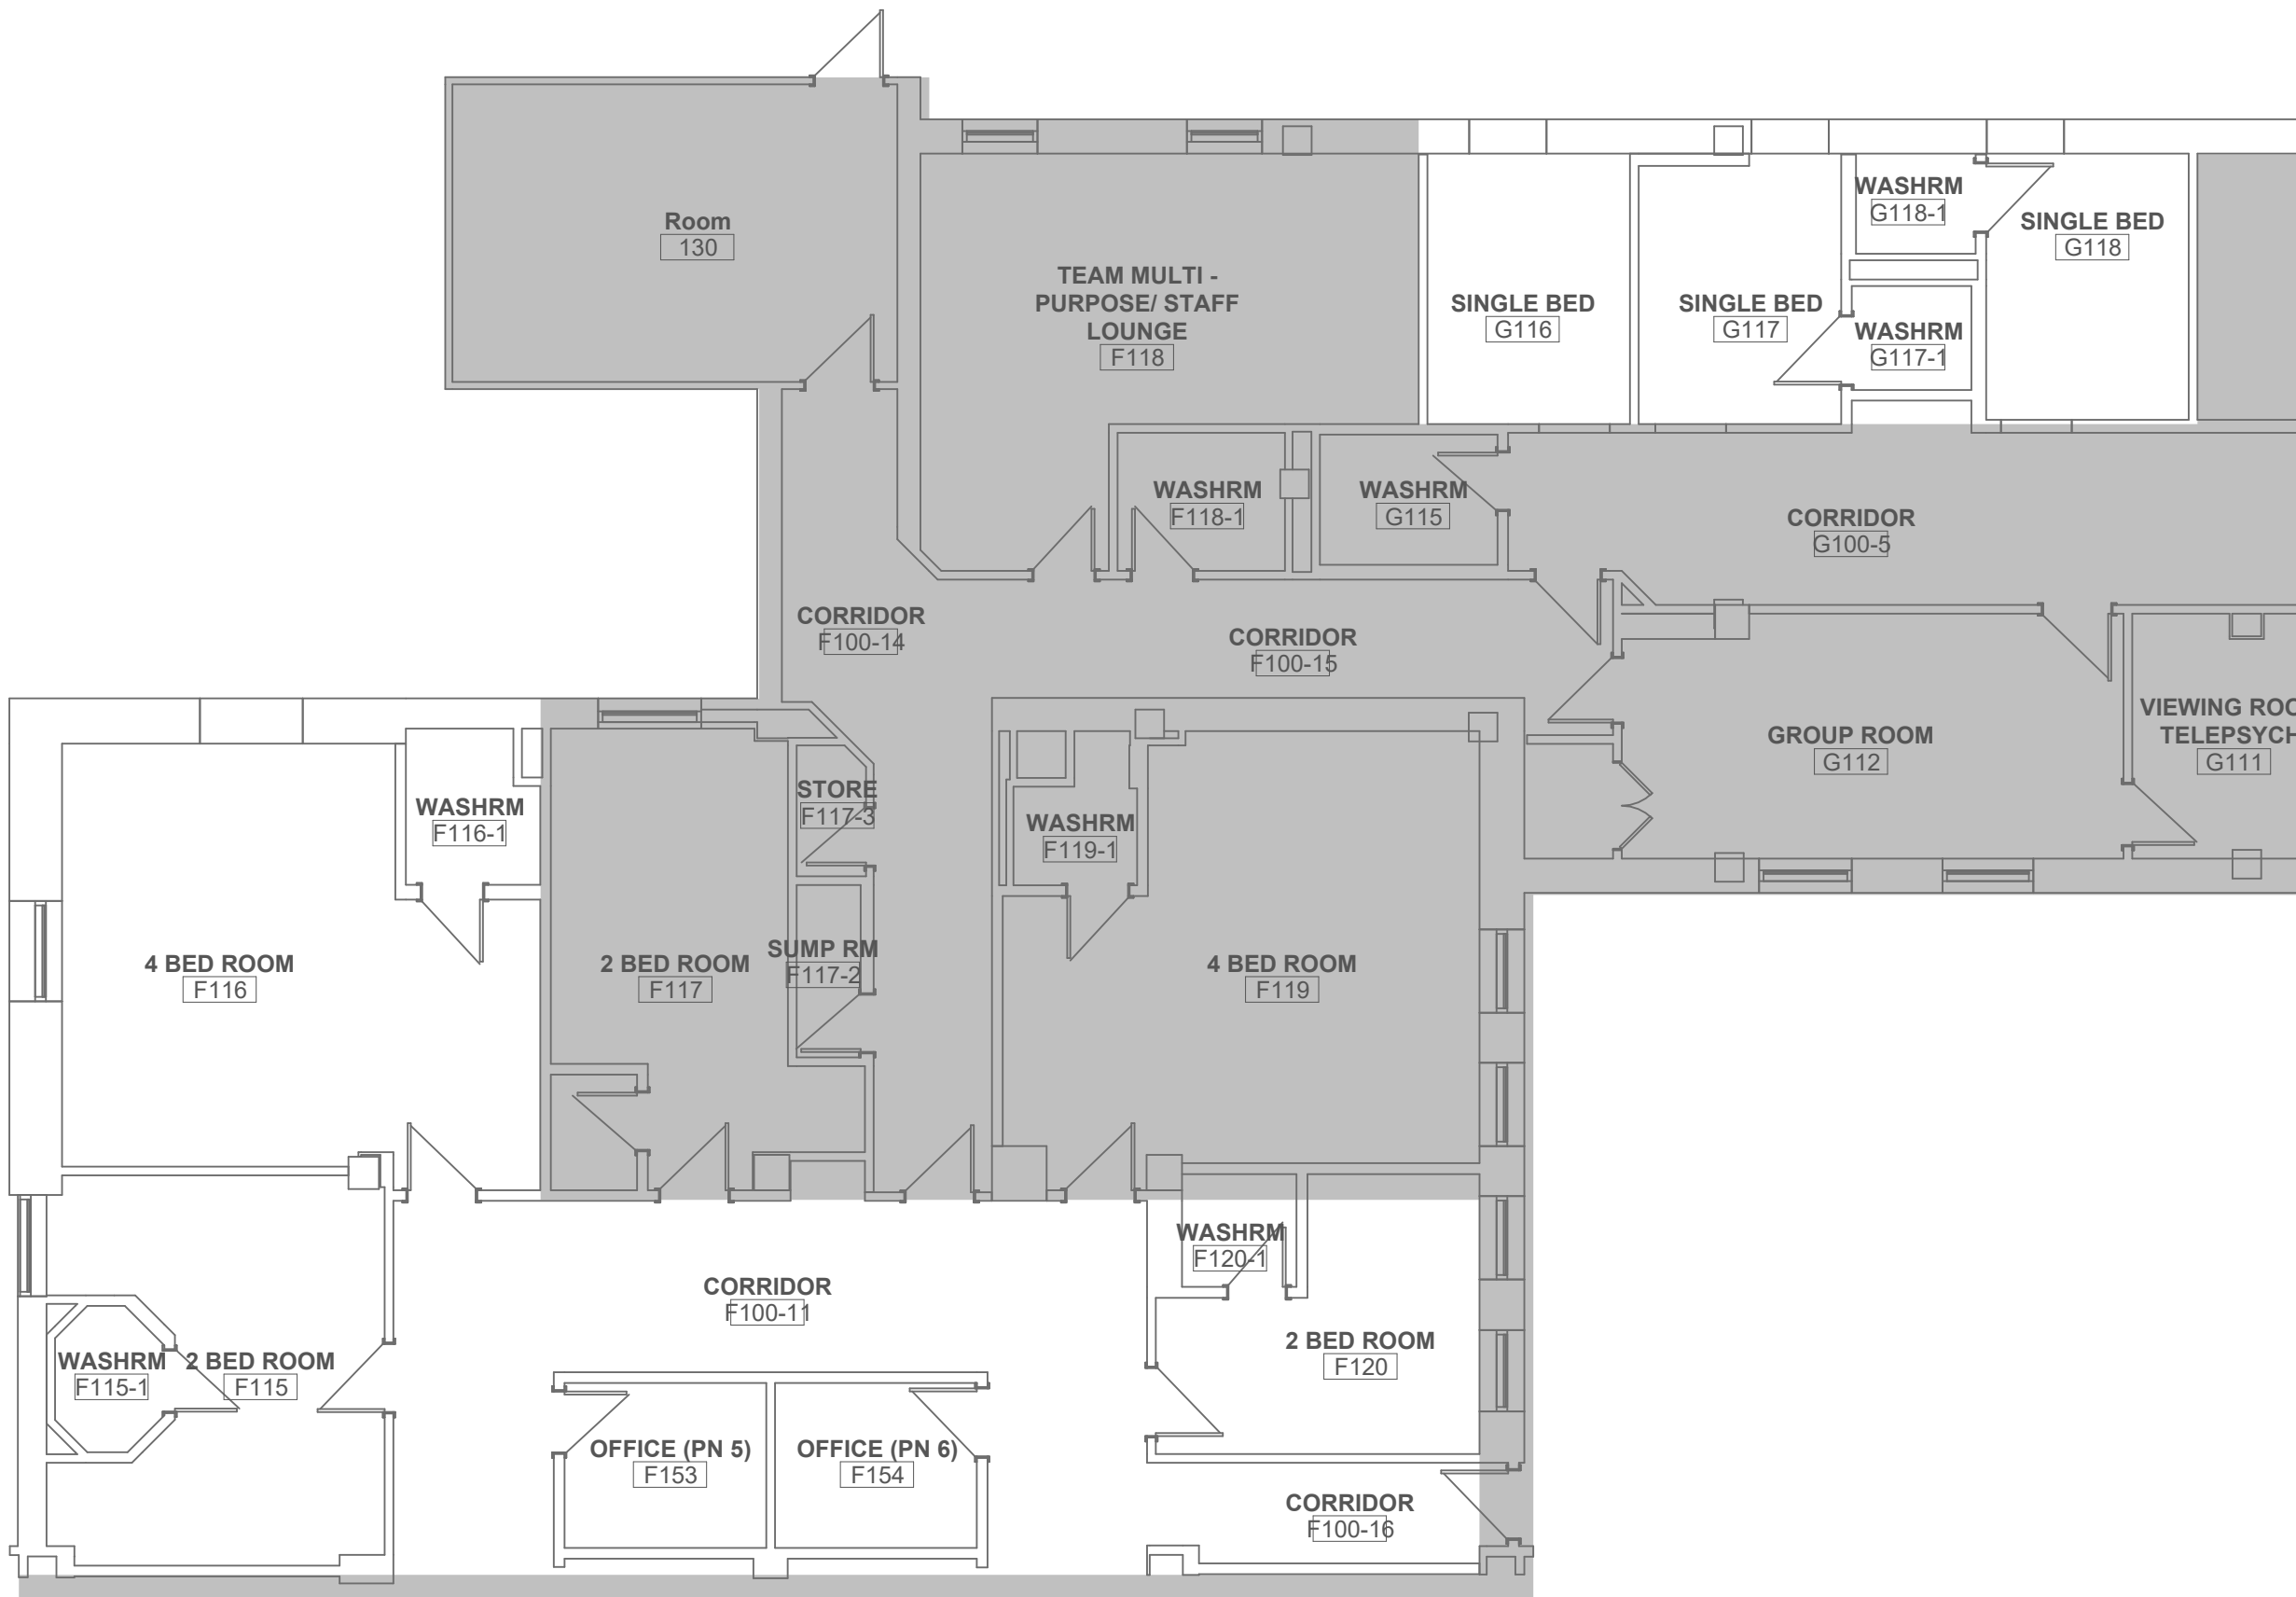

LEVEL 1 FIRE PROTECTION DEMO PLAN

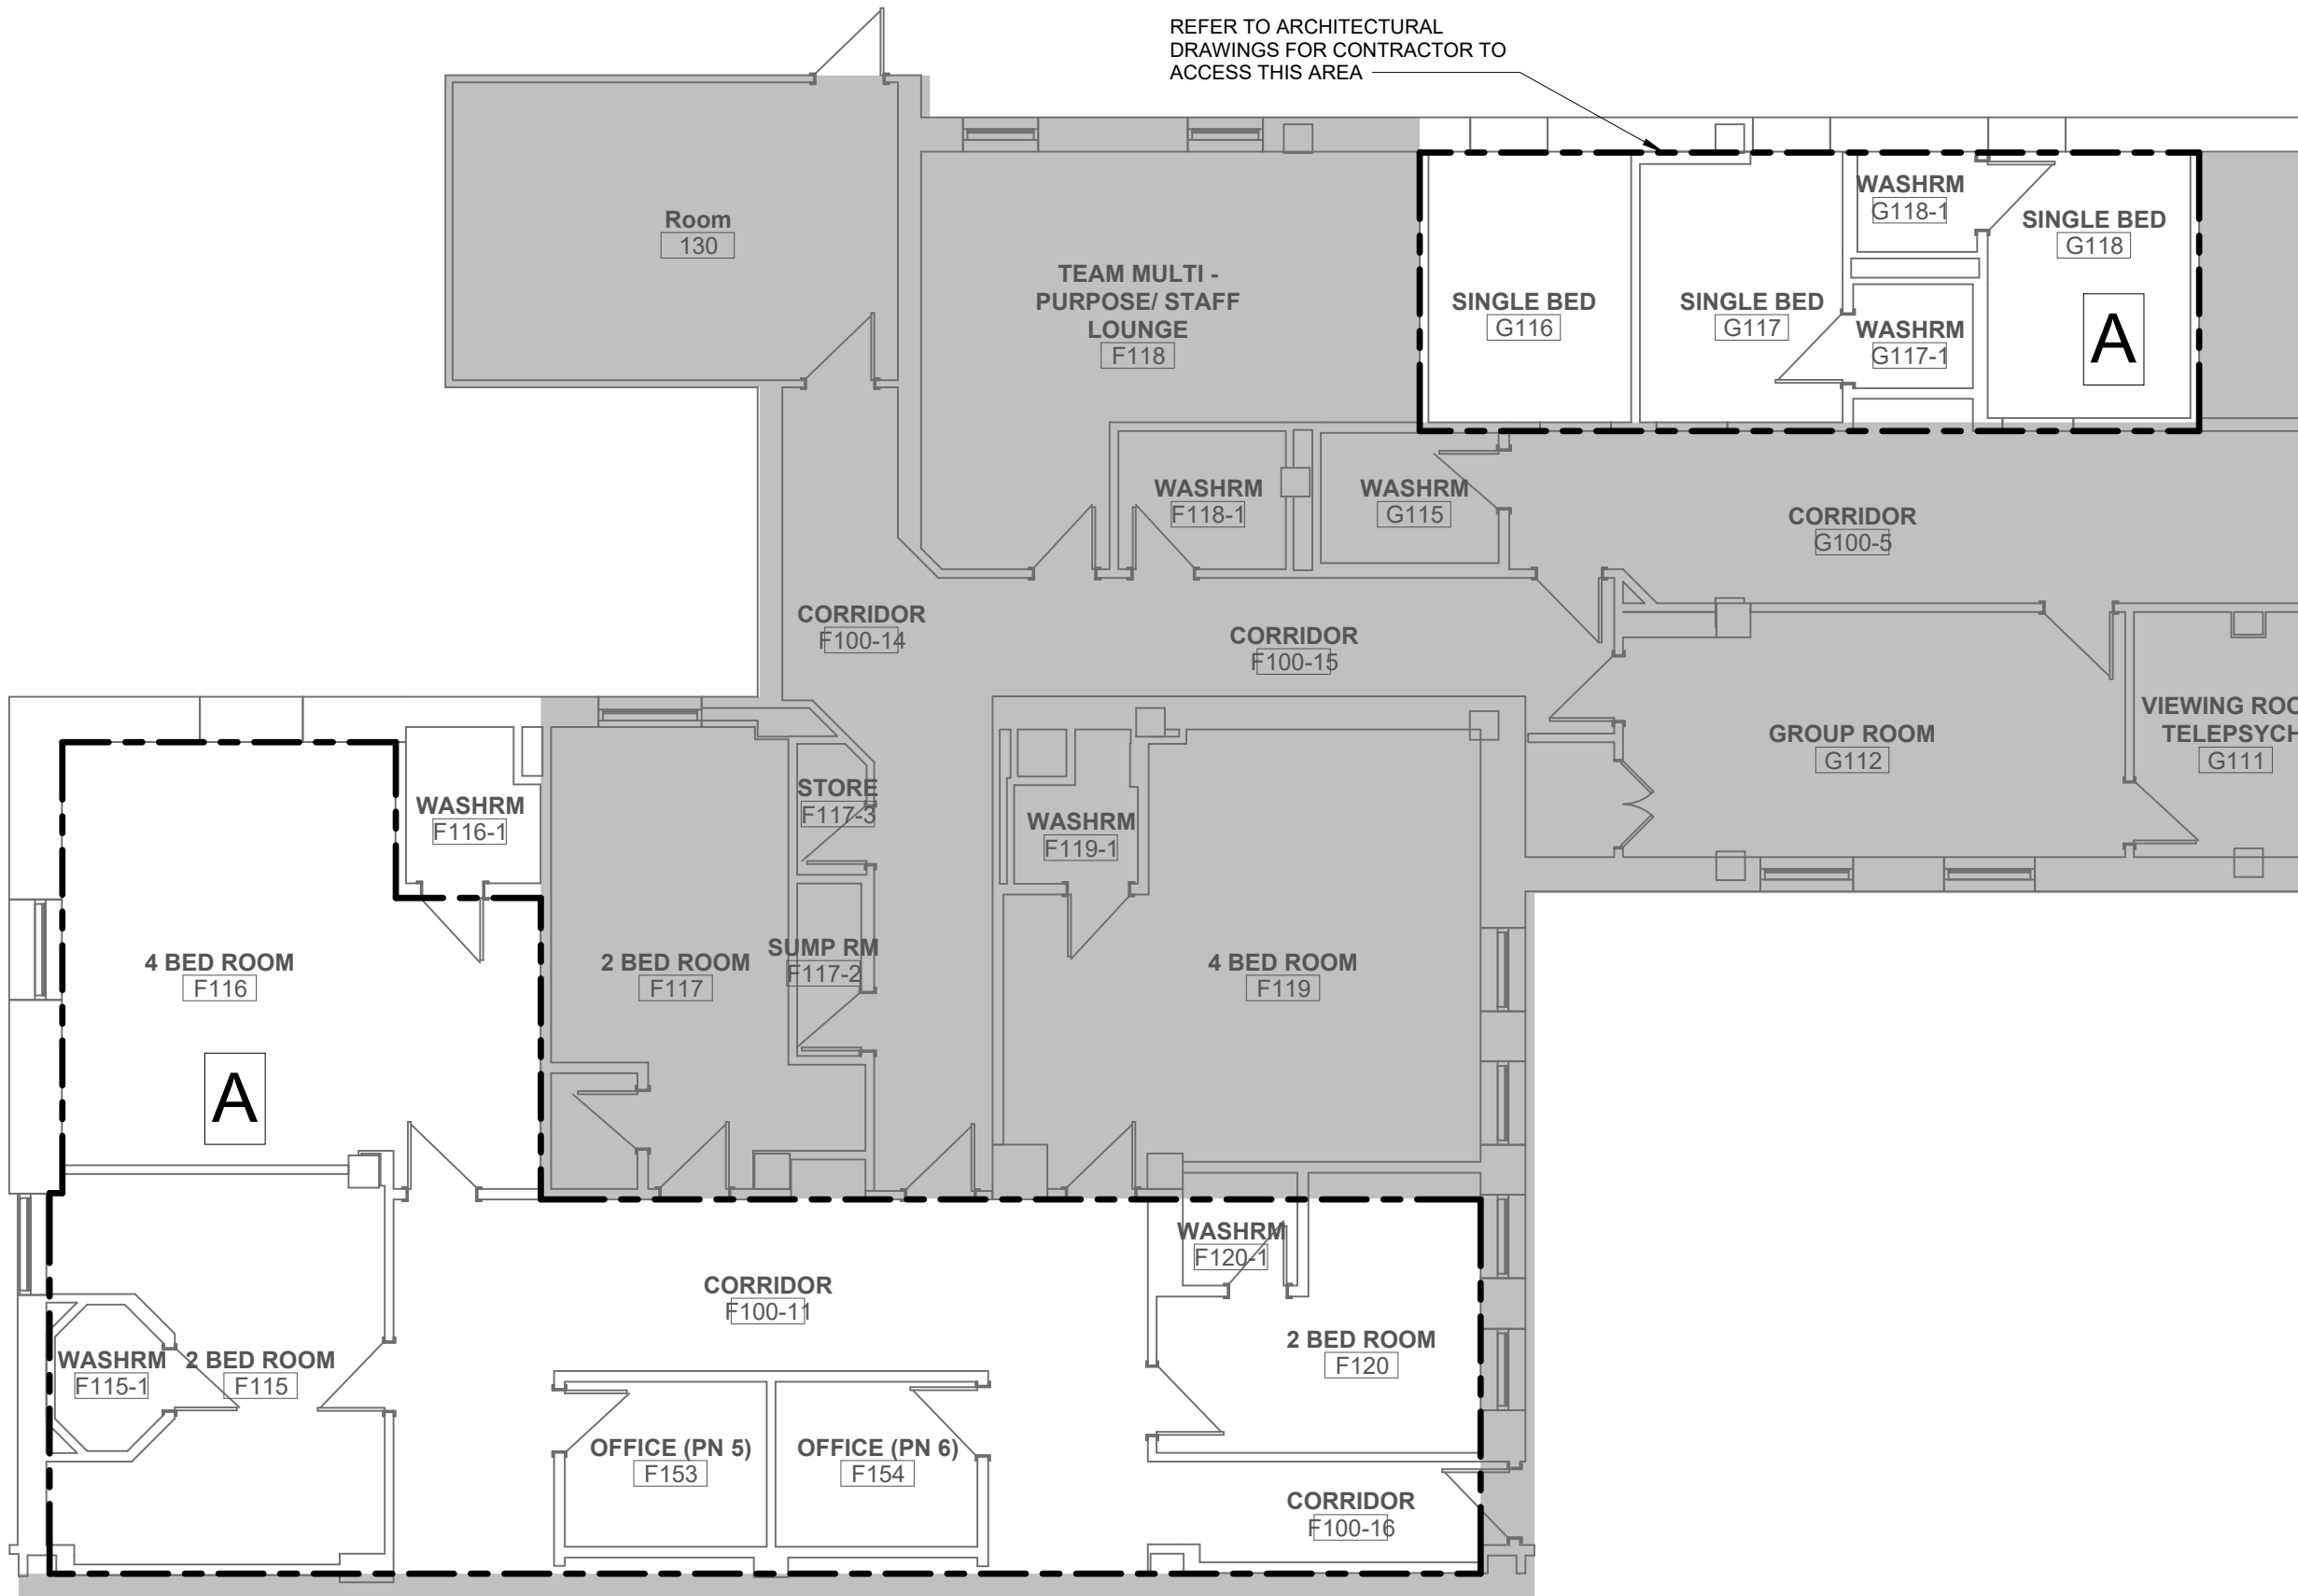

LEVEL 1 FIRE PROTECTION PROPOSED PLAN



NOTES

A

NEW HAZARD GROUP : LIGHT HAZARD
NEW DENSITY : AS PER O.B.C. / INSURANCE
REQUIREMENTS : (RECOMMENDED 0.10 GPM/SQ.FT.)
SPRINKLER HEAD TYPE : CONCEALED (ACOUSTIC TILE)
LIGATURE FREE (GWB/BULKHEAD)

NEW SYSTEM TYPE: WET SYSTEM


CONSTRUCTION NOTES

- A. ALPHABETICAL NOTES ARE GENERAL TO THE PLAN(S) ON THIS SHEET
- B. NUMERICAL NOTES ARE KEYED NOTES CORRESPONDING TO KEYED NOTES ON PLAN(S) ON THIS SHEET
- A. THE FIRE PROTECTION DRAWINGS AND SPECIFICATIONS ARE PERFORMANCE BASED. THE SPRINKLER CONTRACTOR IS TO PROVIDE A COMPLETE SET OF ENGINEERED SPRINKLER STAMPED SPRINKLER DRAWINGS BASED ON THE INFORMATION PROVIDED.
- B. ALL WORK TO COMPLY TO THE LATEST ADDITION OF NFPA # 13 [2013], THE ONTARIO BUILDING CODE.
- C. CONTRACTOR SHALL REVIEW ALL CONTRACT DOCUMENTS BEFORE SUBMITTING PROPOSALS. NO EXTRAS WILL BE GIVEN FOR FAILURE TO REVIEW THE CONTRACT DOCUMENTS WHICH INCLUDES BUT NOT LIMITED TO ALL STRUCTURAL, MECHANICAL, ELECTRICAL AND ARCHITECTURAL DRAWINGS.
- D. ALL HANGERS AND SUPPORTS TO BE SUPPLIED AND INSTALLED IN ACCORDANCE TO NFPA #13.
- E. ALL PIPE TO BE IN ACCORDANCE TO NFPA #13.
- F. ALL DRAINS TO DISCHARGE TO A SUITABLE LOCATION.
- G. COORDINATE THE COMPLETE INSTALLATION WITH ALL OTHER TRADES.
- H. THE CONTRACTOR SHALL BE RESPONSIBLE FOR THE INSTALLATION OF THE FIRE PROTECTION SYSTEMS AND FOR CO-ORDINATION WITH ALL OTHER TRADES. BEFORE COMMENCING WORK EXAMINE THE SITE AND THE WORK OF THE OTHER TRADES AND REPORT AT ONCE TO THE ENGINEER ANY DETECT OR INTERFERENCE AFFECTING THE COMPLETION OF THE WORK, OR THE GUARANTEE OF THIS CONTRACTOR.
- I. ALL WORK SHALL BE DONE IN ACCORDANCE WITH ALL CODES, STANDARDS, BY-LAWS AND AUTHORITIES HAVING JURISDICTION.
- J. SPRINKLER CONTRACTOR TO INCLUDE FOR OFFSETS IN SPRINKLER PIPING AND SUPPLY AND INSTALLATION OF TRAPEZE HANGERS WHERE REQUIRED
- K. ALL MATERIAL TO BE ULC LISTED AND FM APPROVED.
- L. PROVIDE SPRINKLER HEAD BOX C/W SPARE HEADS AS WELL AS ALL SIGNS AS PER NFPA #13.
- M. CONTRACTOR TO PROVIDE 4 SETS OF AS-BUILT DRAWINGS, SHOWING LOCATIONS OF ALL EQUIPMENT AND DRAINS.
- N. PRICE TO INCLUDE FOR ADDITIONAL PIPE AND FITTINGS TO PIPE SPRINKLER DROPS WITHIN 5 FEET OF THE LOCATION SHOWN.
- O. THE SUCCESSFUL CONTRACTOR SHALL CONDUCT A WATER FLOW TEST IN FRONT OF THE PROPERTY BEFORE WORK BEGINS AND SHALL SUBMIT TEST RESULTS AND SPRINKLER HYDRAULIC CALCULATIONS TO THE ENGINEER AND THE CITY BUILDING DEPT. FOR REVIEW.
- P. PROVIDE SHOP DRAWINGS FOR THE FOLLOWING EQUIPMENT:
a. ALL REQUIRED CONTROL VALVES
b. ALL SPRINKLER TYPES
c. ALARM VALVES AND ACCESSORIES
d. ALL ELECTRICAL SWITCHES
- Q. PIPING: PIPING SHALL BE BLACK STEEL SCHEDULE 40 PIPING (MINIMUM SCHEDULE 10) C/W THREADED COUPLINGS AND FITTINGS UP TO 2" DIA. AND WELDED FOR 2-1/2" DIA. AND UP. VICTAULIC COUPLINGS ON SPRINKLER SYSTEMS MAY BE USED WHEN ACCEPTABLE TO THE AUTHORITIES. CPVC PIPING MAYBE USED AS PERMITTED BY NFPA 13.
- R. PROVIDE AND INSTALL PORTABLE FIRE EXTINGUISHERS INCLUDING BRACKETS AND TAGS IN ACCORDANCE WITH NFPA #10, CAN4-S508 AND THE ONTARIO FIRE CODE. PROVIDE STORED PRESSURE RECHARGEABLE TYPE EXTINGUISHERS WITH SHUT OFF NOZZLE ULC LABELED FOR A, B AND C CLASS PROTECTION. PROVIDE SIZE 2.25 KG OR A SIZE AS REQUIRED BY AUTHORITIES HAVING JURISDICTION.
- S. INSTALLING CONTRACTOR TO BE A STANDING MEMBER OF "CASA" (CANADIAN AUTOMATIC SPRINKLER ASSOCIATION).

TO BE DEMOLISHED



PROJECT LOGO

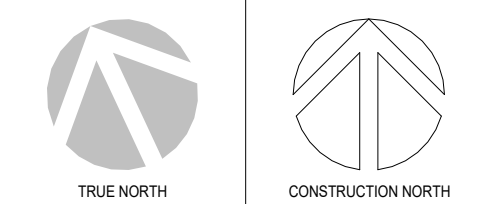

KEY PLAN

ISSUED FOR TENDER
(2026.02.27)

7	ISSUED FOR TENDER	2026.04.10
6	ISSUED FOR TENDER	2025.12.12
5	ISSUED FOR PERMIT	2025.11.26
4	FINAL DESIGN DEVELOPMENT SET	2025.11.07
3	100% DESIGN DEVELOPMENT SET	2025.10.31
2	100% DESIGN DEVELOPMENT PROGRESS SET	2025.09.29
1	50% DESIGN DEVELOPMENT PROGRESS SET	2025.05.09

REVISIONS:

DISCREPANCIES MUST BE REPORTED IMMEDIATELY TO THE ARCHITECT/ENGINEER BEFORE PROCEEDING.
ONLY FIGURED DIMENSIONS MUST BE USED.
THE CONTRACTOR MUST CHECK THE DIMENSIONS ON SITE.
THE DRAWING IS PROTECTED BY COPYRIGHT.
ALL DIMENSIONS ARE SHOWN IN MILLIMETERS.
DO NOT SCALE THE DRAWINGS.

mcCallumSather
Westinghouse HQ, 2nd Floor
286 Sanford Ave. N
Hamilton, ON L8L 6A1
905.526.6700
www.mccallumsather.com

SEAL

CONSULTANTS:

PROJECT:
WATERLOO REGIONAL HEALTH NETWORK @ MODTPWN - PET CT


835 KING ST W, KITCHENER, ON N2G 1G

DRAWING TITLE:
LEVEL 1 FIRE PROTECTION DEMO & PROPOSED PLAN

DRAWN BY:	SB.MC	DATE:	2024/09/01
CHECKED BY:	DR. AB	SCALE:	As indicated


PROJECT NO: **24048**

DRAWING NO: **M100**

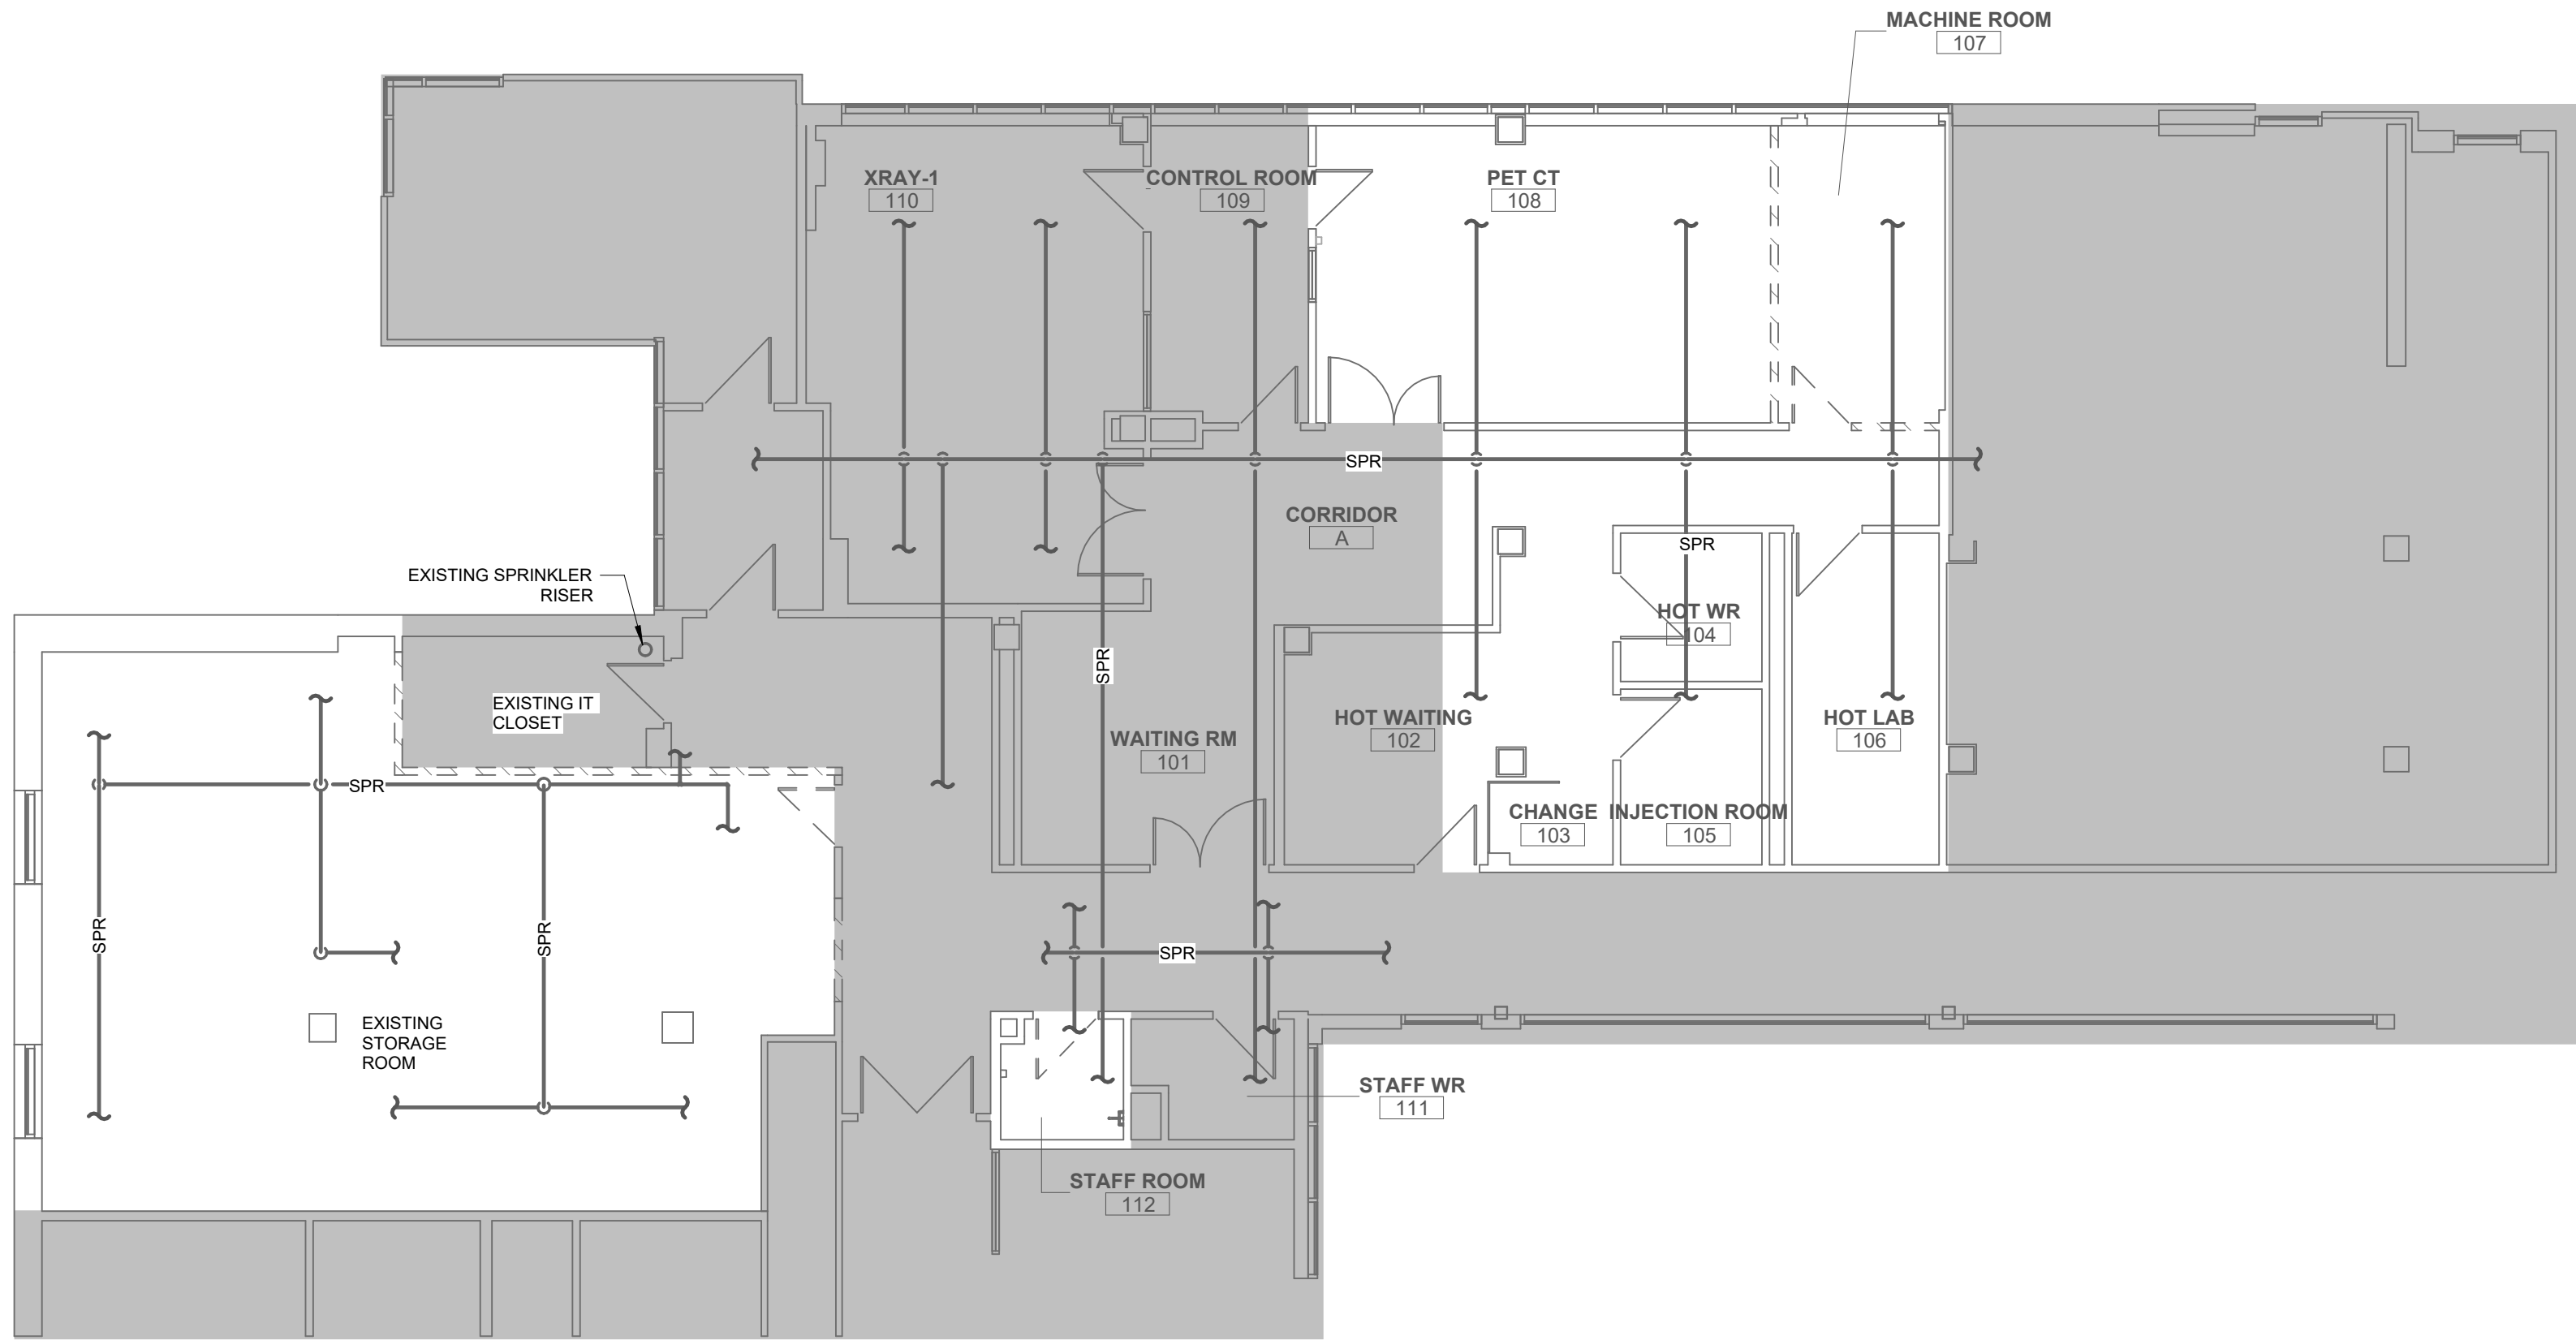

LEVEL 2 FIRE PROTECTION DEMO PLAN

1
1:100 M101

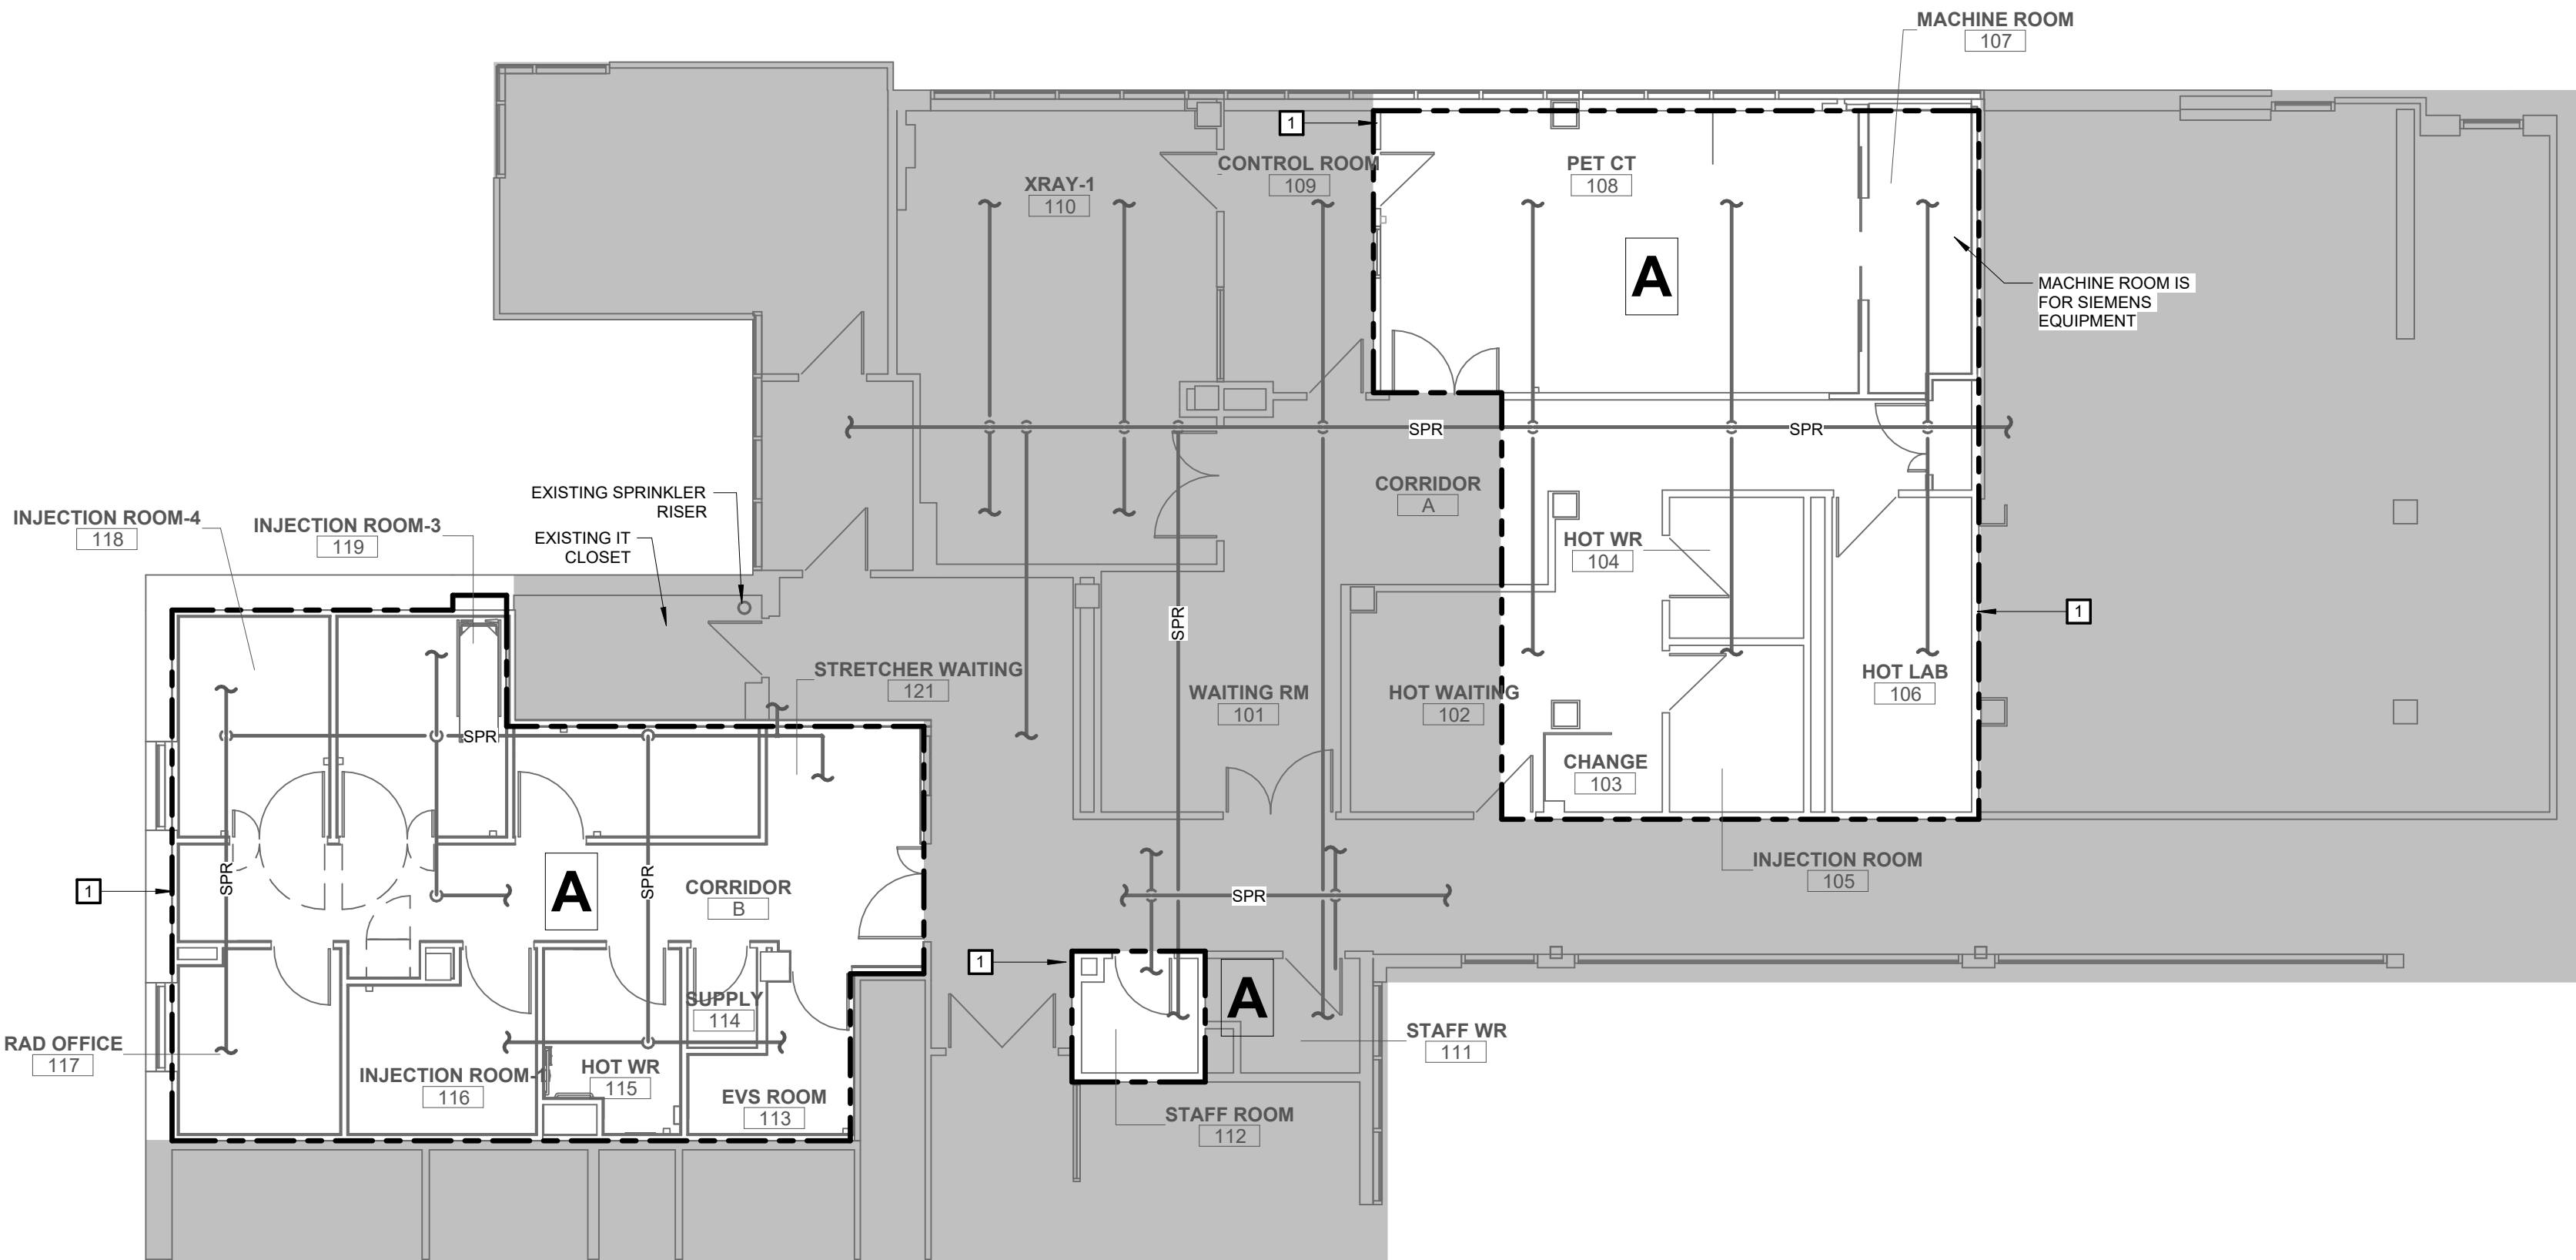

LEVEL 2 FIRE PROTECTION PROPOSED PLAN

2
1:100 M101

NOTES

A

NEW HAZARD GROUP : LIGHT HAZARD
NEW DENSITY : AS PER O.B.C. / INSURANCE
REQUIREMENTS : (RECOMMENDED 0.10 GPM/SQ.FT.)
SPRINKLER HEAD TYPE : CONCEALED (ACOUSTIC TILE)
CONCEALED (GWB/BULKHEAD)
NEW SYSTEM TYPE: WET SYSTEM



CONSTRUCTION NOTES

- A. ALPHABETICAL NOTES ARE GENERAL TO THE PLAN(S) ON THIS SHEET
- B. NUMERICAL NOTES ARE KEYED NOTES CORRESPONDING TO KEYED NOTES ON PLAN(S) ON THIS SHEET
- A. THE FIRE PROTECTION DRAWINGS AND SPECIFICATIONS ARE PERFORMANCE BASED. THE SPRINKLER CONTRACTOR IS TO PROVIDE A COMPLETE SET OF ENGINEERED SPRINKLER STAMPED SPRINKLER DRAWINGS BASED ON THE INFORMATION PROVIDED.
- B. ALL WORK TO COMPLY TO THE LATEST ADDITION OF NFPA #13 [2013], THE ONTARIO BUILDING CODE.
- C. CONTRACTOR SHALL REVIEW ALL CONTRACT DOCUMENTS BEFORE SUBMITTING PROPOSALS. NO EXTRAS WILL BE GIVEN FOR FAILURE TO REVIEW THE CONTRACT DOCUMENTS WHICH INCLUDES BUT NOT LIMITED TO ALL STRUCTURAL, MECHANICAL, ELECTRICAL AND ARCHITECTURAL DRAWINGS.
- D. ALL HANGERS AND SUPPORTS TO BE SUPPLIED AND INSTALLED IN ACCORDANCE TO NFPA #13.
- E. ALL PIPE TO BE IN ACCORDANCE TO NFPA #13.
- F. ALL DRAINS TO DISCHARGE TO A SUITABLE LOCATION.
- G. COORDINATE THE COMPLETE INSTALLATION WITH ALL OTHER TRADES.
- H. THE CONTRACTOR SHALL BE RESPONSIBLE FOR THE INSTALLATION OF THE FIRE PROTECTION SYSTEMS AND FOR CO-ORDINATION WITH ALL OTHER TRADES. BEFORE COMMENCING WORK EXAMINE THE SITE AND THE WORK OF THE OTHER TRADES AND REPORT AT ONCE TO THE ENGINEER ANY DEFECT OR INTERFERENCE AFFECTING THE COMPLETION OF THE WORK. OR THE GUARANTEE OF THIS CONTRACTOR.
- I. ALL WORK SHALL BE DONE IN ACCORDANCE WITH ALL CODES, STANDARDS, BY-LAWS AND AUTHORITIES HAVING JURISDICTION.
- J. SPRINKLER CONTRACTOR TO INCLUDE FOR OFFSETS IN SPRINKLER PIPING AND SUPPLY AND INSTALLATION OF TRAPEZE HANGERS WHERE REQUIRED
- K. ALL MATERIAL TO BE ULC LISTED AND FM APPROVED.
- L. PROVIDE SPRINKLER HEAD BOX C/W SPARE HEADS AS WELL AS ALL SIGNS AS PER NFPA #13.
- M. CONTRACTOR TO PROVIDE 4 SETS OF AS-BUILT DRAWINGS, SHOWING LOCATIONS OF ALL EQUIPMENT AND DRAINS.
- N. PRICE TO INCLUDE FOR ADDITIONAL PIPE AND FITTINGS TO PIPE SPRINKLER DROPS WITHIN 5 FEET OF THE LOCATION SHOWN.
- O. THE SUCCESSFUL CONTRACTOR SHALL CONDUCT A WATER FLOW TEST IN FRONT OF THE PROPERTY BEFORE WORK BEGINS AND SHALL SUBMIT TEST RESULTS AND SPRINKLER HYDRAULIC CALCULATIONS TO THE ENGINEER AND THE CITY BUILDING DEPT. FOR REVIEW.
- P. PROVIDE SHOP DRAWINGS FOR THE FOLLOWING EQUIPMENT:
a. ALL REQUIRED CONTROL VALVES
b. ALL SPRINKLER TYPES
c. ALARM VALVES AND ACCESSORIES
d. ALL ELECTRICAL SWITCHES
- Q. PIPING: PIPING SHALL BE BLACK STEEL, SCHEDULE 40 PIPING (MINIMUM SCHEDULE 10) C/W THREADED COUPLINGS AND FITTINGS UP TO 2" DIA. AND WELDED FOR 2-1/2" DIA. AND UP. VICTAULIC COUPLINGS ON SPRINKLER SYSTEMS MAY BE USED WHEN ACCEPTABLE TO THE AUTHORITIES. CPVC PIPING MAYBE USED AS PERMITTED BY NFPA 13.
- R. PROVIDE AND INSTALL PORTABLE FIRE EXTINGUISHERS INCLUDING BRACKETS AND TAGS IN ACCORDANCE WITH NFPA #10, CANA-5508 AND THE ONTARIO FIRE CODE. PROVIDE STORED PRESSURE RECHARGEABLE TYPE EXTINGUISHERS WITH SHUT OFF NOZZLE ULC LABELED FOR A, B AND C CLASS PROTECTION. PROVIDE SIZE 2.25 KG OR A SIZE AS REQUIRED BY AUTHORITIES HAVING JURISDICTION.
- S. INSTALLING CONTRACTOR TO BE A STANDING MEMBER OF CASA "CANADIAN AUTOMATIC SPRINKLER ASSOCIATION".

TO BE DEMOLISHED



PROJECT LOGO

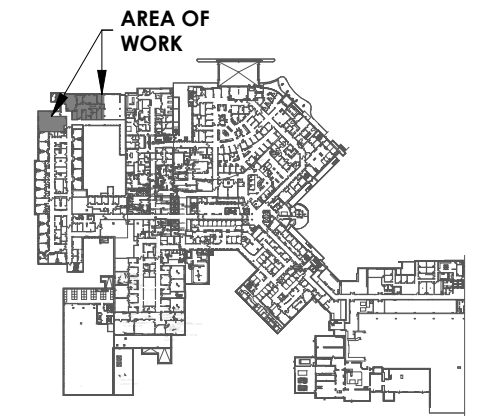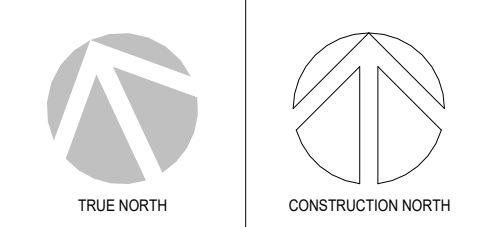

KEY PLAN

ISSUED FOR TENDER
(2026.02.27)

7	ISSUED FOR TENDER	2026.04.10
6	ISSUED FOR TENDER	2025.12.12
5	ISSUED FOR PERMIT	2025.11.26
4	FINAL DESIGN DEVELOPMENT SET	2025.11.07
3	100% DESIGN DEVELOPMENT SET	2025.10.31
2	100% DESIGN DEVELOPMENT PROGRESS SET	2025.09.29
1	50% DESIGN DEVELOPMENT PROGRESS SET	2025.05.09

No.	DESCRIPTION	DATE
REVISIONS:		
DISCREPANCIES MUST BE REPORTED IMMEDIATELY TO THE ARCHITECT/ENGINEER BEFORE PROCEEDING. ONLY FIGURED DIMENSIONS MUST BE USED. THE CONTRACTOR MUST CHECK THE DIMENSIONS ON SITE. THE DRAWING IS PROTECTED BY COPYRIGHT. ALL DIMENSIONS ARE SHOWN IN MILLIMETERS. DO NOT SCALE THE DRAWINGS.		

mcCallumSather
Westinghouse HQ, 2nd Floor
286 Sanford Ave. N
Hamilton, ON L8L 6A1
905.526.6700
www.mccallumsather.com

SEAL

CONSULTANTS:

PROJECT:
WATERLOO REGIONAL HEALTH NETWORK @ MODTPWN - PET CT


835 KING ST W, KITCHENER, ON N2G 1G

DRAWING TITLE:
LEVEL 2 FIRE PROTECTION DEMO & PROPOSED PLAN

DRAWN BY:	SB.MC	DATE:	2024/09/01
CHECKED BY:	DR. AB	SCALE:	As indicated

PROJECT NO: **24048**

DRAWING NO: **M101**

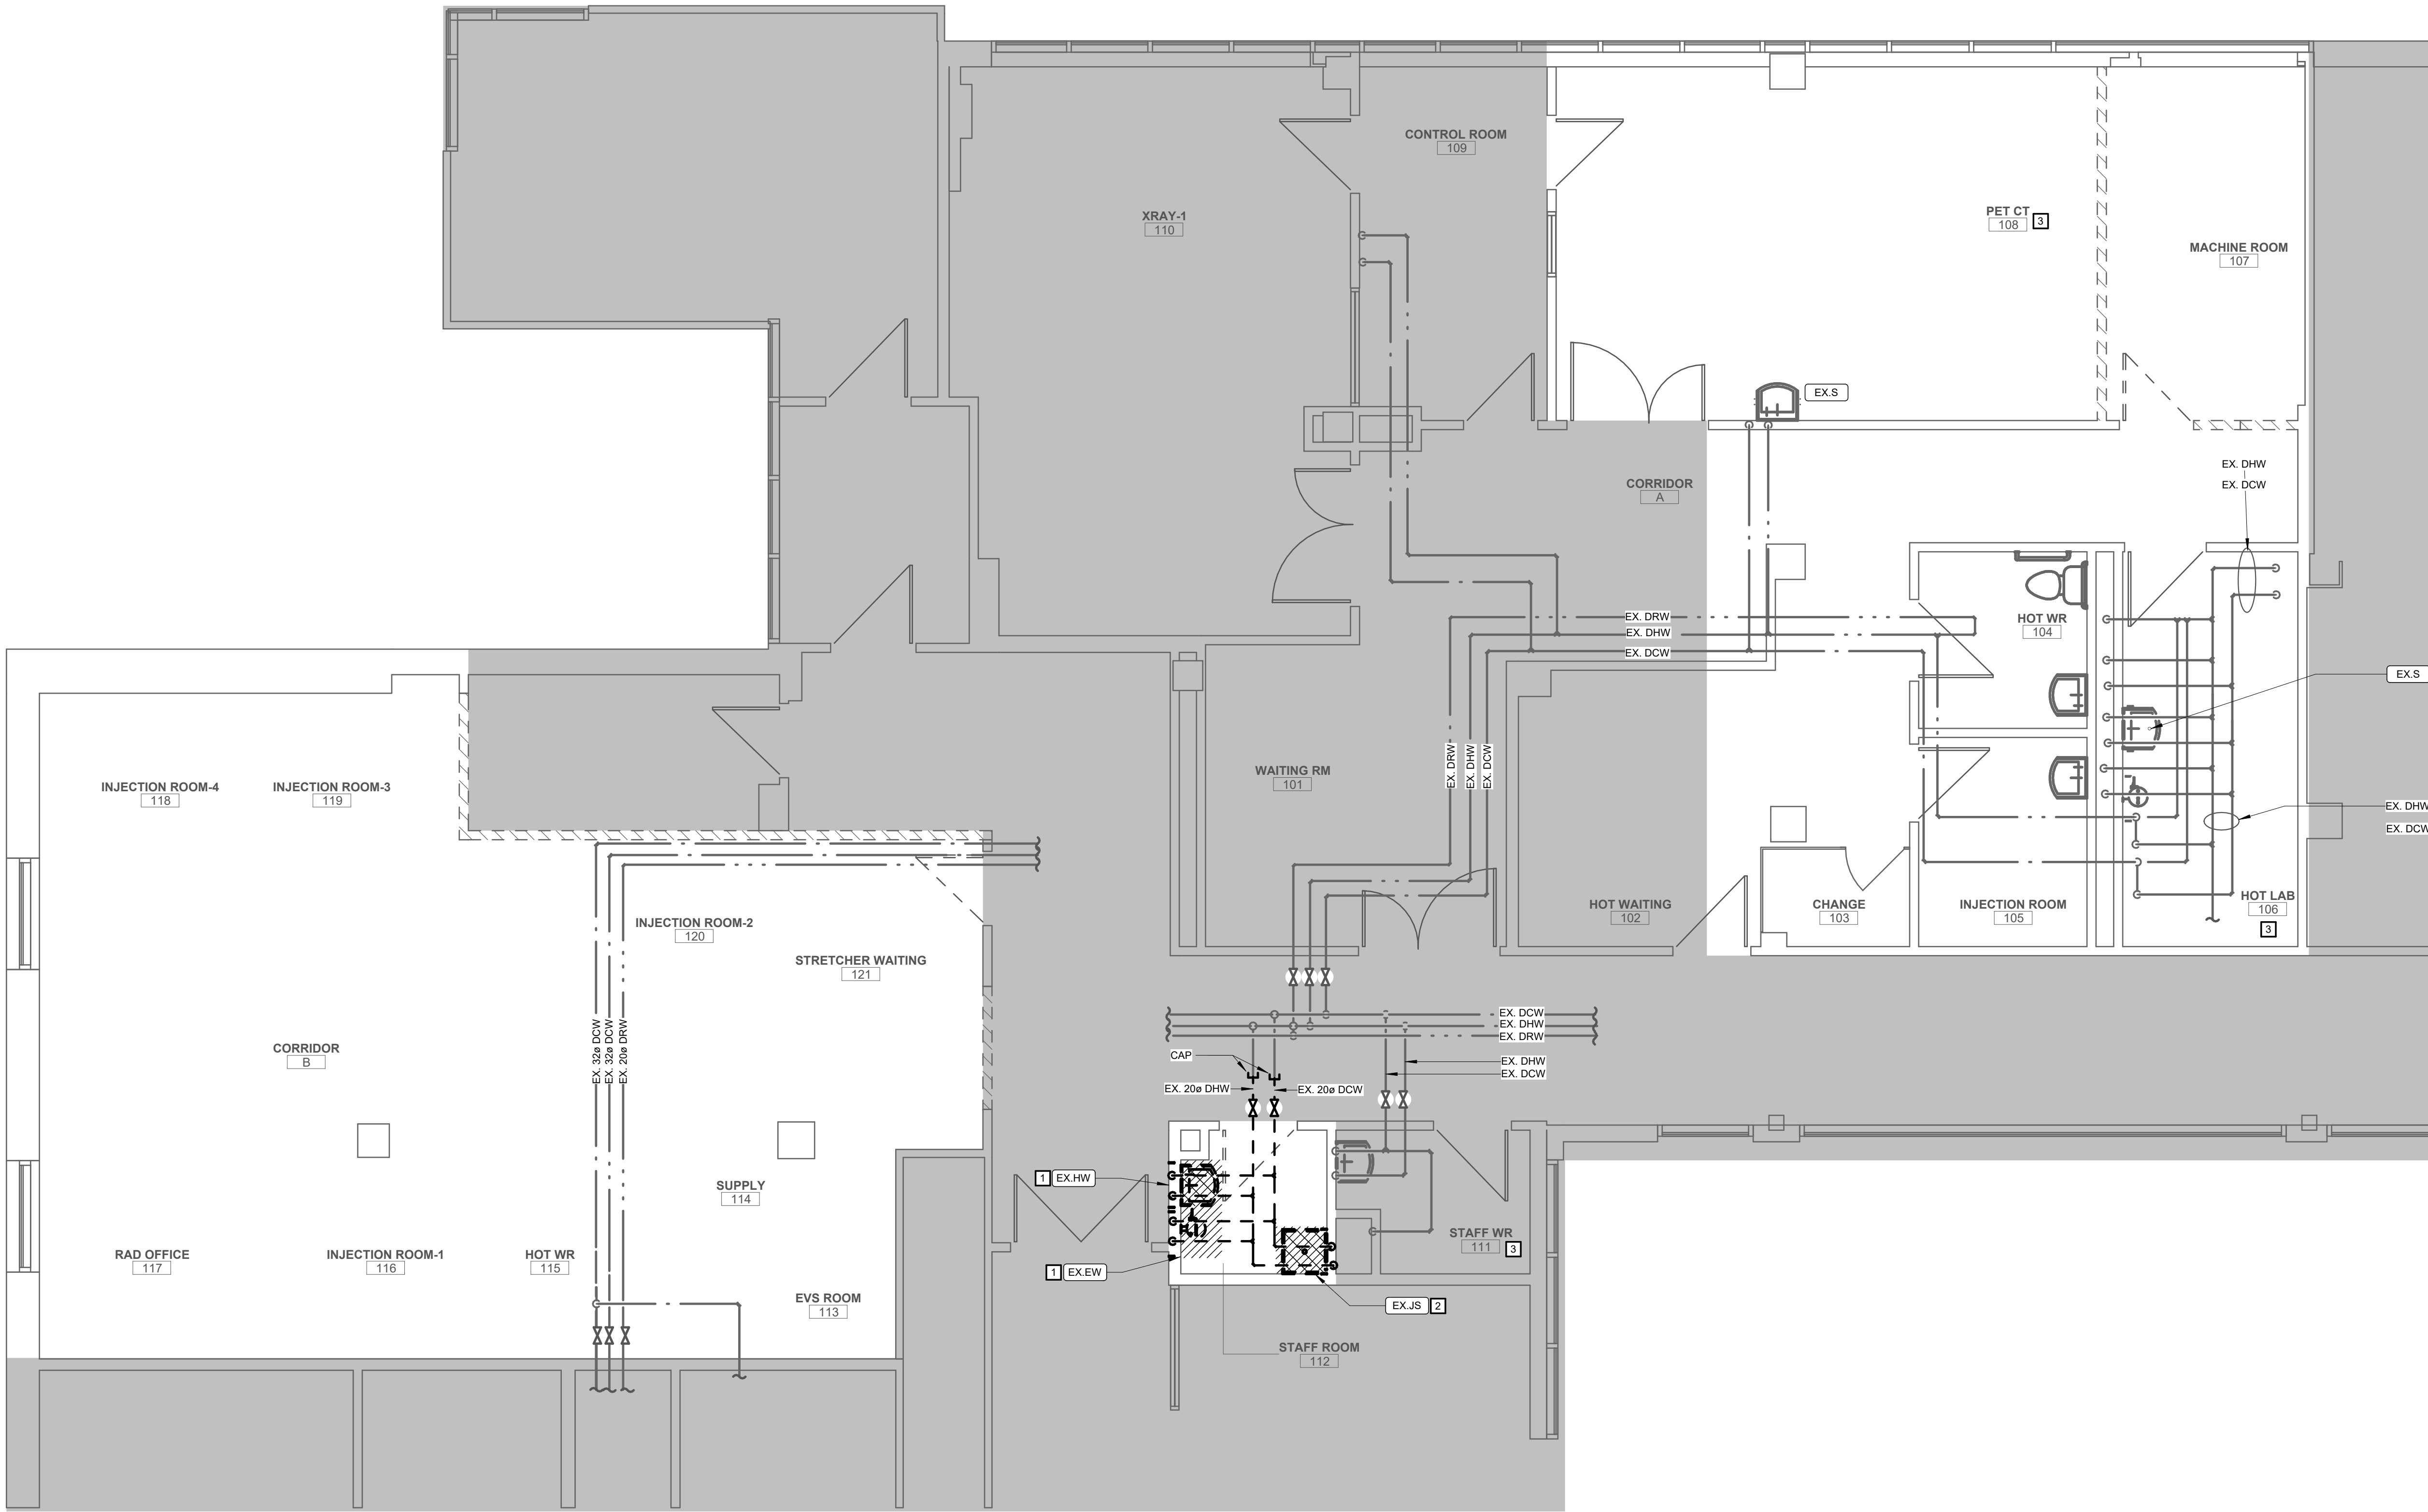

CONSTRUCTION NOTES

A. ALPHABETICAL NOTES ARE GENERAL TO THE PLAN(S) ON THIS SHEET

F

NUMERICAL NOTES ARE KEYED NOTES CORRESPONDING TO KEYED NOTES ON PLAN(S) ON THIS SHEET

B. REFER TO MECHANICAL SPECIFICATION FOR WATER HAMMER REQUIREMENTS.

B. COORDINATE WITH GENERAL CONTRACTOR FOR RELOCATED AND NEW HAND WASH SINK CARRIER REQUIREMENTS.

1. DISCONNECT, REMOVE AND SAVE EXISTING PLUMBING FIXTURE. CAP DOMESTIC HOT & COLD WATER SUPPLY AT MAINS. CAP SANITARY BELOW FINISHED FLOOR. CAP VENTING ABOVE FINISHED CEILING. EXISTING PLUMBING FIXTURE TO BE REUSED IN PROPOSED PLAN REFER TO DRAWING M201.

2. DISCONNECT, REMOVE AND MOP SINK. EXISTING FAUCET TO BE SAVED. CAP DOMESTIC HOT & COLD WATER SUPPLY AT MAINS. CAP SANITARY BELOW FINISHED FLOOR. CAP VENTING ABOVE FINISHED CEILING. EXISTING FAUCET TO BE REUSED IN PROPOSED PLAN REFER TO DRAWING M201.

3. ALL PLUMBING IN THIS ROOM TO REMAIN IN OPERATION.

TO BE DEMOLISHED

WRHN

Waterloo Regional Health Network

PROJECT LOGO

TRUE NORTH

CONSTRUCTION NORTH

AREA OF WORK

KEY PLAN

ISSUED FOR TENDER

(2026.02.27)

7	ISSUED FOR TENDER	2026.04.10
6	ISSUED FOR TENDER	2025.12.12
5	ISSUED FOR PERMIT	2025.11.26
4	FINAL DESIGN DEVELOPMENT SET	2025.11.07
3	100% DESIGN DEVELOPMENT SET	2025.10.31
2	100% DESIGN DEVELOPMENT PROGRESS SET	2025.09.29
1	50% DESIGN DEVELOPMENT PROGRESS SET	2025.05.09

REVISIONS:

DISCREPANCIES MUST BE REPORTED IMMEDIATELY TO THE ARCHITECT/ENGINEER BEFORE PROCEEDING. ONLY FIGURED DIMENSIONS MUST BE USED. THE CONTRACTOR MUST CHECK THE DIMENSIONS ON SITE. THE DRAWING IS PROTECTED BY COPYRIGHT. ALL DIMENSIONS ARE SHOWN IN MILLIMETERS. DO NOT SCALE THE DRAWINGS.

mcCallumSather

Westinghouse HQ, 2nd Floor
286 Sanford Ave. N
Hamilton, ON L8L 6A1
905.526.6700
www.mccallumsather.com

PROJECT:

WATERLOO REGIONAL HEALTH NETWORK @ MODTPWN - PET CT

835 KING ST W, KITCHENER, ON N2G 1G

DRAWING TITLE:

LEVEL 2 PLUMBING DEMO PLAN

DRAWN BY:	SB.MC	DATE:	2024/09/01
CHECKED BY:	DR. AB	SCALE:	As indicated


PROJECT NO:

24048

DRAWING NO:

M200

D 610d14

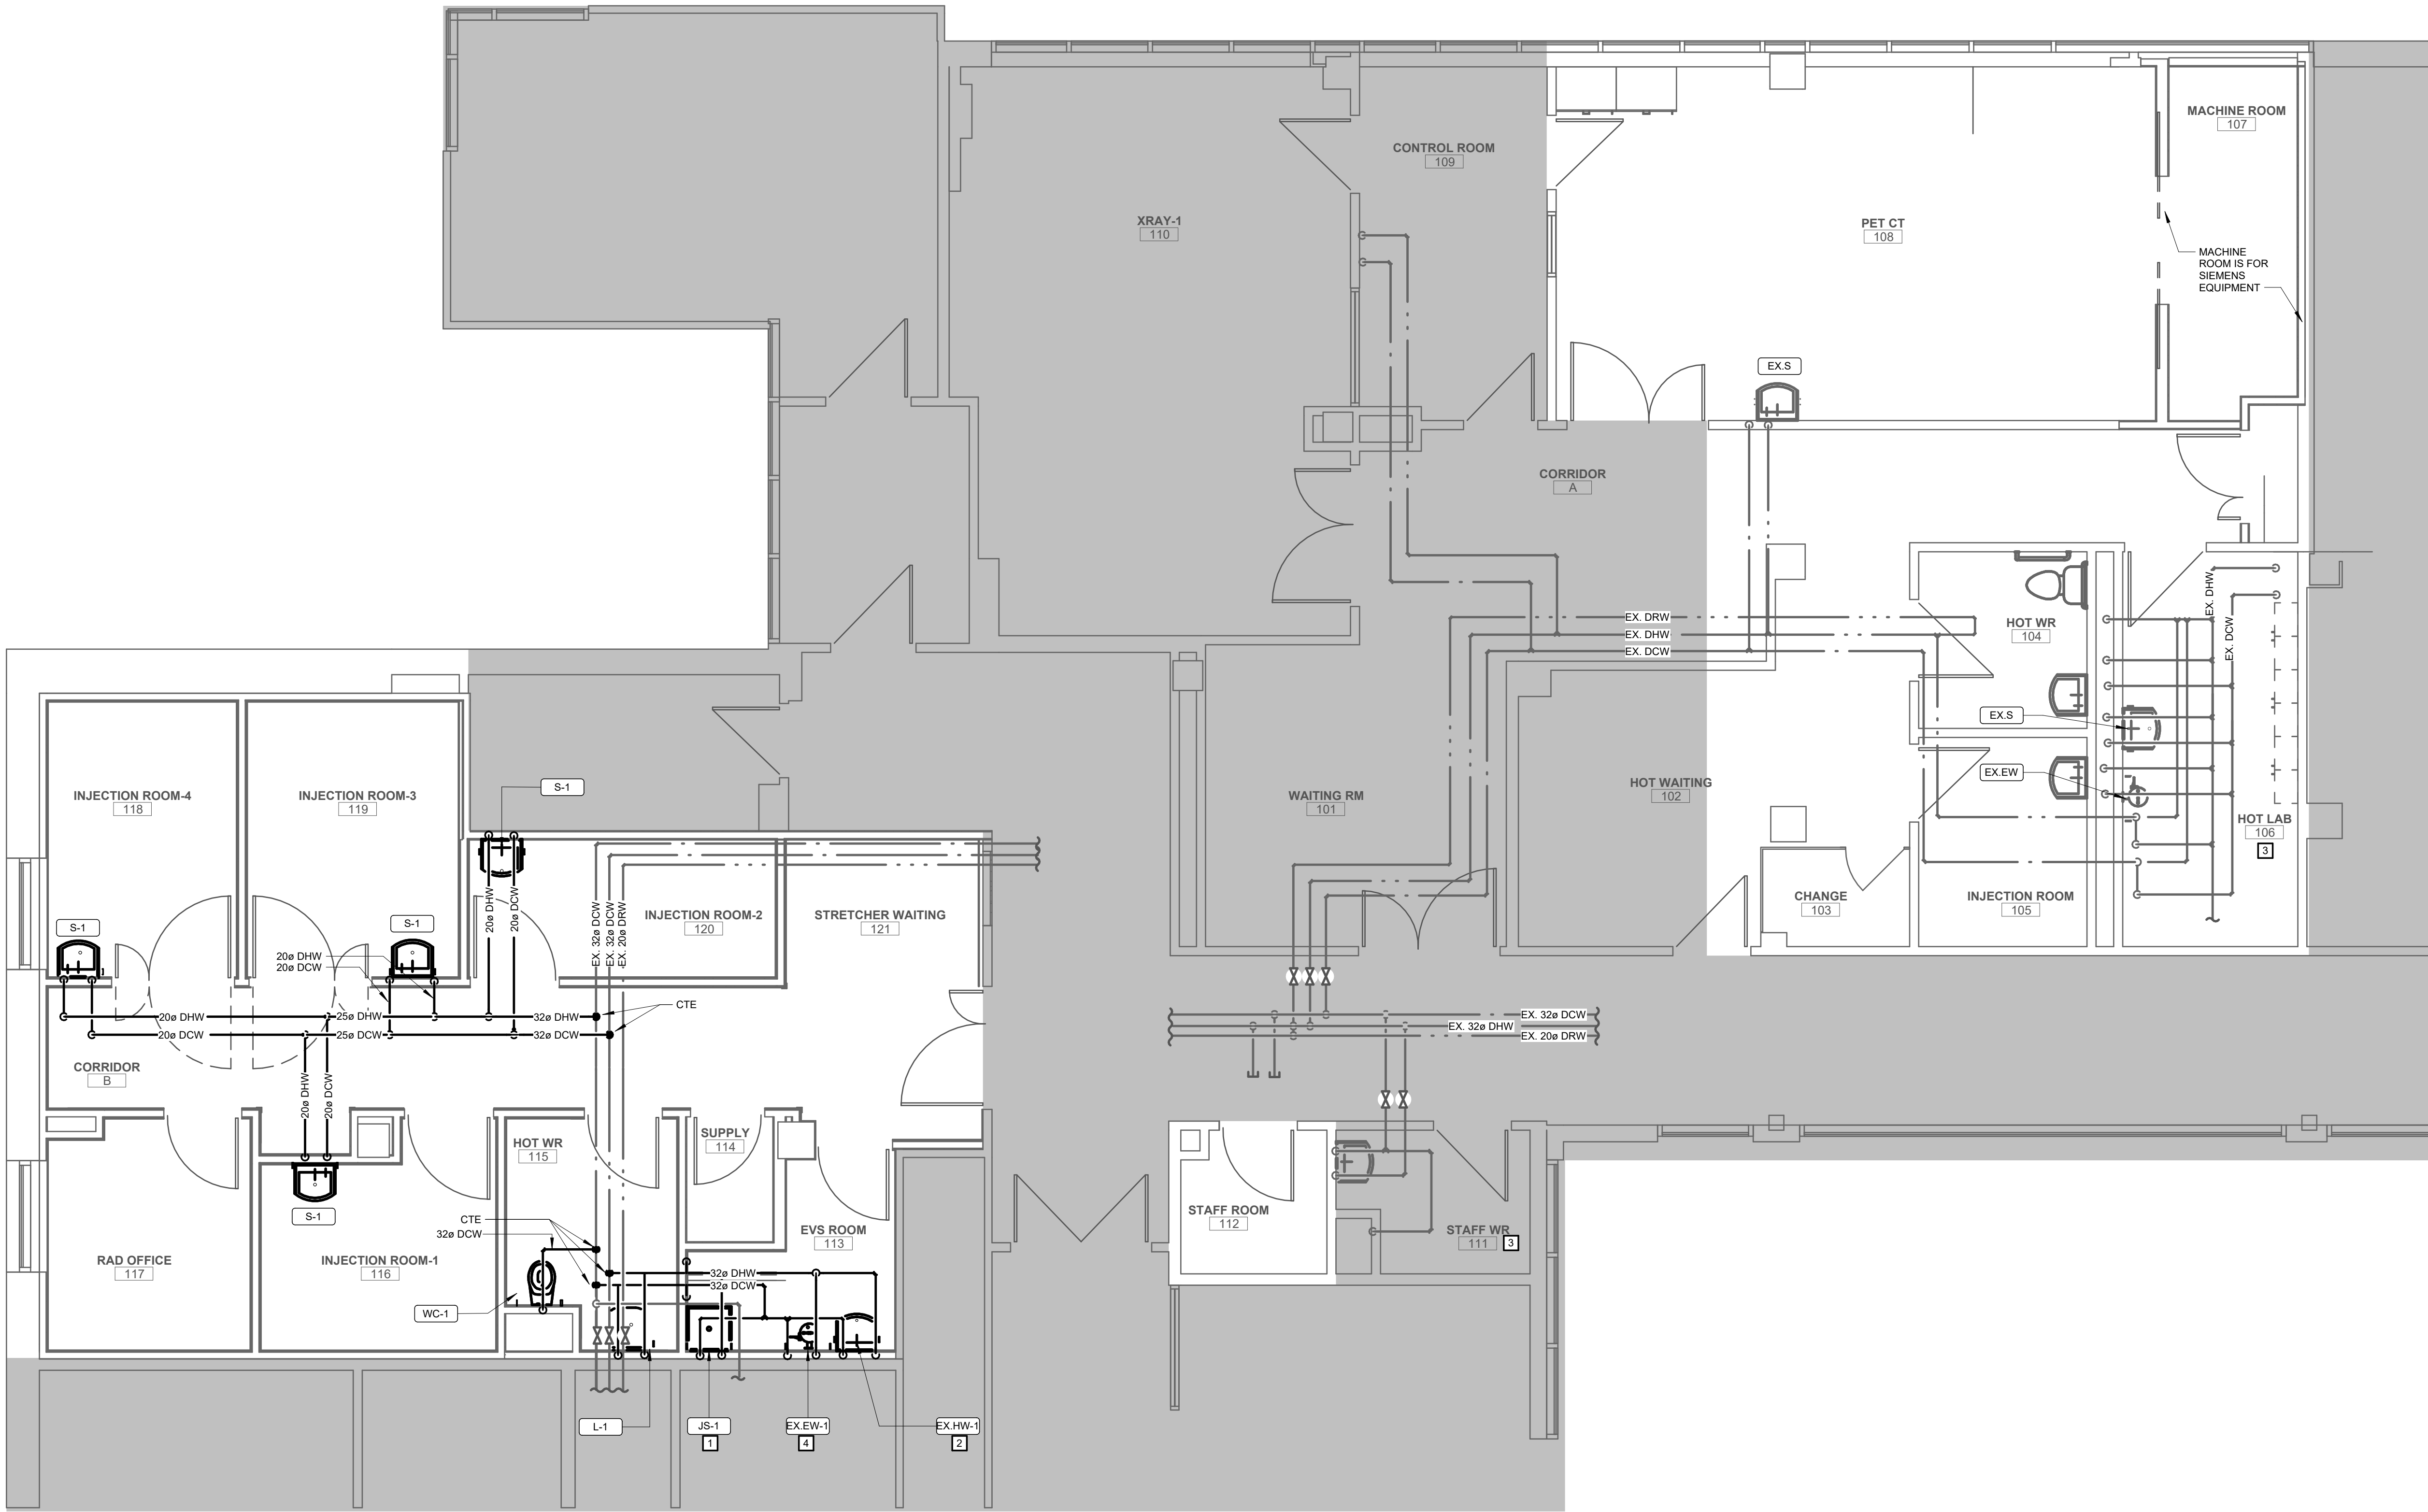

LEVEL 2 PLUMBING PROPOSED PLAN
1:50 M201


CONSTRUCTION NOTES

- A. ALPHABETICAL NOTES ARE GENERAL TO THE PLAN(S) ON THIS SHEET
- B. NUMERICAL NOTES ARE KEYED NOTES CORRESPONDING TO KEYED NOTES ON PLAN(S) ON THIS SHEET
- A. REFER TO MECHANICAL SPECIFICATION FOR WATER HAMMER REQUIREMENTS.
- B. COORDINATE WITH GENERAL CONTRACTOR FOR RELOCATED AND NEW HAND WASH SINK CARRIER REQUIREMENTS.
- C. ALL S-1 SINKS COME COMPLETE WITH SENSOR ACTIVATED FAUCETS.
1. REUSE EXISTING FAUCET, MECHANICAL CONTRACTOR TO SUPPLY AND INSTALL NEW MOP SINK BASIN AS SCHEDULED.
2. REUSE EXISTING HANDWASH SINK, FAUCET AND ACCESSORIES IN NEW LOCATION SHOWN ON THE PLAN.
3. ALL PLUMBING IN THIS ROOM TO REMAIN IN OPERATION.
4. RELOCATED EYEWASH STATION TO NEW LOCATION SHOWN ON THE PLAN. CONTRACTOR TO VERIFY THE OPERATION AND TEMPERATURE CONTROL REPORT ANY DISCREPANCY TO THE ENGINEER.

TO BE DEMOLISHED



PROJECT LOGO

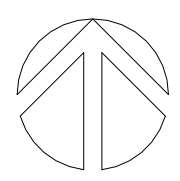

KEY PLAN

ISSUED FOR TENDER
(2026.02.27)

7	ISSUED FOR TENDER	2026.04.10
6	ISSUED FOR TENDER	2025.12.12
5	ISSUED FOR PERMIT	2025.11.26
4	FINAL DESIGN DEVELOPMENT SET	2025.11.07
3	100% DESIGN DEVELOPMENT SET	2025.10.31
2	100% DESIGN DEVELOPMENT PROGRESS SET	2025.09.29
1	50% DESIGN DEVELOPMENT PROGRESS SET	2025.05.09

No.	DESCRIPTION	DATE
-----	-------------	------

REVISIONS:

DISCREPANCIES MUST BE REPORTED IMMEDIATELY TO THE ARCHITECT/ENGINEER BEFORE PROCEEDING.

ONLY FIGURED DIMENSIONS MUST BE USED.

THE CONTRACTOR MUST CHECK THE DIMENSIONS ON SITE.

THE DRAWING IS PROTECTED BY COPYRIGHT.

ALL DIMENSIONS ARE SHOWN IN MILLIMETERS.

DO NOT SCALE THE DRAWINGS.

mcCallumSather
Westinghouse HQ, 2nd Floor
286 Sanford Ave. N
Hamilton, ON L8L 6A1
905.526.6700
www.mccallumsather.com

SEAL

CONSULTANTS:

PROJECT:
WATERLOO REGIONAL HEALTH NETWORK @ MODTPWN - PET CT


835 KING ST W, KITCHENER, ON N2G 1G

DRAWING TITLE:
LEVEL 2 PLUMBING PROPOSED PLAN

DRAWN BY:	SB.MC	DATE:	2024/09/01
CHECKED BY:	DR. AB	SCALE:	As indicated

PROJECT NO: **24048**

DRAWING NO: **M201**

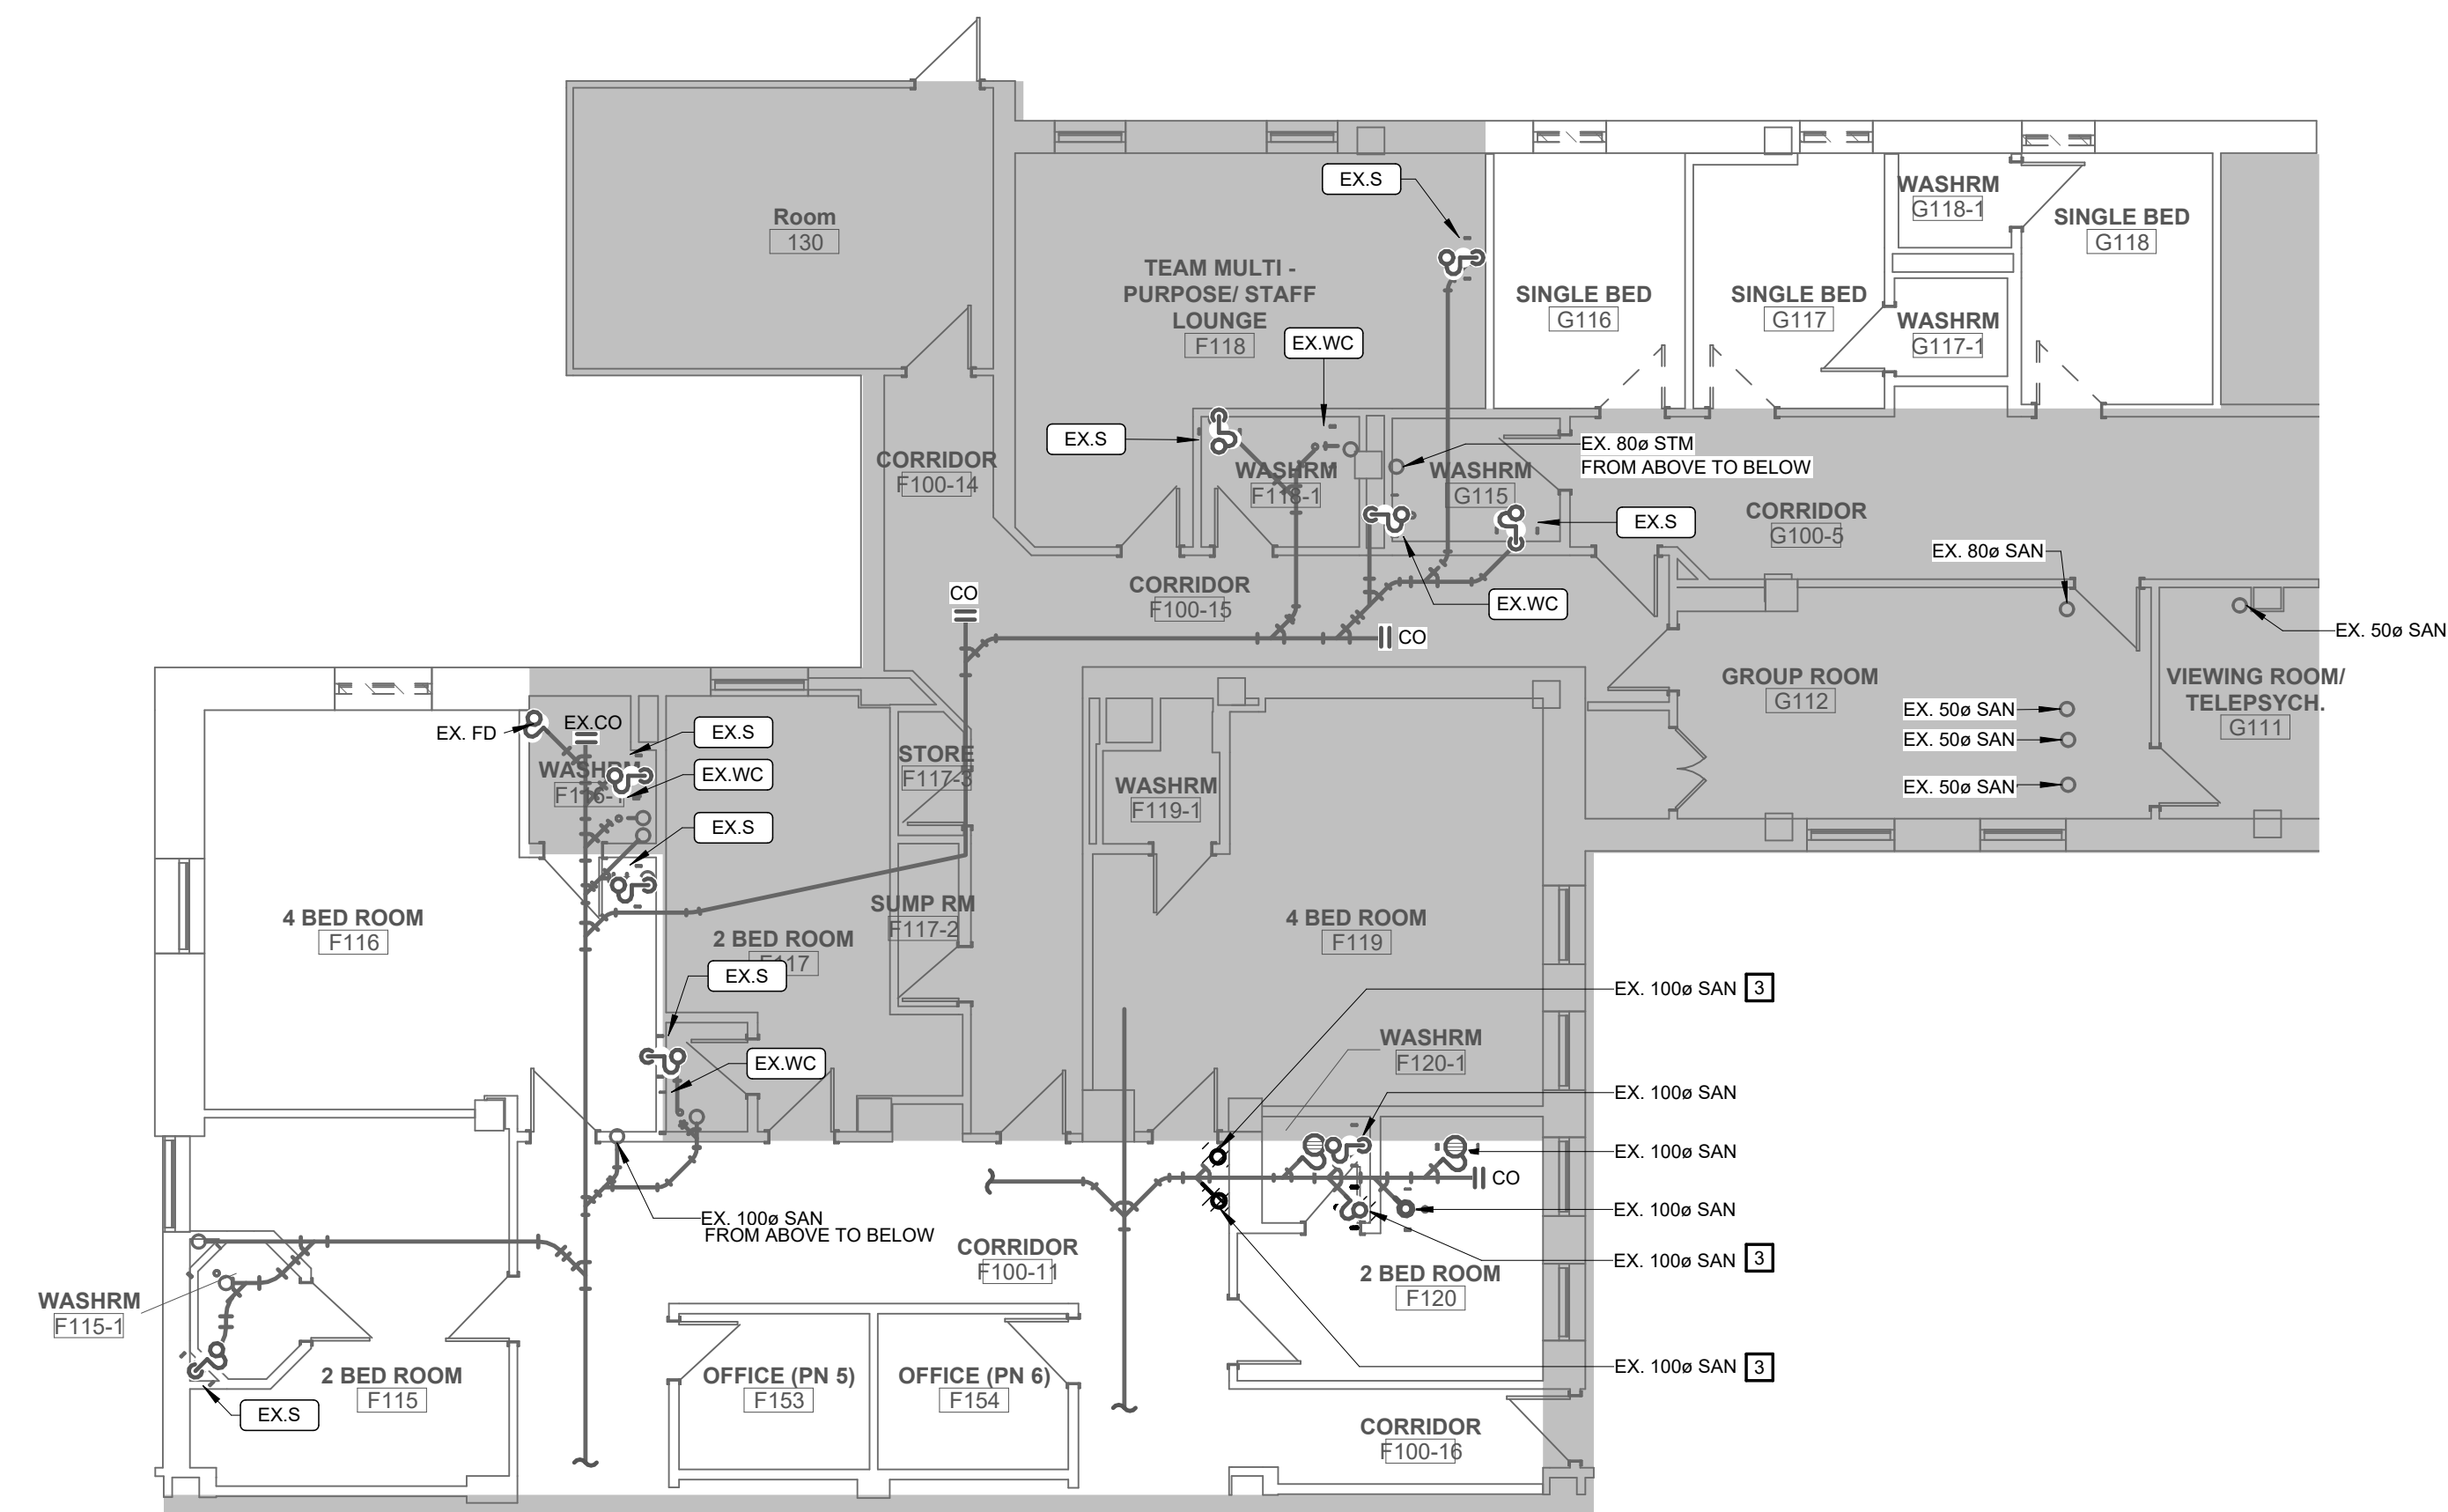


LEVEL 1 DRAINAGE DEMO PLAN

1 : 100

2

M300

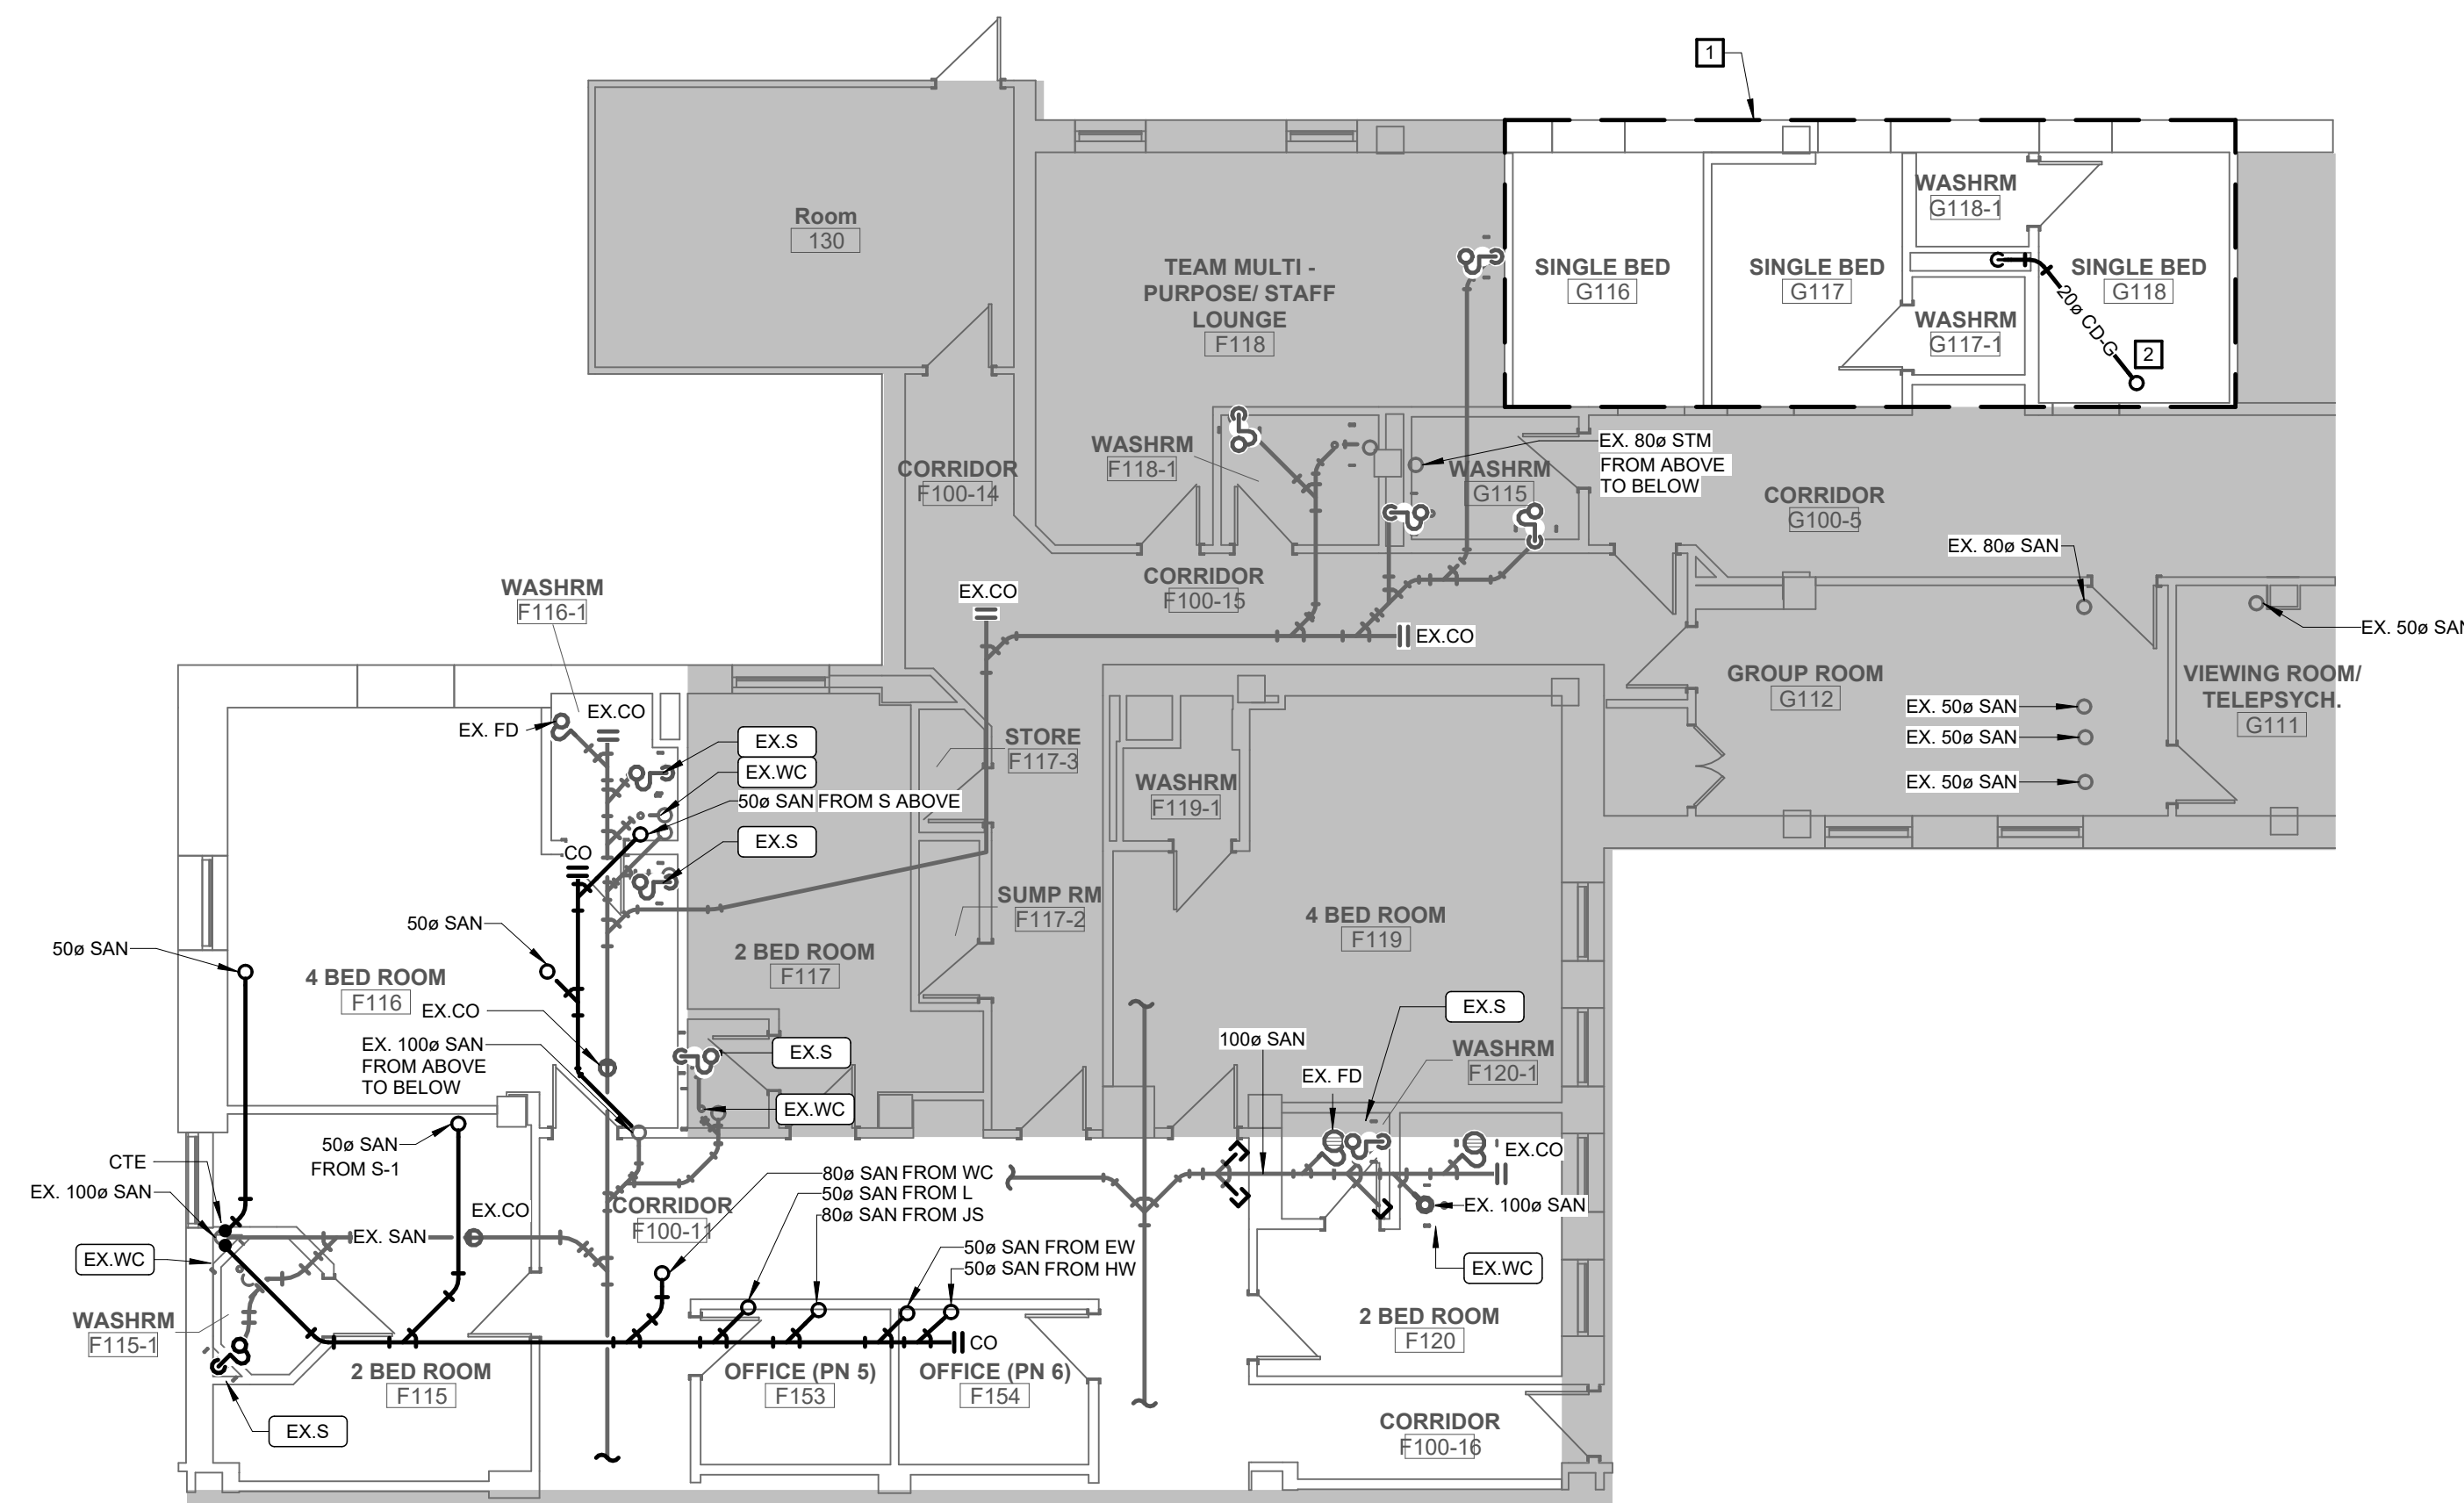

LEVEL 1 DRAINAGE PLAN

1 : 100

1

M300

CONSTRUCTION NOTES


- | | |
|----------|--|
| A. | ALPHABETICAL NOTES ARE GENERAL TO THE PLAN(S) ON THIS SHEET |
| # | NUMERICAL NOTES ARE KEYED NOTES CORRESPONDING TO KEYED NOTES ON PLAN(S) ON THIS SHEET |
| A. | MECHANICAL CONTRACTOR TO SCAN/RYE PRIOR RO ANY SAW CUTTING OF THE LEVEL 1 FLOOR. |
| B. | PROVIDE CLEANOUT AT NEW INSTALLED TOILETS. |
| C. | MECHANICAL CONTRACTOR TO VERIFY FLOW DIRECTION PRIOR TO FINAL CONNECTION. |
| 1. | REFER TO ARCHITECTURAL DRAWINGS FOR CONTRACTOR ACCESS TO THIS AREA. |
| 2. | 20MM CONDENSATE FROM 'AC' F FROM WITHIN NB WALL ABOVE CONNECT TO THE SANITARY WITHIN WASHROOM VENT WALL. |
| 3. | CAPPED AT MAINS IN LEVEL 1 CEILING SPACE. REFER TO DRAWING M200 FOR FIXTURE DEMO NOTES. |



PROJECT LOGO



CONSTRUCTION NORTH

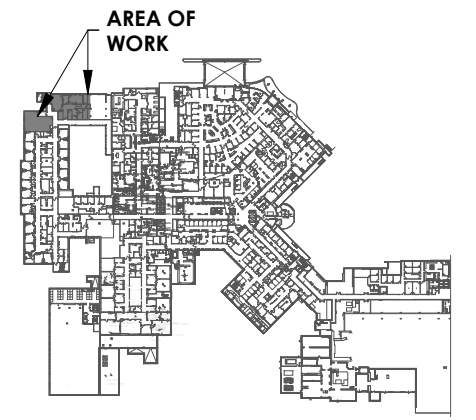

KEY PLAN

**ISSUED FOR TENDER
(2026.02.27)**

7	ISSUED FOR TENDER	2026.04.10
6	ISSUED FOR TENDER	2025.12.12
5	ISSUED FOR PERMIT	2025.11.28
4	FINAL DESIGN DEVELOPMENT SET	2025.11.07
3	100% DESIGN DEVELOPMENT SET	2025.10.31
2	100% DESIGN DEVELOPMENT PROGRESS SET	2025.09.29
1	50% DESIGN DEVELOPMENT PROGRESS SET	2025.05.09
No.	DESCRIPTION	DATE

REVISIONS:

DISCREPANCIES MUST BE REPORTED IMMEDIATELY TO THE ARCHITECT / ENGINEER BEFORE PROCEEDING.

ONLY FIGURED DIMENSIONS MUST BE USED.

THE CONTRACTOR MUST CHECK THE DIMENSIONS ON SITE.

THE DRAWING IS PROTECTED BY COPYRIGHT.

ALL DIMENSIONS ARE SHOWN IN MILLIMETERS.

DO NOT SCALE THE DRAWINGS.

mcCallumSather
Westinghouse HQ, 2nd Floor
286 Sanford Ave. N
Hamilton, ON L8L 6A1
905.526.6700
www.mccallumsather.com

SEAL

CONSULTANTS:

PROJECT:

WATERLOO REGIONAL HEALTH
NETWORK @ MODTPWN - PET CT

835 KING ST W, KITCHENER, ON
N2G 1G

DRAWING TITLE:
**LEVEL 1 DRAINAGE DEMO &
PROPOSED PLAN**


DRAWN BY:	DATE:
-----------	-------

SB/MC	2024/09/01
CHECKED BY:	SCALE:

PROJECT NO.: 24048

DRAWING NO.:


M300

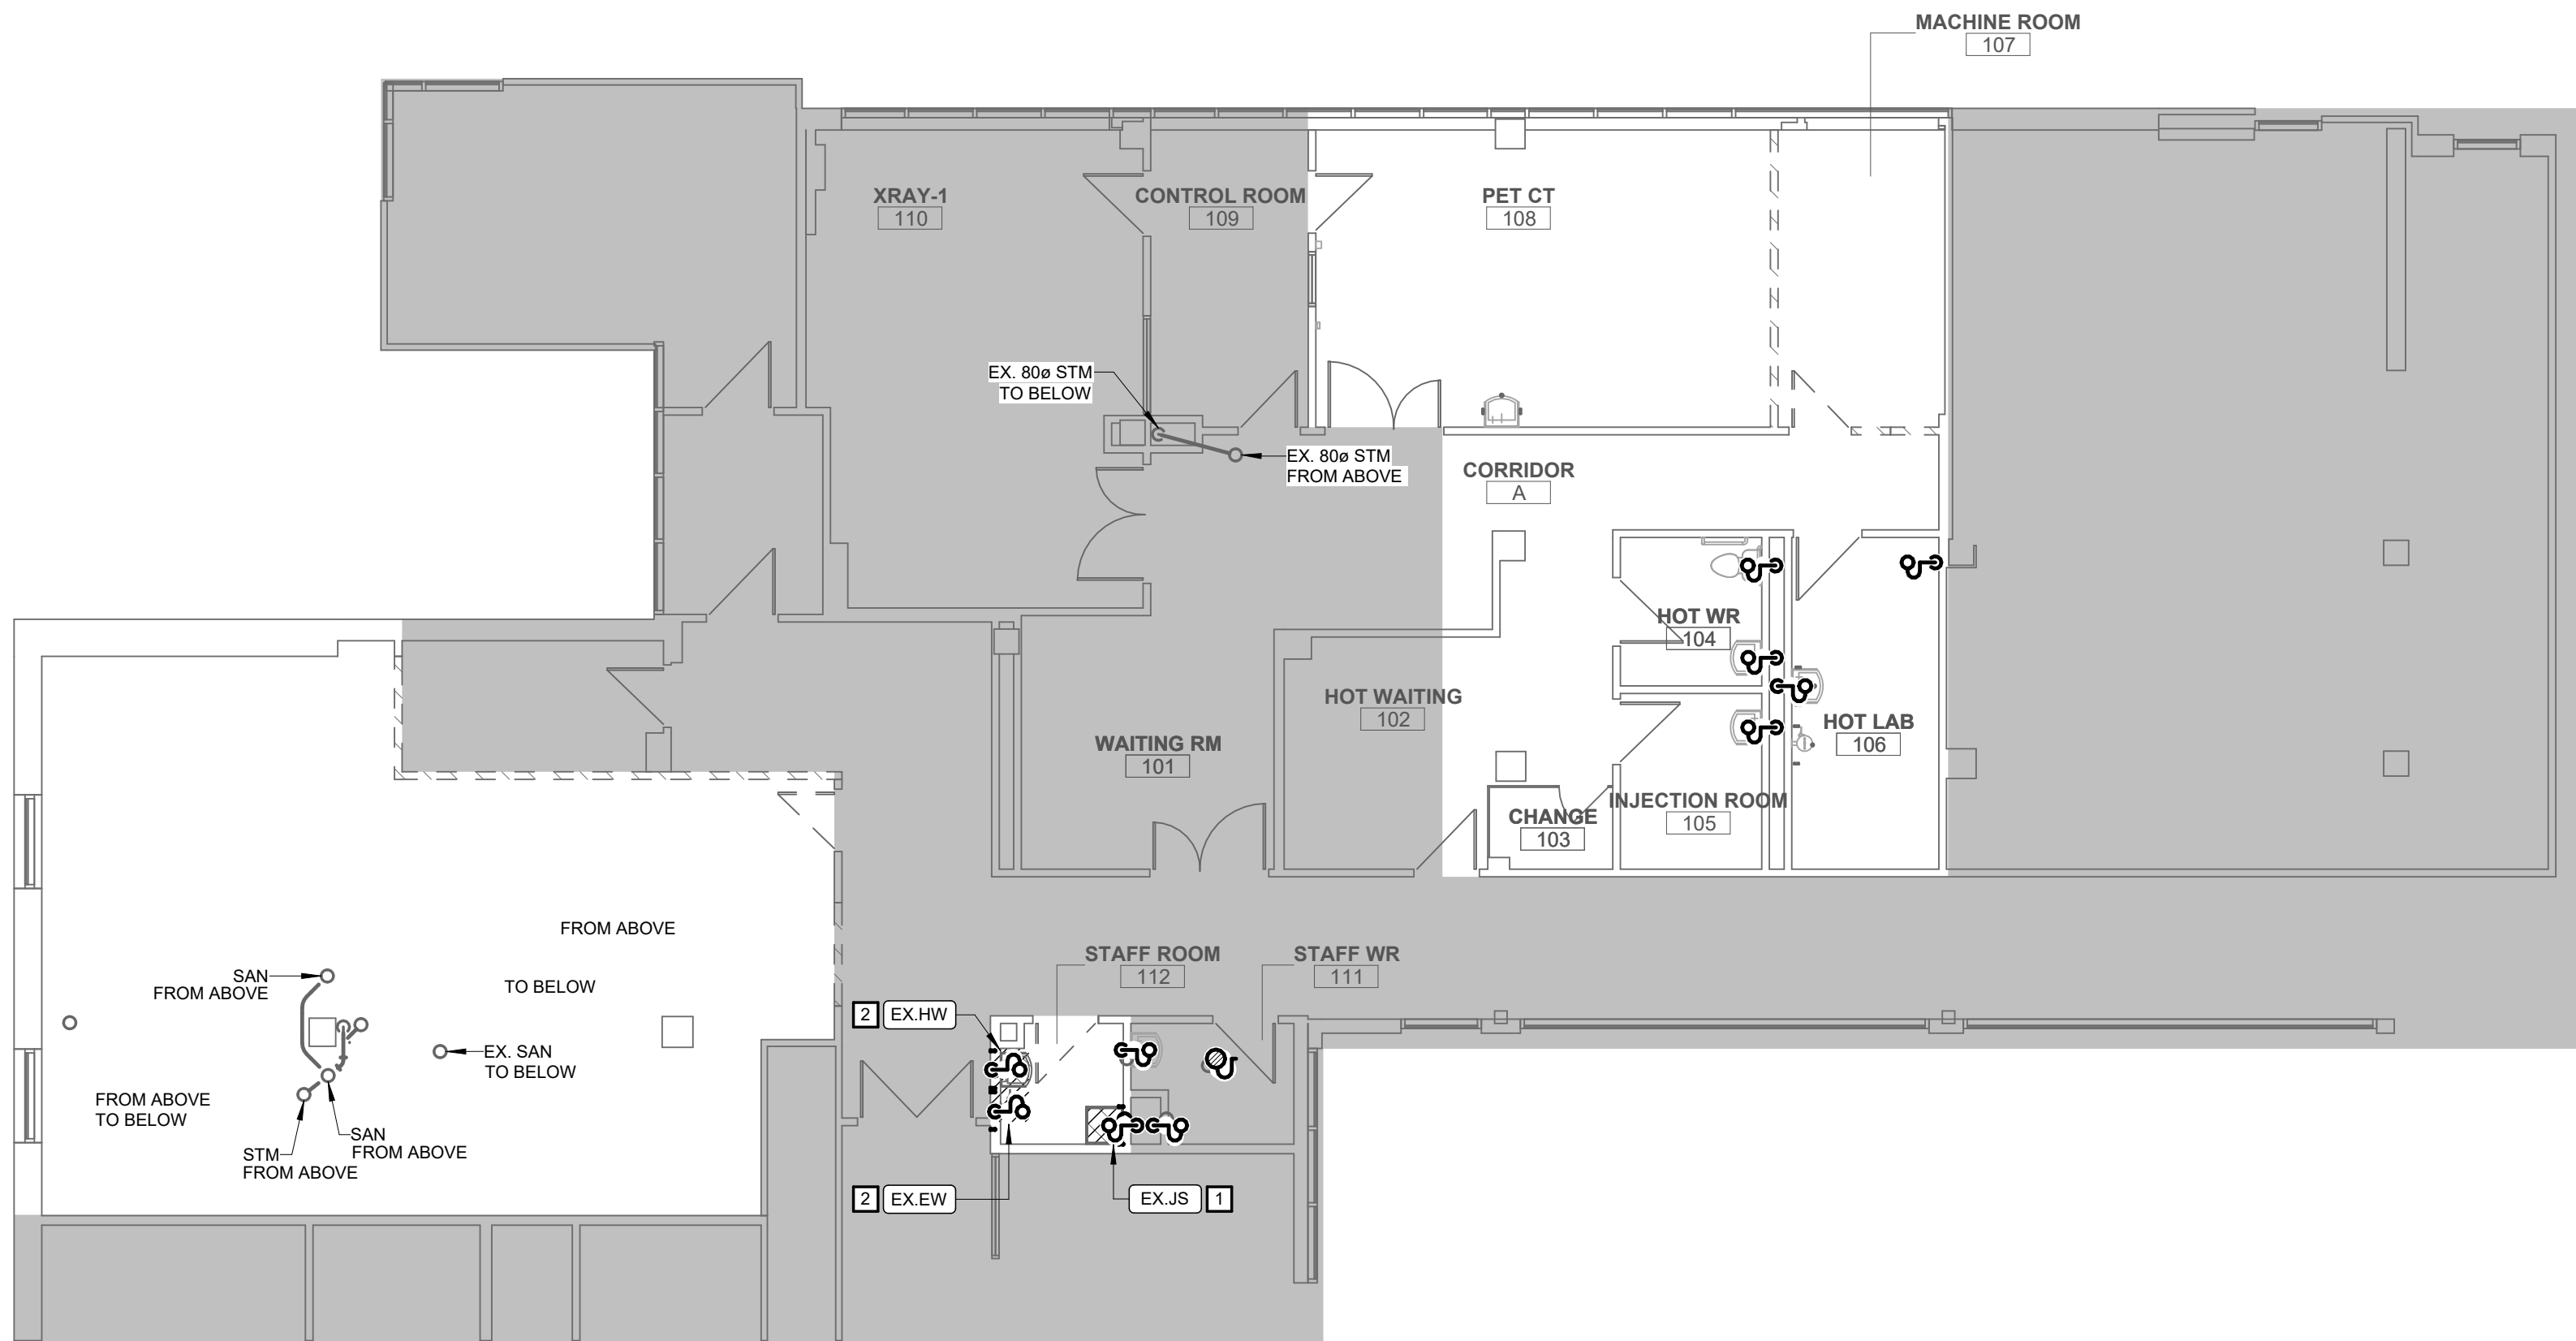

LEVEL 2 DRAINAGE DEMO PLAN

1 : 100

1
M301

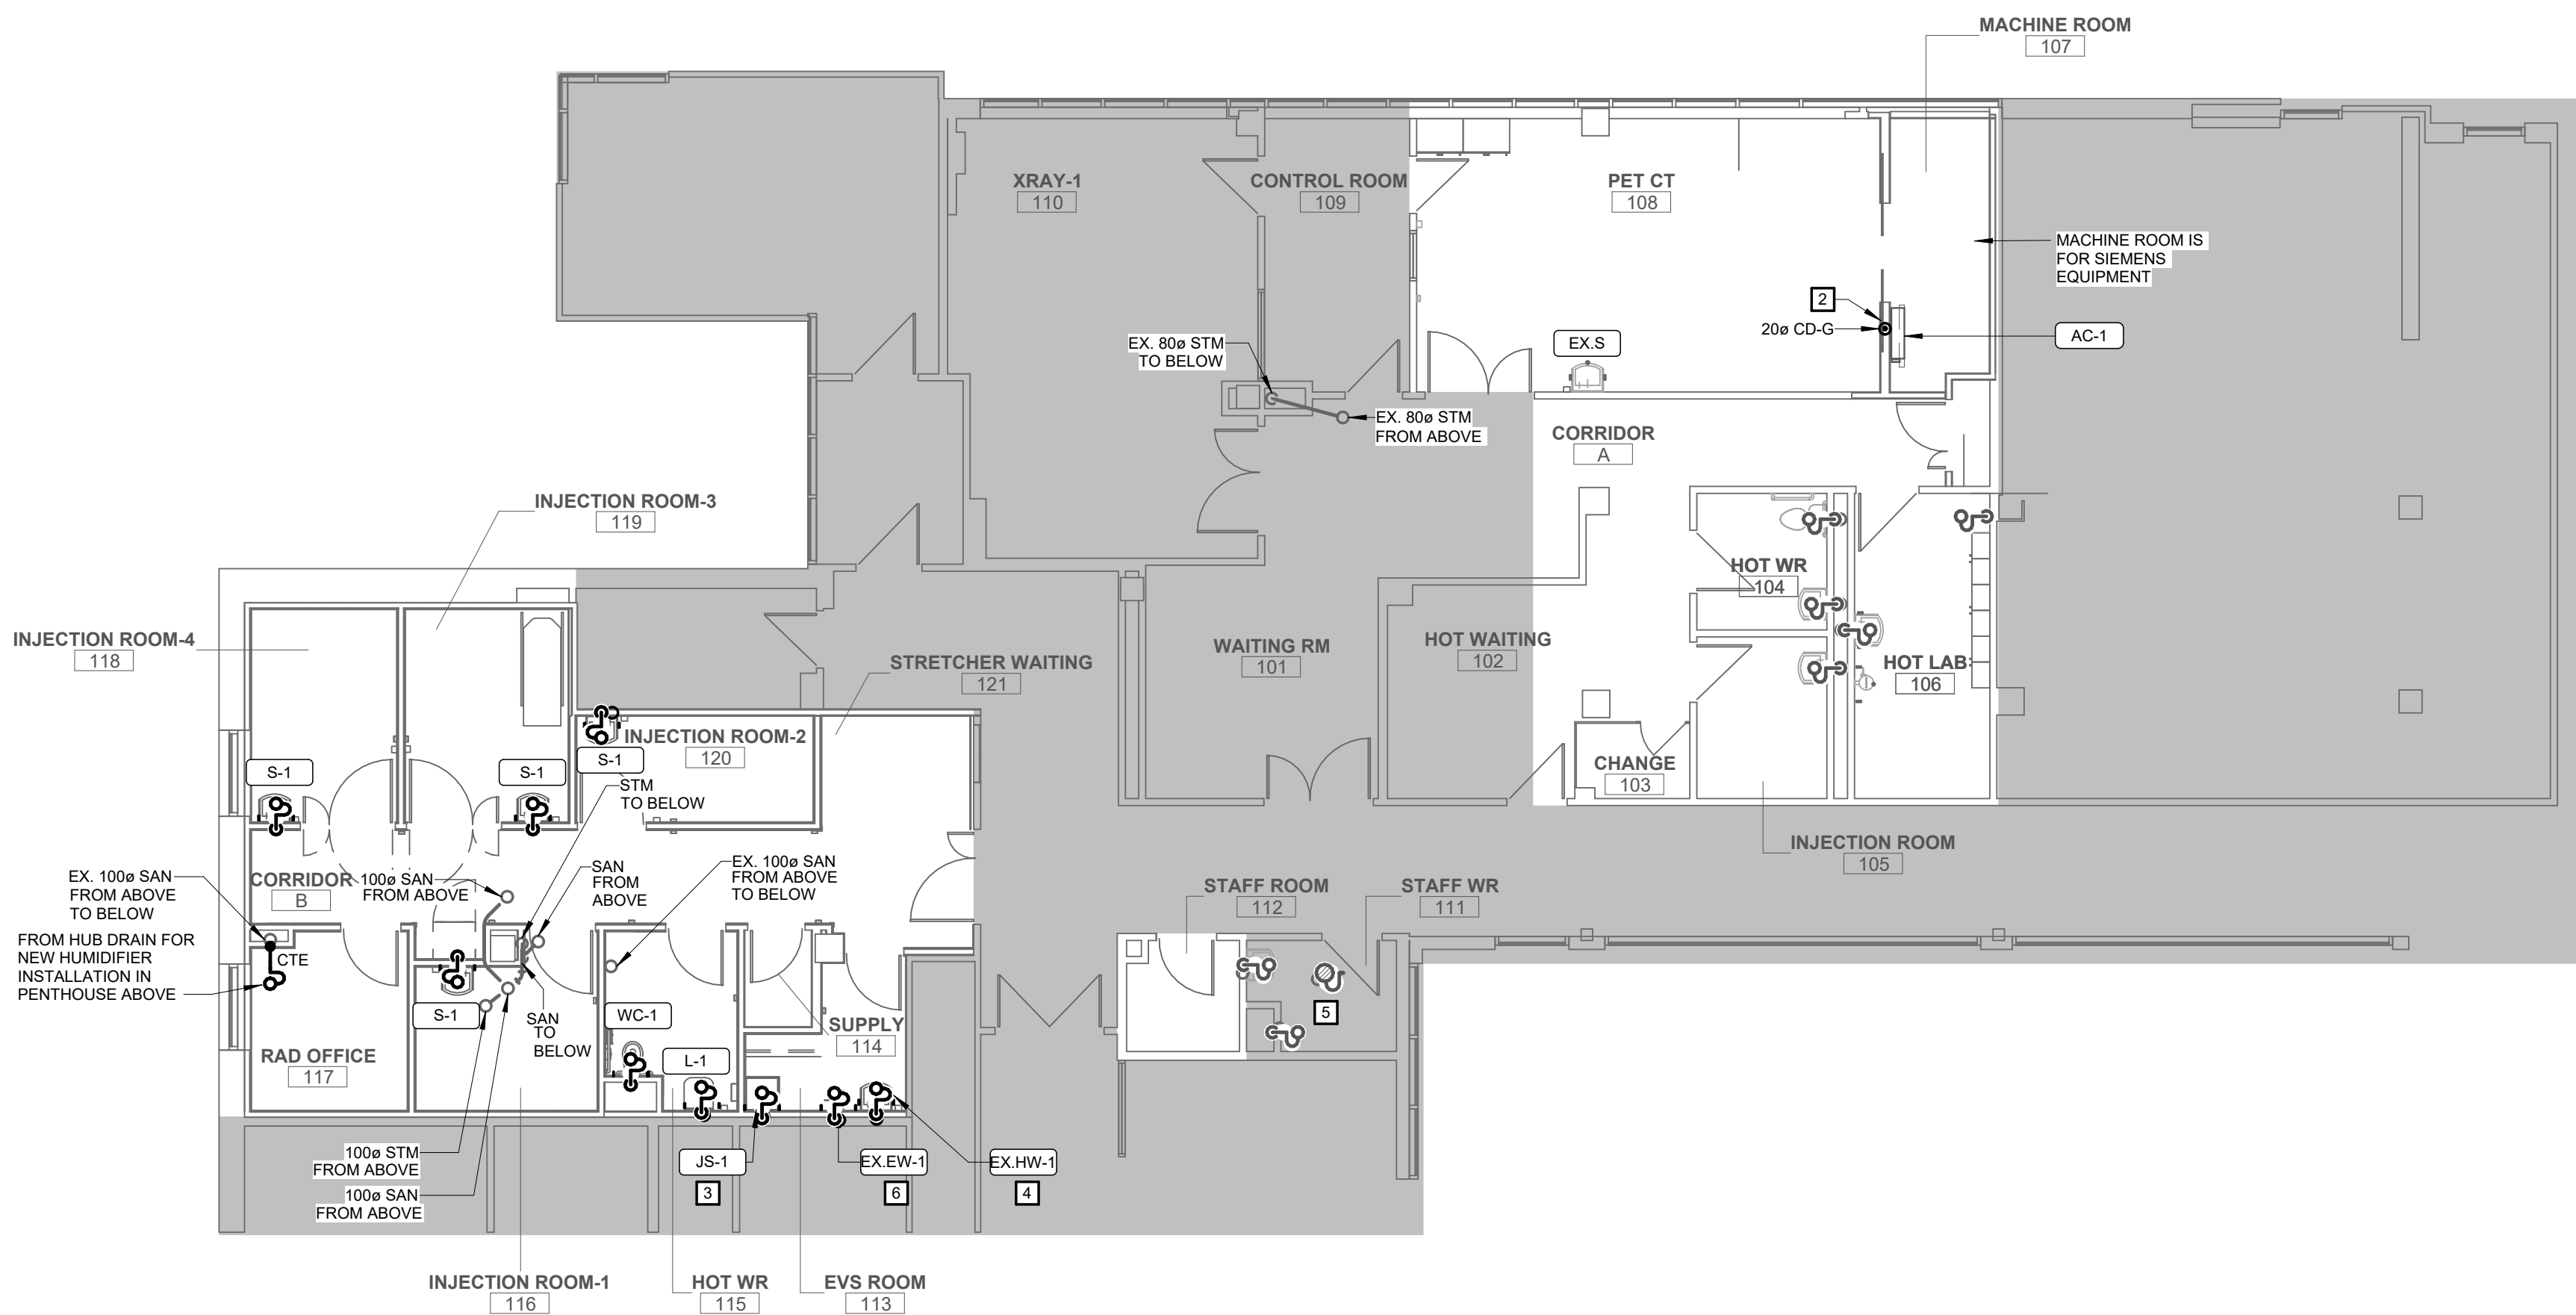

LEVEL 2 DRAINAGE PROPOSED PLAN

1 : 100

2
M301



CONSTRUCTION NOTES

- A. ALPHABETICAL NOTES ARE GENERAL TO THE PLAN(S) ON THIS SHEET
- B. NUMERICAL NOTES ARE KEYED NOTES CORRESPONDING TO KEYED NOTES ON PLAN(S) ON THIS SHEET
- A. PROVIDE CLEANOUT AT NEW INSTALLED TOILETS
1. RELOCATE EXISTING PLUMBING FIXTURE TO NEW EVS ROOM
 2. 20MM CONDENSATE DRAIN TO CEILING SPACE BELOW.
 3. REUSE EXISTING FAUCET, MECHANICAL CONTRACTOR TO SUPPLY AND INSTALL NEW MOP SINK BASIN AS SCHEDULED.
 4. REUSE EXISTING HANDWASH SINK, FAUCET AND ACCESSORIES TO THE NEW LOCATION SHOWN ON THE PLAN.
 5. ALL PLUMBING IN THIS ROOM TO REMAIN OPERATIONAL.
 6. RELOCATED EYEWASH STATION TO THE LOCATION SHOWN ON THE PLAN. CONTRACTOR TO VERIFY THE OPERATION AND TEMPERATURE. REPORT ANY DISCREPANCY TO THE ENGINEER.

TO BE DEMOLISHED



PROJECT LOGO

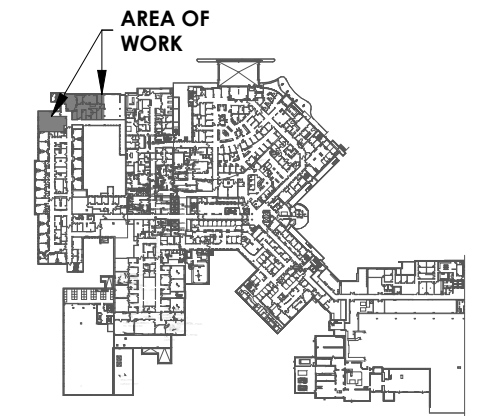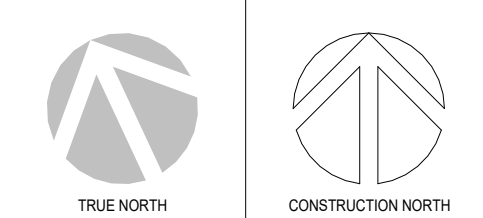

KEY PLAN

ISSUED FOR TENDER
(2026.02.27)

7	ISSUED FOR TENDER	2026.04.10
6	ISSUED FOR TENDER	2025.12.12
5	ISSUED FOR PERMIT	2025.11.26
4	FINAL DESIGN DEVELOPMENT SET	2025.11.07
3	100% DESIGN DEVELOPMENT SET	2025.10.31
2	100% DESIGN DEVELOPMENT PROGRESS SET	2025.09.29
1	50% DESIGN DEVELOPMENT PROGRESS SET	2025.05.09

No.	DESCRIPTION	DATE
-----	-------------	------

REVISIONS:

DISCREPANCIES MUST BE REPORTED IMMEDIATELY TO THE ARCHITECT / ENGINEER BEFORE PROCEEDING. ONLY FIGURED DIMENSIONS MUST BE USED. THE CONTRACTOR MUST CHECK THE DIMENSIONS ON SITE. THE DRAWING IS PROTECTED BY COPYRIGHT. ALL DIMENSIONS ARE SHOWN IN MILLIMETERS. DO NOT SCALE THE DRAWINGS.

mcCallumSather
Westinghouse HQ, 2nd Floor
286 Sanford Ave. N
Hamilton, ON L8L 6A1
905.526.6700
www.mccallumsather.com

SEAL

CONSULTANTS:

PROJECT:
WATERLOO REGIONAL HEALTH NETWORK @ MODTPWN - PET CT


835 KING ST W, KITCHENER, ON
N2G 1G

DRAWING TITLE:
LEVEL 2 DRAINAGE DEMO & PROPOSED PLAN

DRAWN BY:	SB.MC	DATE:	2024/09/01
CHECKED BY:	DR. AB	SCALE:	As indicated


PROJECT NO: **24048**

DRAWING NO: **M301**

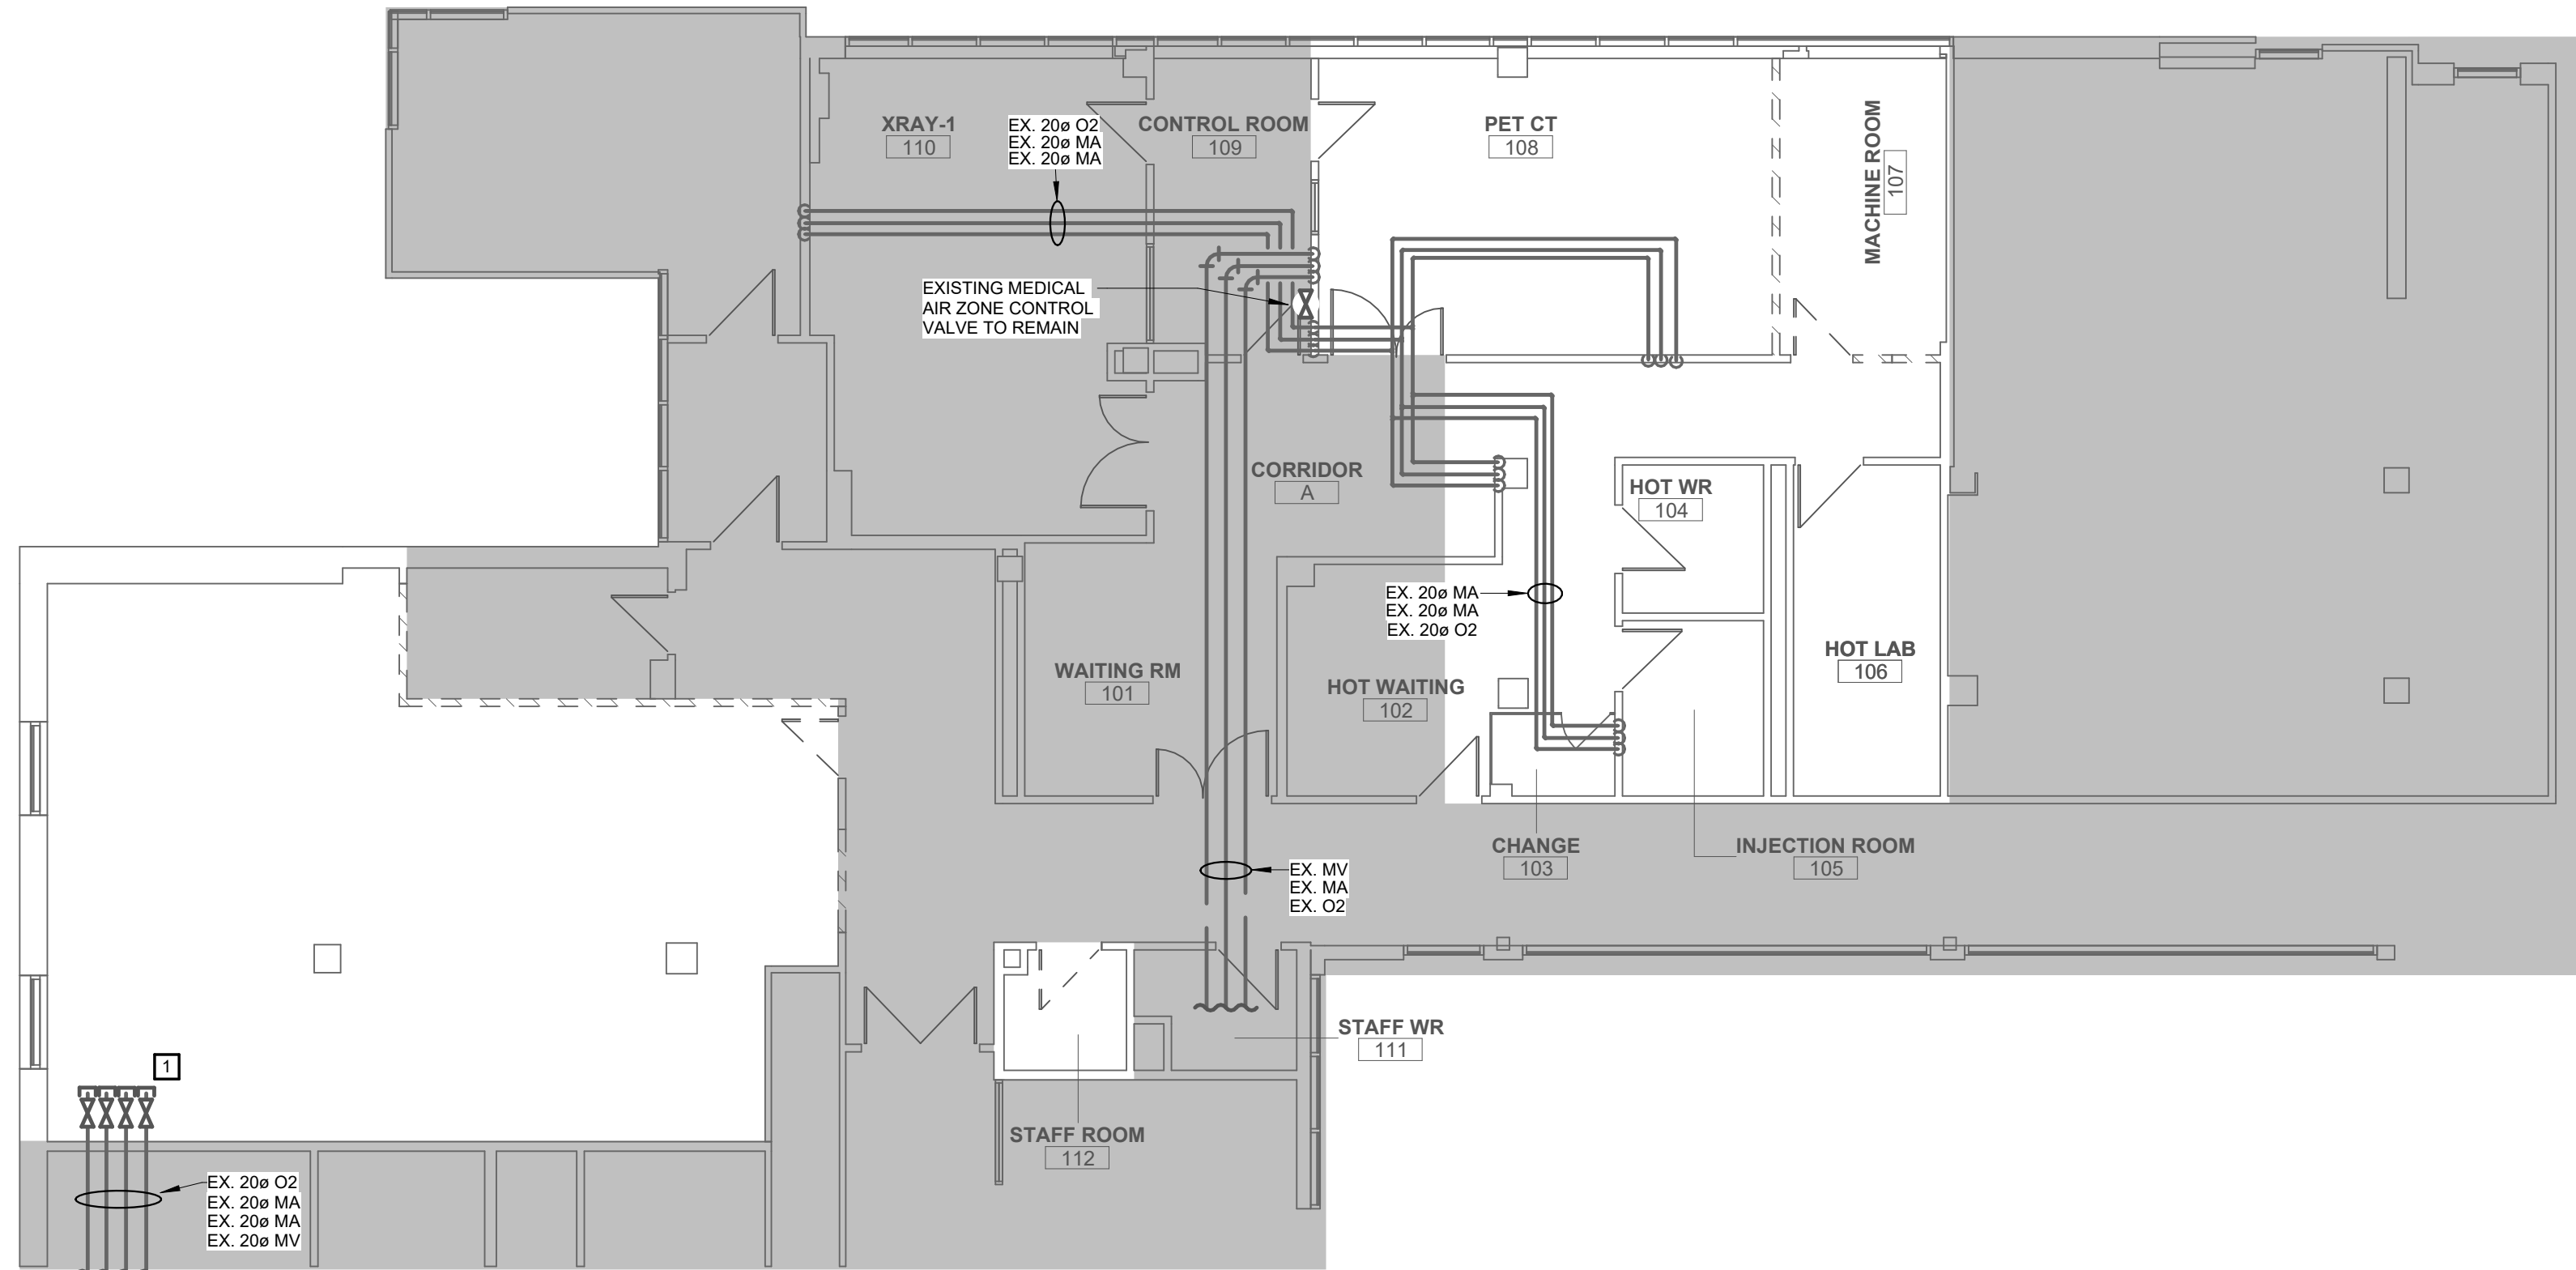

LEVEL 2 MEDICAL GAS DEMO PLAN

1 : 100 M400

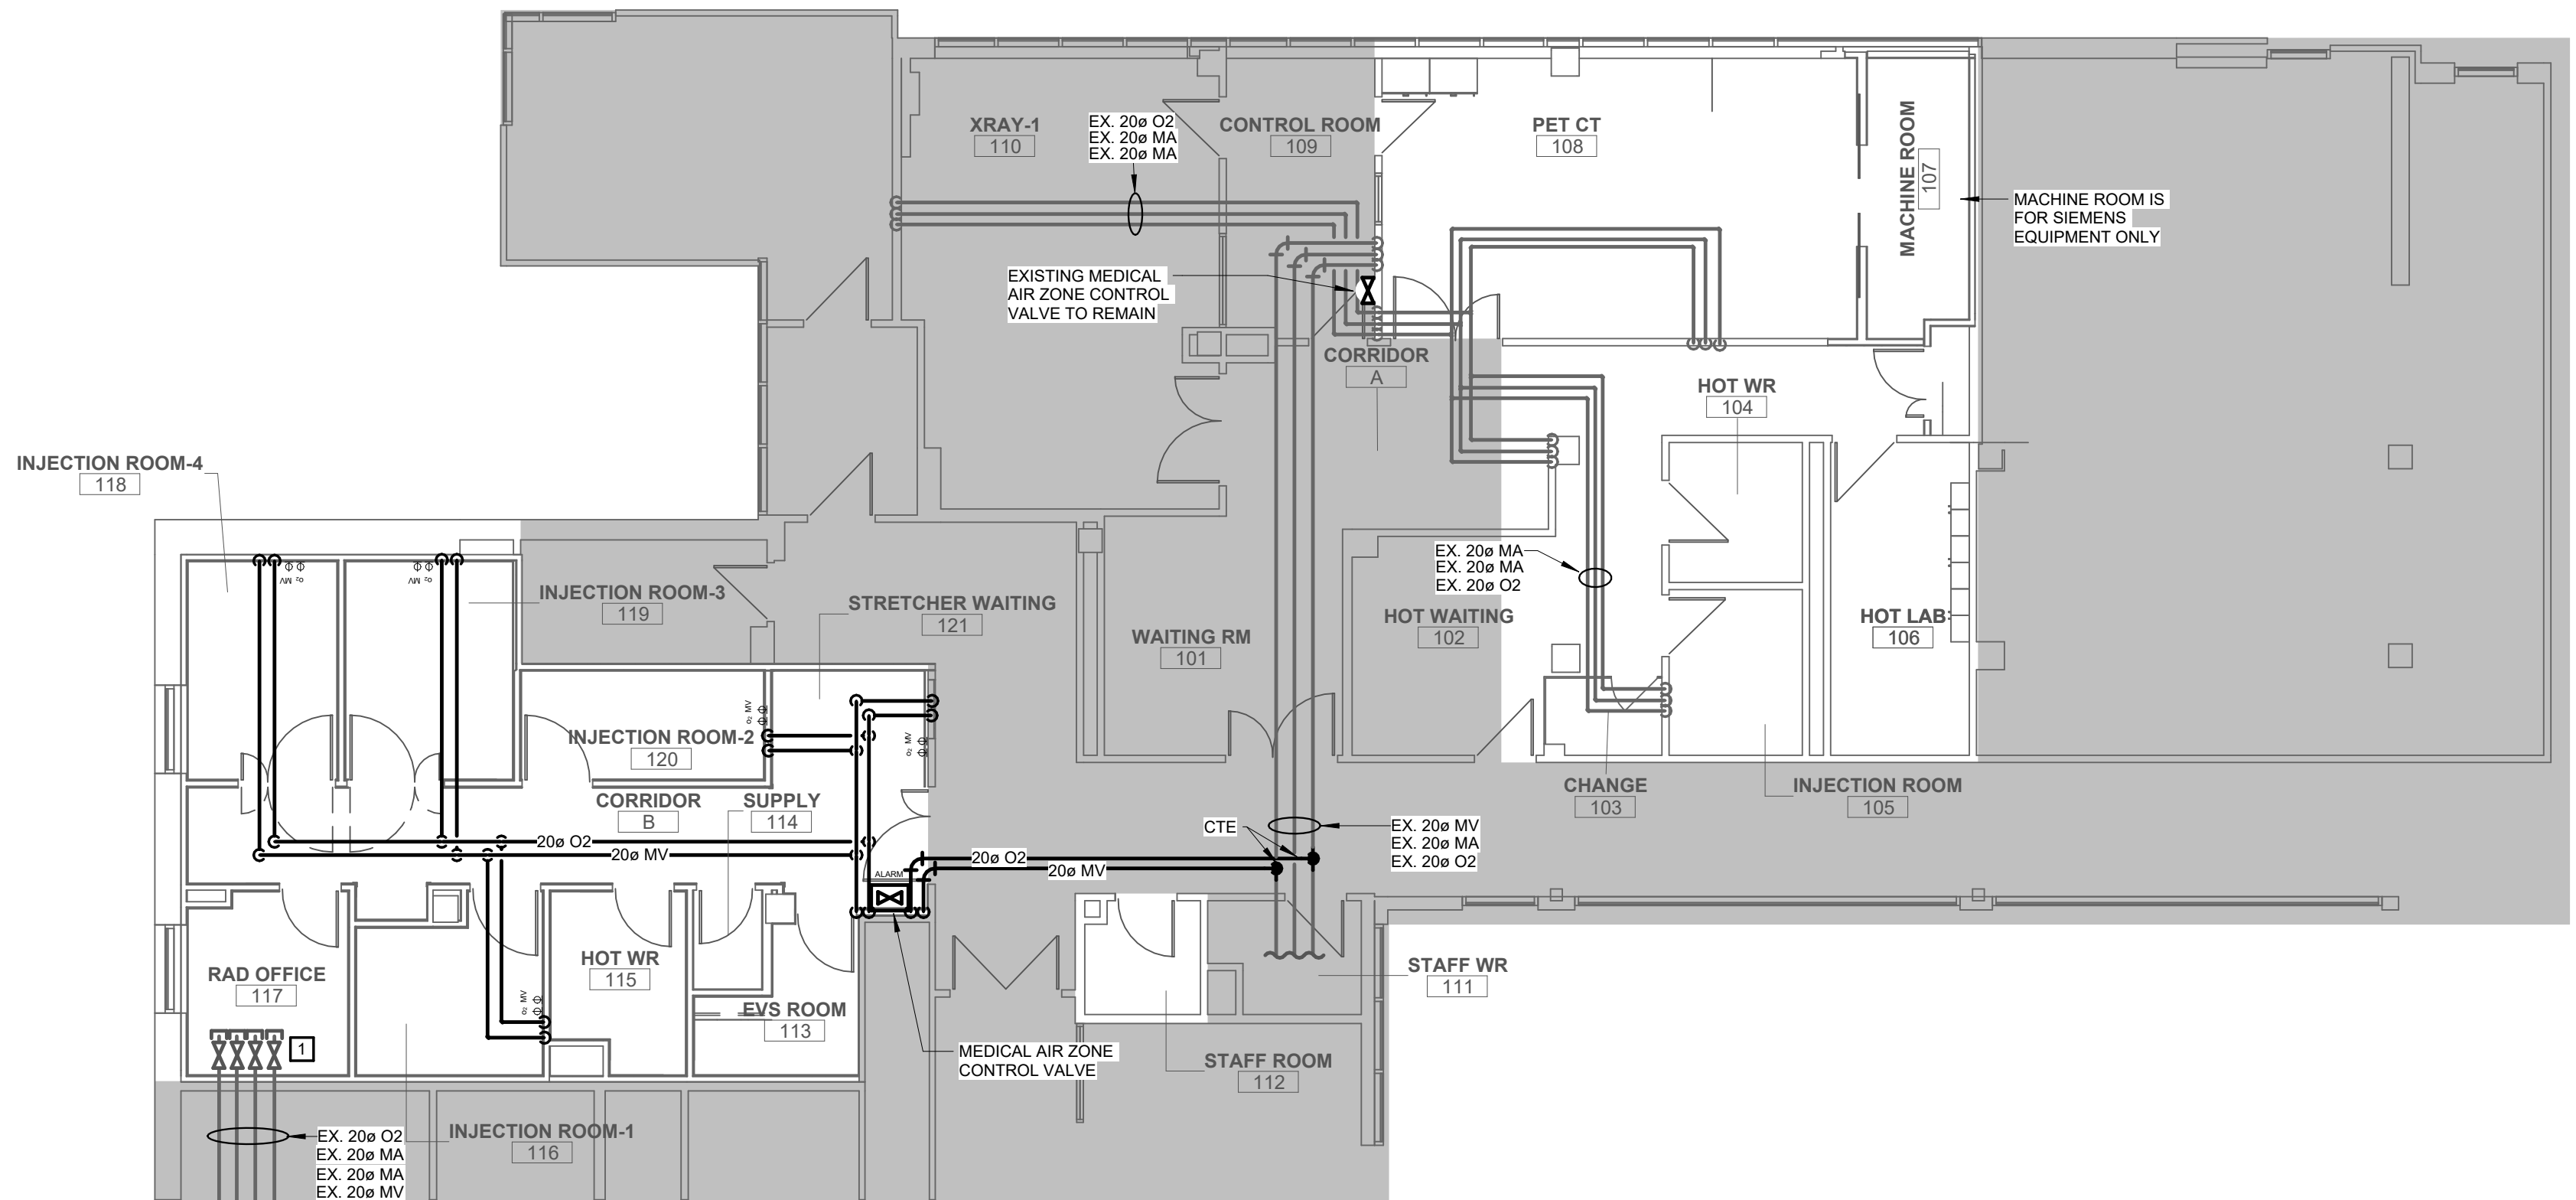

LEVEL 2 MEDICAL GAS PROPOSED PLAN

2 : 100 M400

CONSTRUCTION NOTES



- A. ALPHABETICAL NOTES ARE GENERAL TO THE PLAN(S) ON THIS SHEET
- # NUMERICAL NOTES ARE KEYED NOTES CORRESPONDING TO KEYED NOTES ON PLAN(S) ON THIS SHEET

1. EXISTING PIPING VALVED AND CAPPED TO REMAIN.

TO BE DEMOLISHED



PROJECT LOGO

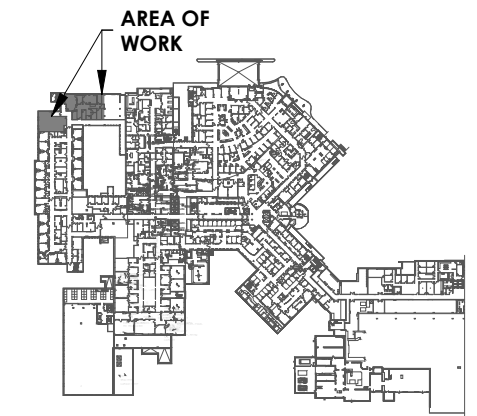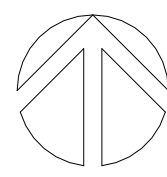

KEY PLAN

ISSUED FOR TENDER
(2026.02.27)

7	ISSUED FOR TENDER	2026.04.10
6	ISSUED FOR TENDER	2025.12.12
5	ISSUED FOR PERMIT	2025.11.26
4	FINAL DESIGN DEVELOPMENT SET	2025.11.07
3	100% DESIGN DEVELOPMENT SET	2025.10.31
2	100% DESIGN DEVELOPMENT PROGRESS SET	2025.09.29
1	50% DESIGN DEVELOPMENT PROGRESS SET	2025.05.09

No.	DESCRIPTION	DATE
-----	-------------	------

REVISIONS:

DISCREPANCIES MUST BE REPORTED IMMEDIATELY TO THE ARCHITECT / ENGINEER BEFORE PROCEEDING.

ONLY FIGURED DIMENSIONS MUST BE USED.

THE CONTRACTOR MUST CHECK THE DIMENSIONS ON SITE.

THE DRAWING IS PROTECTED BY COPYRIGHT.

ALL DIMENSIONS ARE SHOWN IN MILLIMETERS.

DO NOT SCALE THE DRAWINGS.

mcCallumSather
Westinghouse HQ, 2nd Floor
286 Sanford Ave. N
Hamilton, ON L8L 6A1
905.526.6700
www.mccallumsather.com

SEAL

CONSULTANTS:

PROJECT:
WATERLOO REGIONAL HEALTH NETWORK @ MODTPWN - PET CT


835 KING ST W, KITCHENER, ON N2G 1G

DRAWING TITLE:
LEVEL 2 MEDICAL GAS DEMO & PROPOSED PLAN


DRAWN BY:	SB.MC	DATE:	2024/09/01
CHECKED BY:	DR. AB	SCALE:	As indicated

PROJECT NO.: **24048**

DRAWING NO.: **M400**

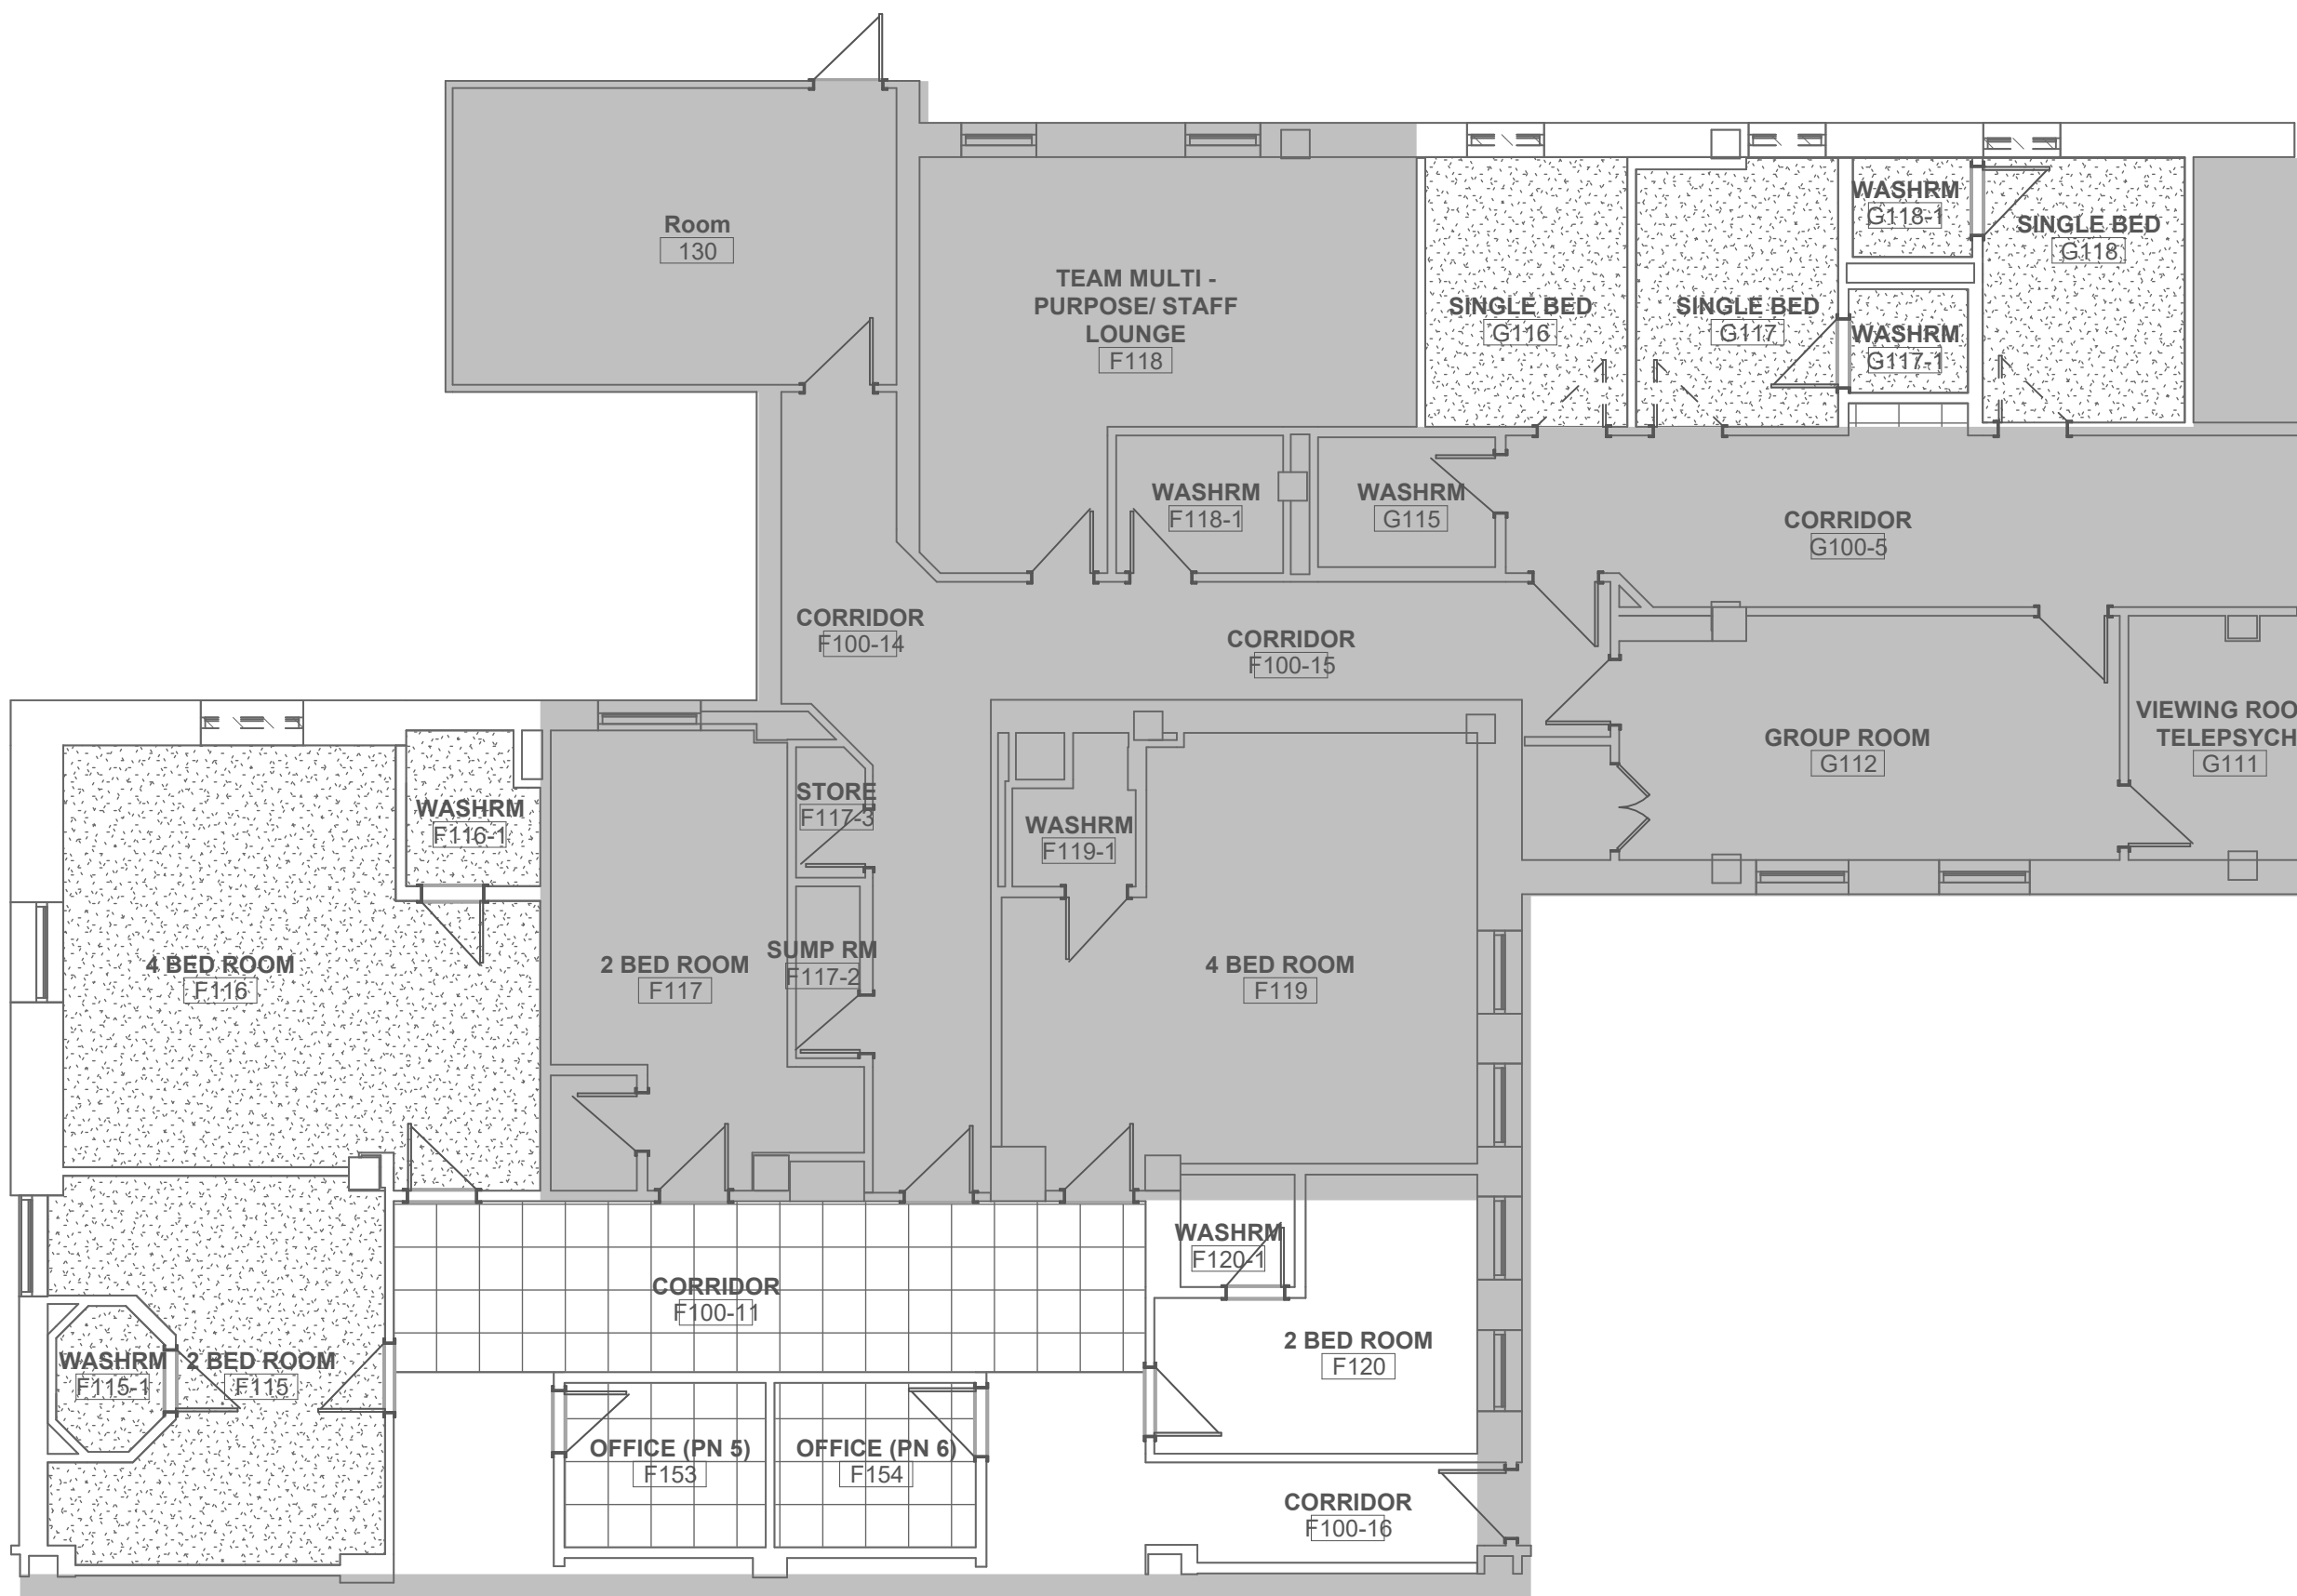

LEVEL 1 HVAC DEMO PLAN

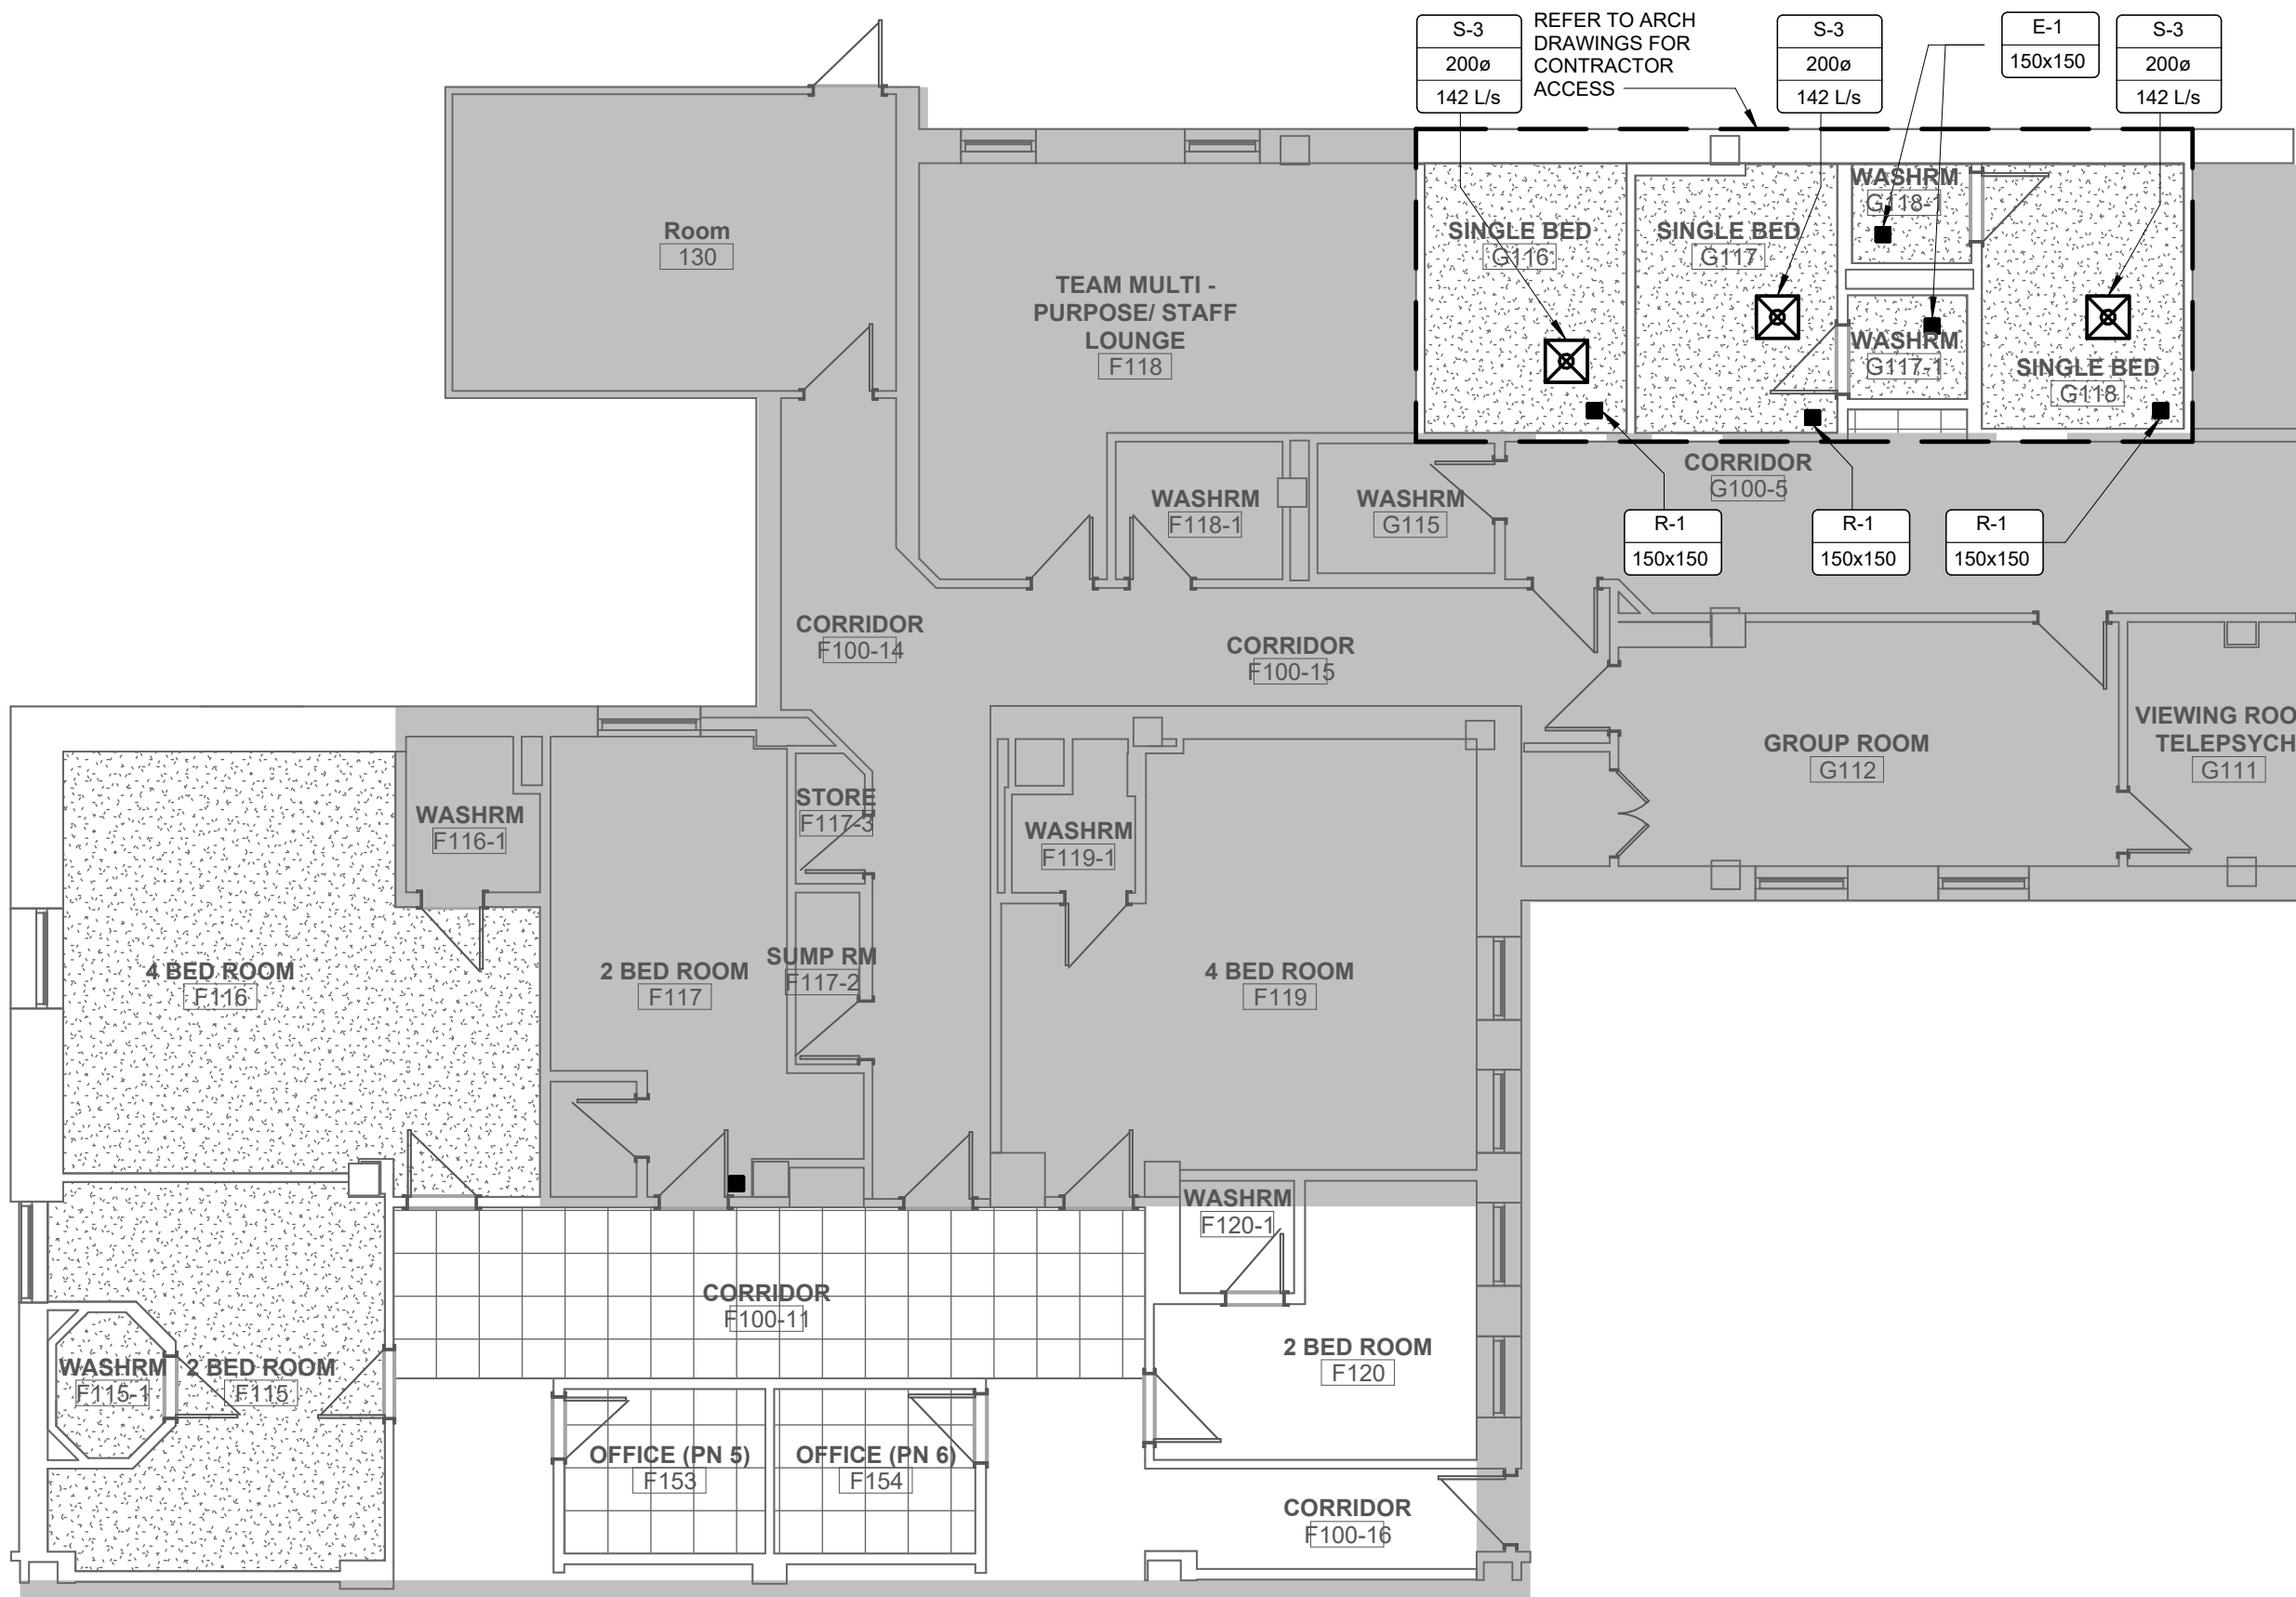

LEVEL 1 HVAC PROPOSED PLAN




CONSTRUCTION NOTES

- A. ALPHABETICAL NOTES ARE GENERAL TO THE PLAN(S) ON THIS SHEET
- N** NUMERICAL NOTES ARE KEYED NOTES CORRESPONDING TO KEYED NOTES ON PLAN(S) ON THIS SHEET
- A. MECHANICAL CONTRACTOR TO COORDINATE WITH GENERAL CONTRACTOR TO REMOVE EXISTING LIGATURE FREE GRILLES AND DIFFUSERS TO ALLOW FOR CEILING REMOVAL FOR ELECTRICAL WORK. ALSO TO REINSTATE THE EXISTING LIGATURE FREE GRILLES AND DIFFUSER WITH TAMPER PROOF FASTENERS.



PROJECT LOGO

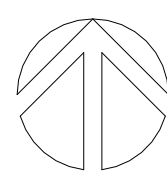

KEY PLAN

ISSUED FOR TENDER
(2026.02.27)

7	ISSUED FOR TENDER	2026.04.10
6	ISSUED FOR TENDER	2025.12.12
5	ISSUED FOR PERMIT	2025.11.26
4	FINAL DESIGN DEVELOPMENT SET	2025.11.07
3	100% DESIGN DEVELOPMENT SET	2025.10.31
2	100% DESIGN DEVELOPMENT PROGRESS SET	2025.09.29
1	50% DESIGN DEVELOPMENT PROGRESS SET	2025.05.09

No.	DESCRIPTION	DATE
-----	-------------	------

REVISIONS:

DISCREPANCIES MUST BE REPORTED IMMEDIATELY TO THE ARCHITECT/ENGINEER BEFORE PROCEEDING.

ONLY FIGURED DIMENSIONS MUST BE USED.

THE CONTRACTOR MUST CHECK THE DIMENSIONS ON SITE.

THE DRAWING IS PROTECTED BY COPYRIGHT.

ALL DIMENSIONS ARE SHOWN IN MILLIMETERS.

DO NOT SCALE THE DRAWINGS.

mcCallumSather
Westinghouse HQ, 2nd Floor
286 Sanford Ave. N
Hamilton, ON L8L 6A1
905.526.6700
www.mccallumsather.com

SEAL

CONSULTANTS:

PROJECT:
WATERLOO REGIONAL HEALTH NETWORK @ MODTPWN - PET CT


835 KING ST W, KITCHENER, ON N2G 1G

DRAWING TITLE:
LEVEL 1 HVAC DEMO & PROPOSED PLAN

DRAWN BY:	SB.MC	DATE:	2024/09/01
CHECKED BY:	DR. AB	SCALE:	As indicated

PROJECT NO.: **24048**

DRAWING NO.: **M500**

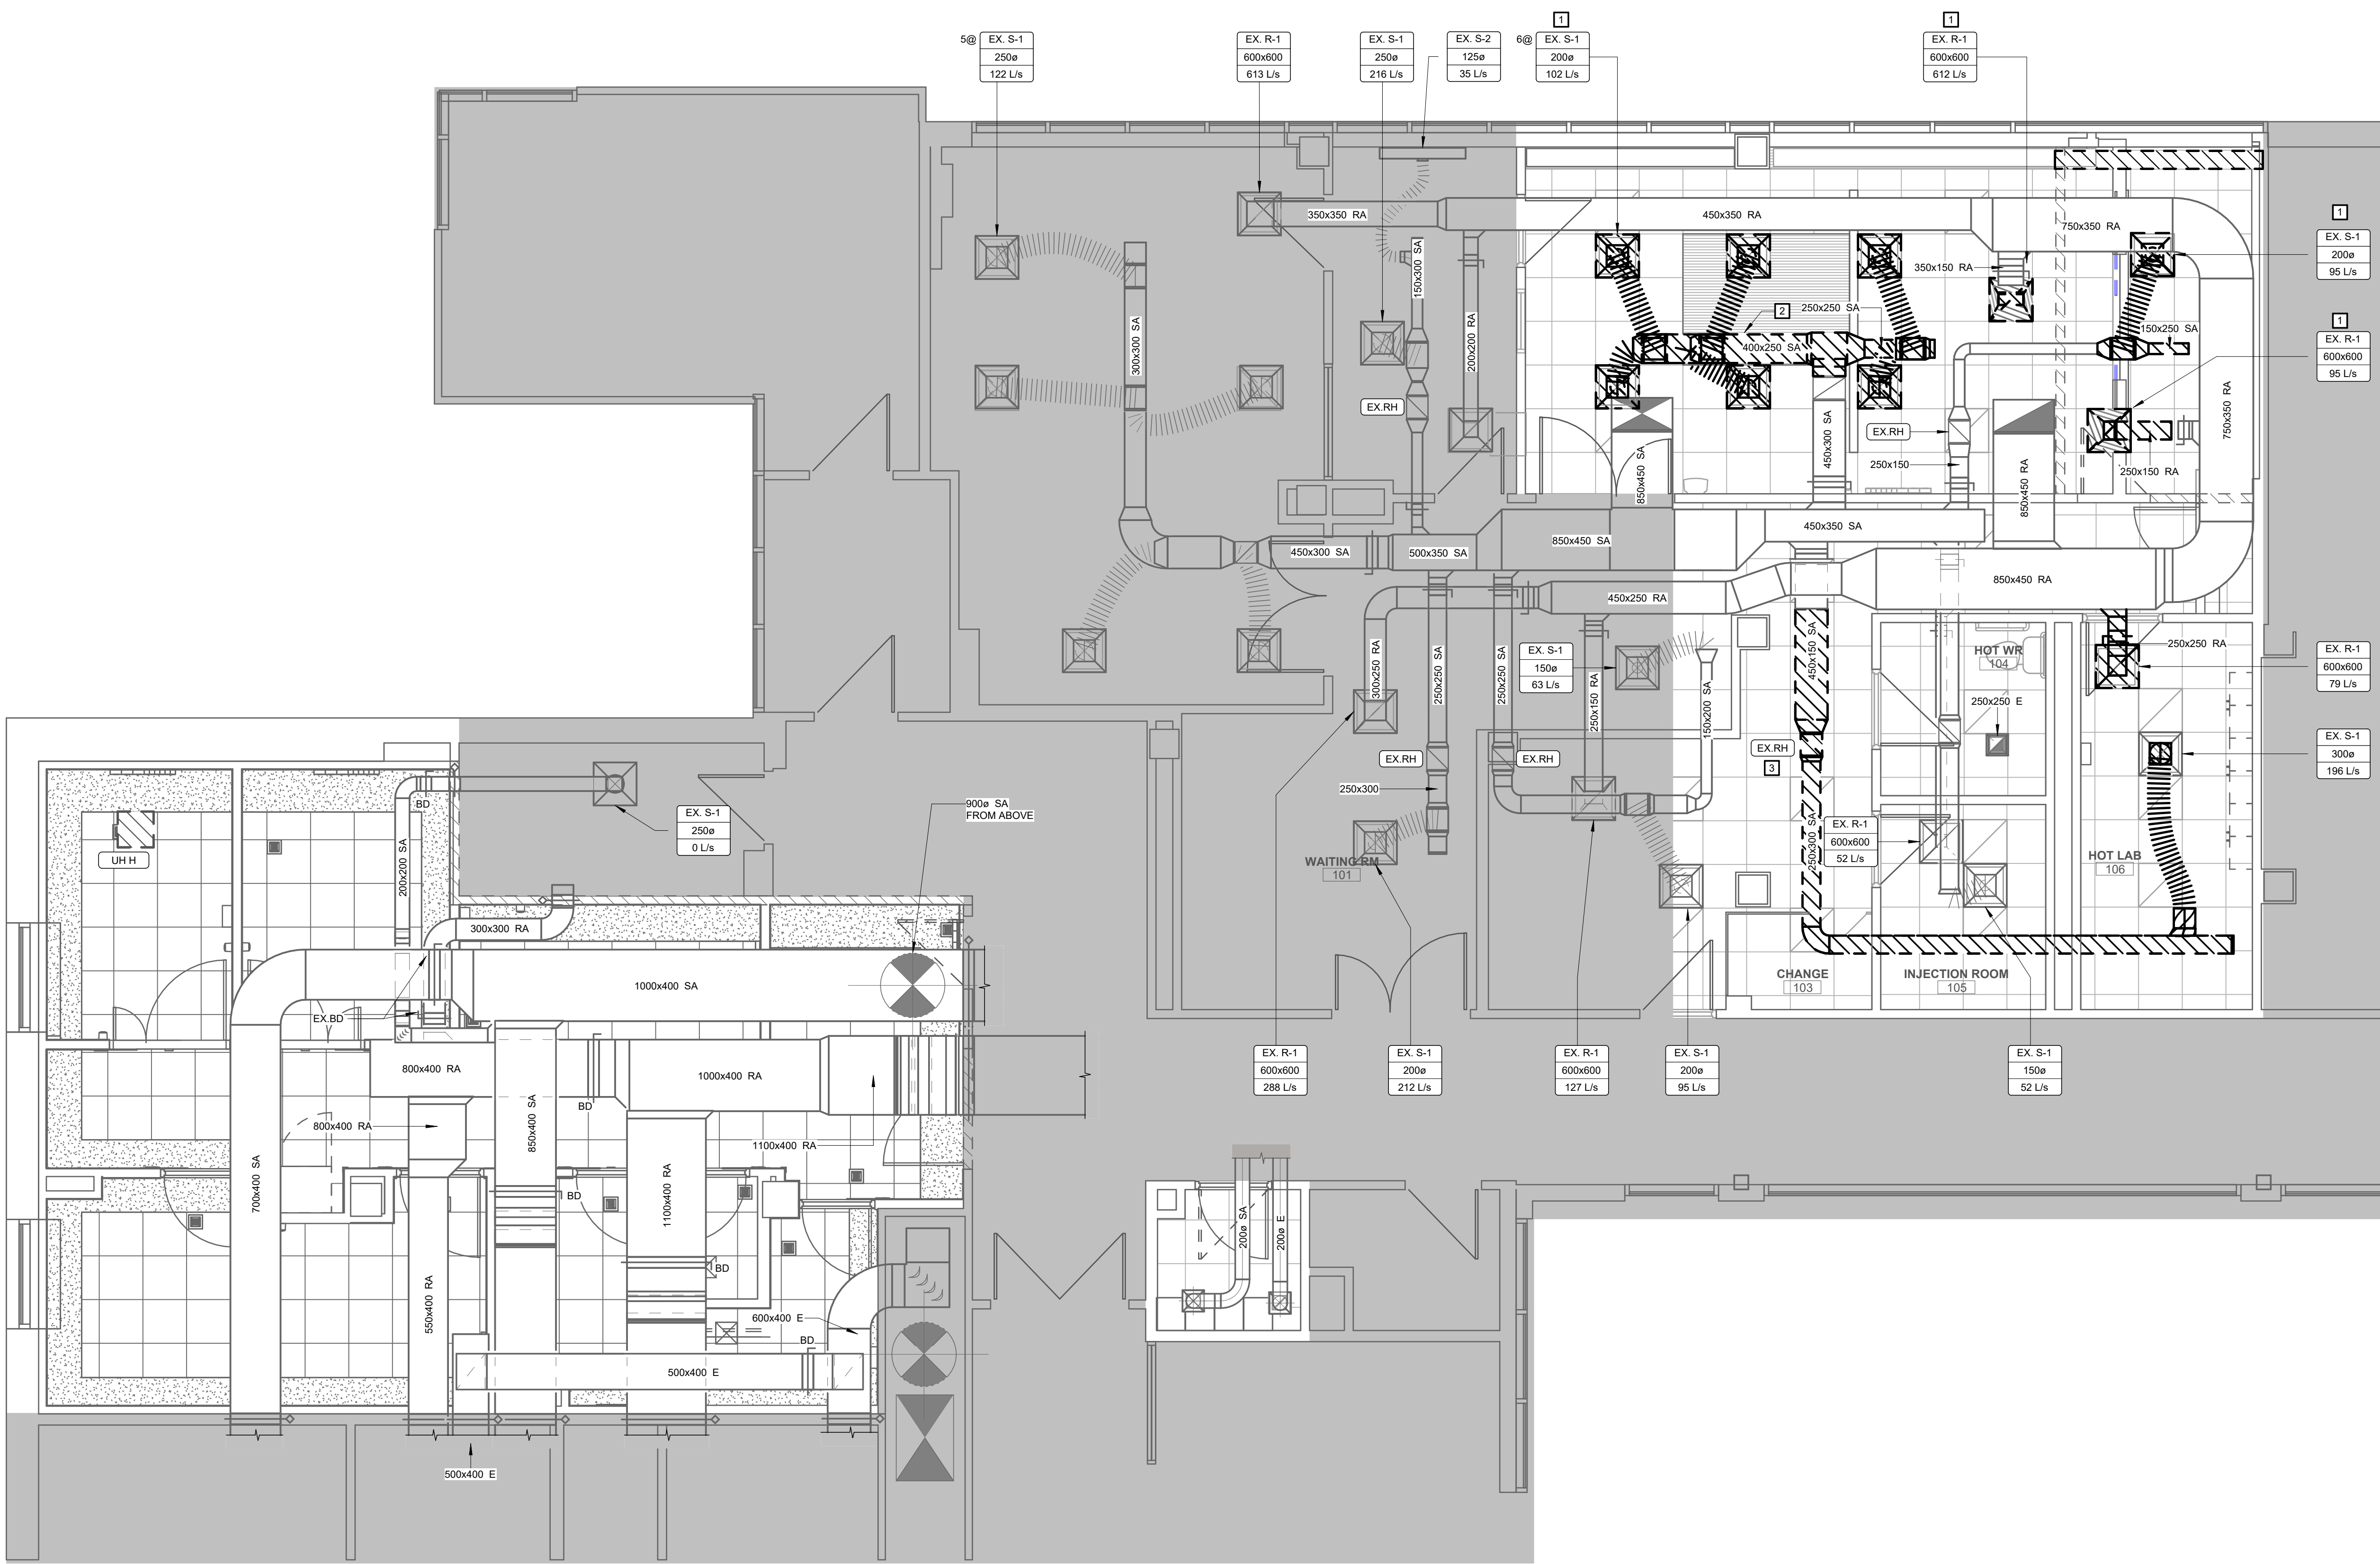

LEVEL 2 HVAC DEMO PLAN 1
1:50 M501



CONSTRUCTION NOTES

- A. ALPHABETICAL NOTES ARE GENERAL TO THE PLAN(S) ON THIS SHEET
- # NUMERICAL NOTES ARE KEYED NOTES CORRESPONDING TO KEYED NOTES ON PLAN(S) ON THIS SHEET
- A. INSTALL DUCTING OFF WALL TO ENSURE ACCESS TO DUCT ACCESS DOORS TO RESET EXISTING FIRE DAMPERS.
- B. THE CONTRACTOR SHALL REPAIR OR REPLACE, AT NO ADDITIONAL COST TO WRHN, ANY DAMAGE CAUSED TO EXISTING WALLS, WALL PROTECTION SYSTEMS, FINISHES, FURNITURE, EQUIPMENT, DEVICES, OR ADJACENT BUILDING ELEMENTS RESULTING FROM THE PERFORMANCE OF THE WORK.
- C. REMOVE EXISTING DIFFUSERS AND GRILLES TO ALLOW EXISTING CEILING PLAN TO BE REMOVED. REFER TO PROPOSED PLAN. ALL UNUSED DIFFUSERS TO BE TURNED OVER TO THE HOSPITAL.
- D. REMOVE EXISTING MAIN DUCT AS SHOWN.
- E. REMOVE EXISTING DUCT HEAT AND CAP HWS AND HWR PIPING AT MAINS.

TO BE DEMOLISHED



PROJECT LOGO

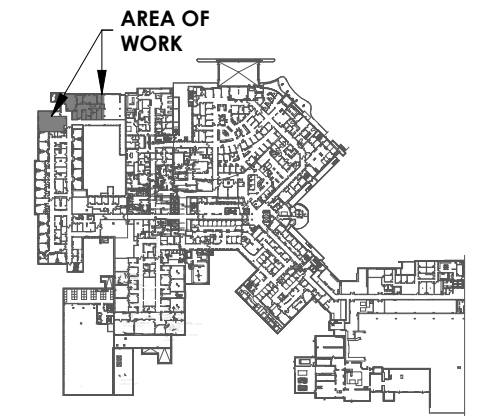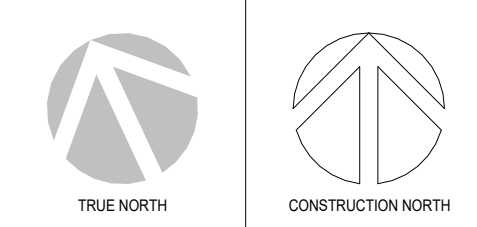

KEY PLAN

ISSUED FOR TENDER
(2026.02.27)

7	ISSUED FOR TENDER	2026.04.10
6	ISSUED FOR TENDER	2025.12.12
5	ISSUED FOR PERMIT	2025.11.26
4	FINAL DESIGN DEVELOPMENT SET	2025.11.07
3	100% DESIGN DEVELOPMENT SET	2025.10.31
2	100% DESIGN DEVELOPMENT PROGRESS SET	2025.09.29
1	50% DESIGN DEVELOPMENT PROGRESS SET	2025.05.09

No.	DESCRIPTION	DATE
REVISIONS:		
DISCREPANCIES MUST BE REPORTED IMMEDIATELY TO THE ARCHITECT/ENGINEER BEFORE PROCEEDING. ONLY FIGURED DIMENSIONS MUST BE USED. THE CONTRACTOR MUST CHECK THE DIMENSIONS ON SITE. THE DRAWING IS PROTECTED BY COPYRIGHT. ALL DIMENSIONS ARE SHOWN IN MILLIMETERS. DO NOT SCALE THE DRAWINGS.		

mcCallumSather
Westinghouse HQ, 2nd Floor
286 Sanford Ave. N
Hamilton, ON L8L 6A1
905.526.6700
www.mccallumsather.com

SEAL

CONSULTANTS:

PROJECT:
WATERLOO REGIONAL HEALTH NETWORK @ MODTPWN - PET CT


835 KING ST W, KITCHENER, ON N2G 1G

DRAWING TITLE:
LEVEL 2 HVAC DEMOLITION PLAN

DRAWN BY:	SB.MC	DATE:	2024/09/01
CHECKED BY:	DR. AB	SCALE:	1:50

PROJECT NO.: **24048**

DRAWING NO.: **M501**

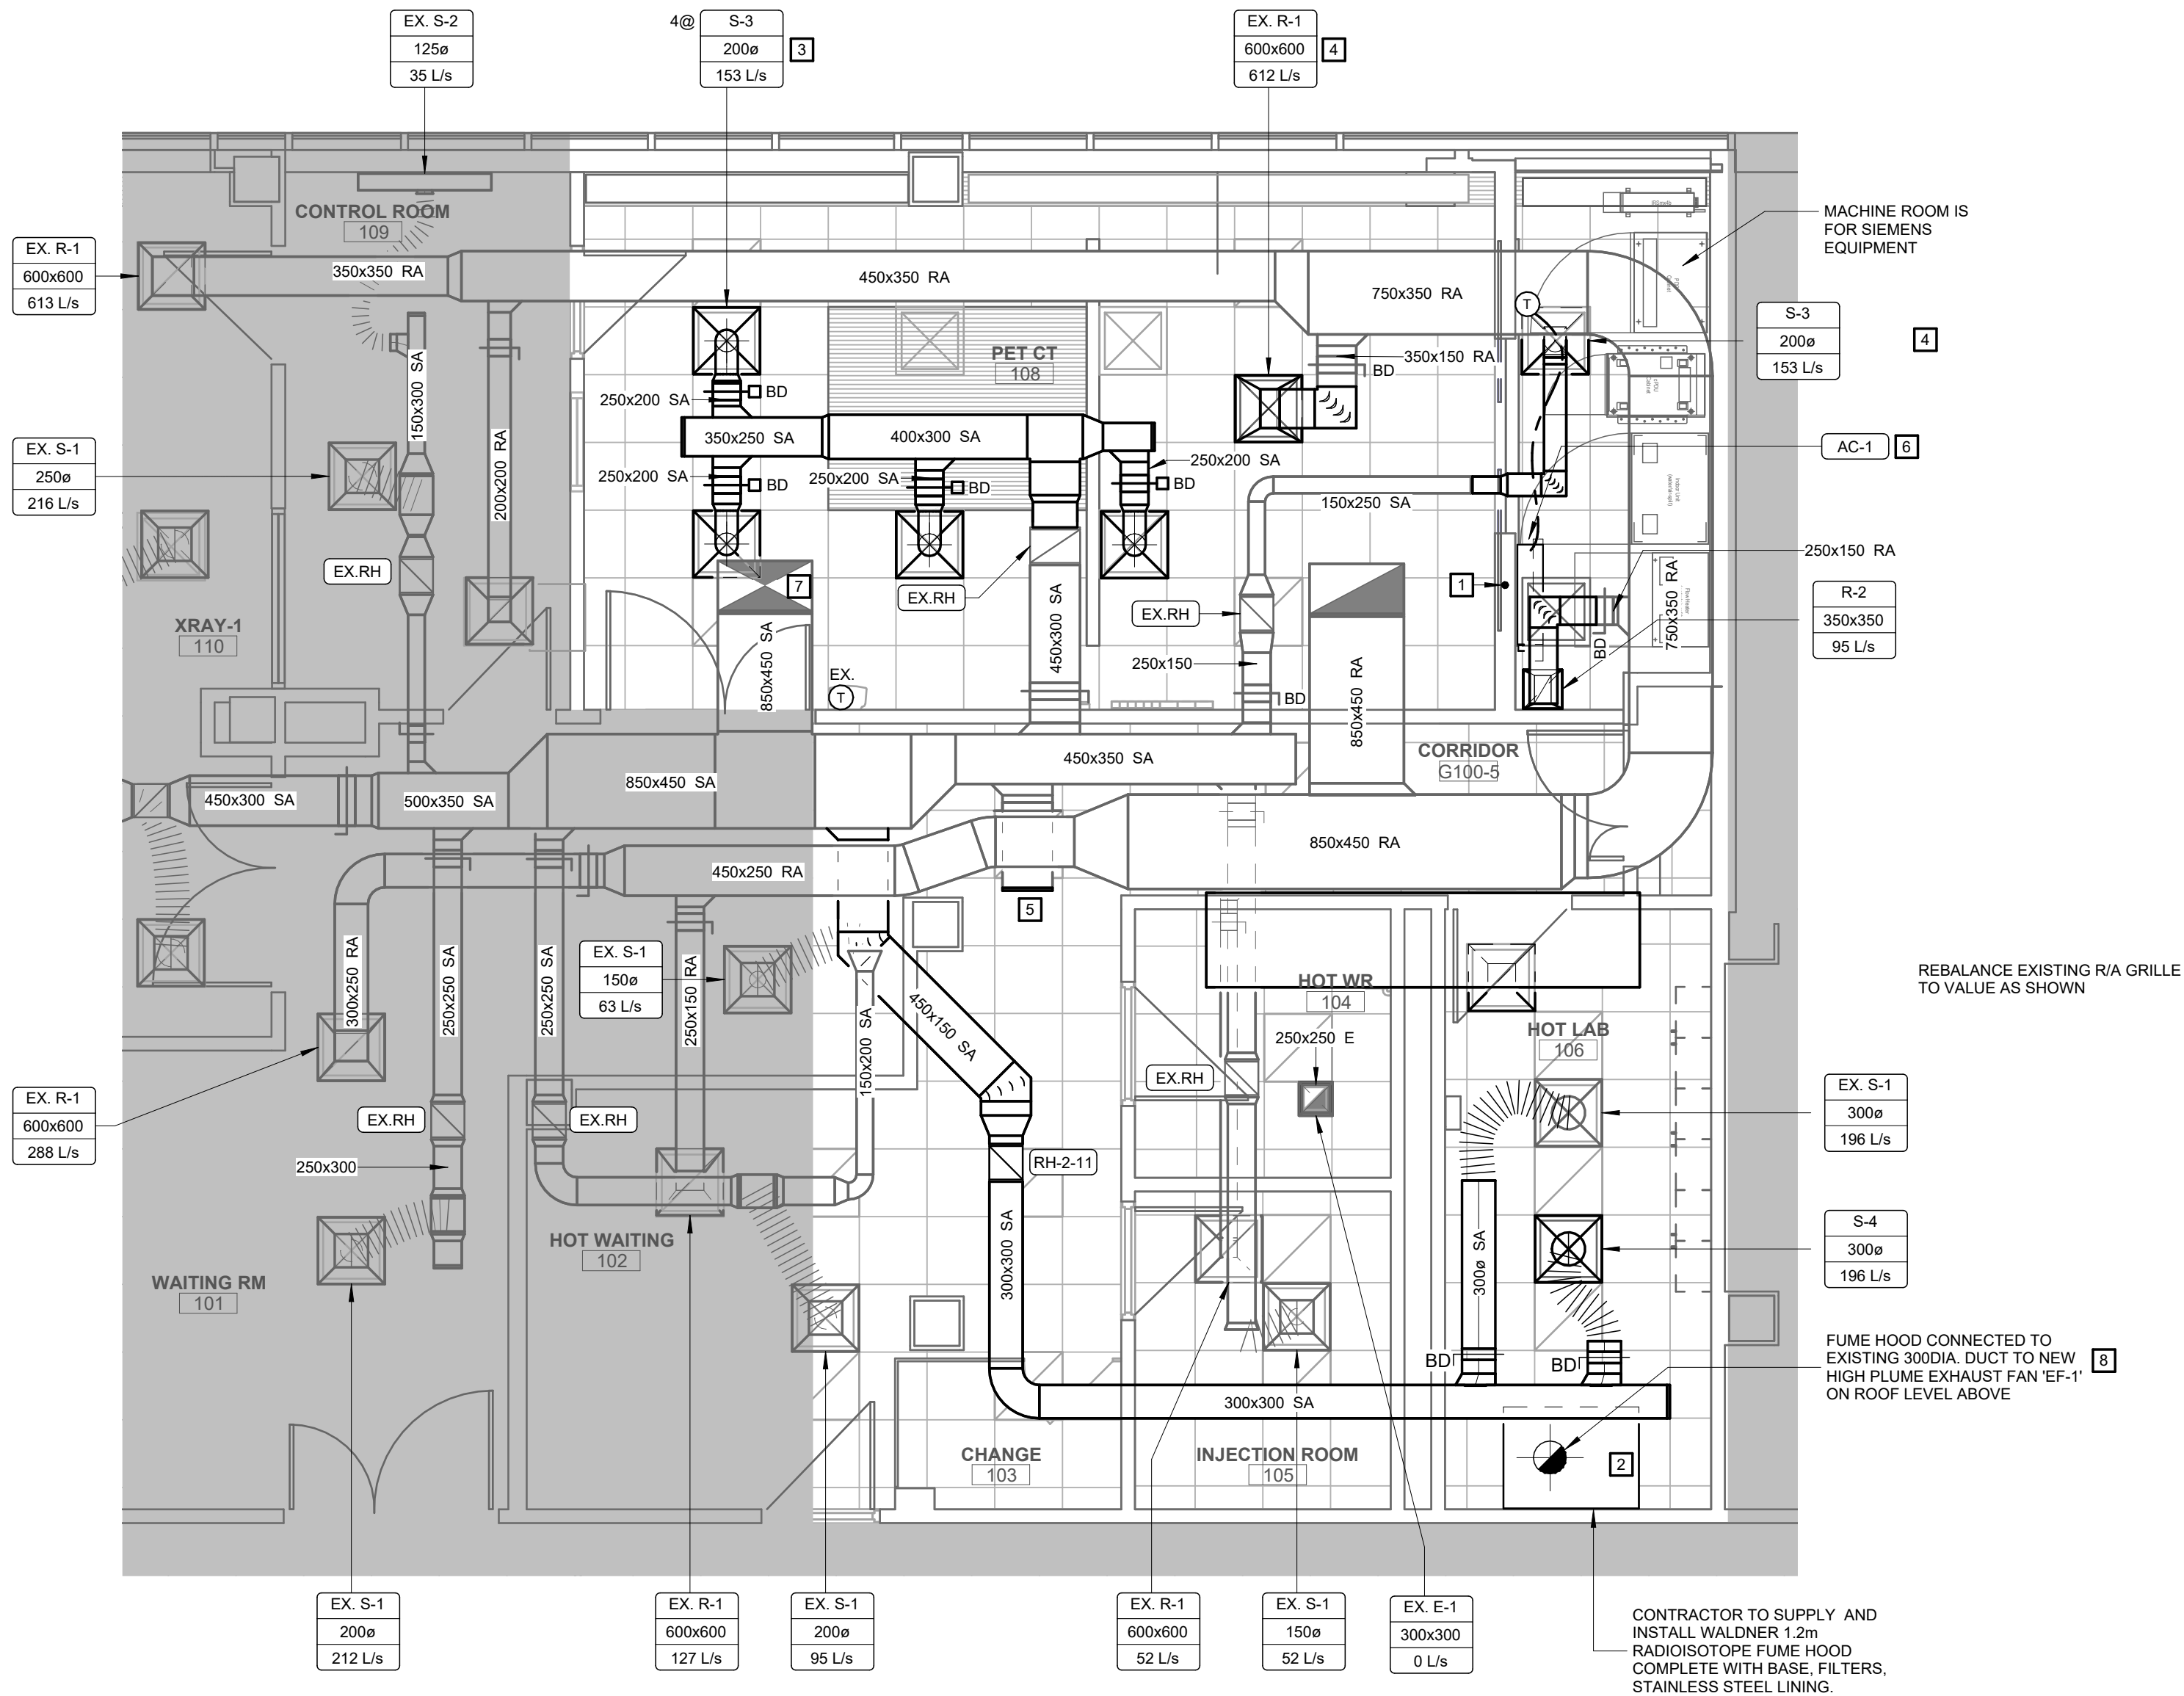



LEVEL 2 HVAC PROPOSED PLAN - CT SCANNER AREA
1
1 : 50 M502

CONSTRUCTION NOTES

- A. ALPHABETICAL NOTES ARE GENERAL TO THE PLAN(S) ON THIS SHEET
- # NUMERICAL NOTES ARE KEYED NOTES CORRESPONDING TO KEYED NOTES ON PLAN(S) ON THIS SHEET
- A. MECHANICAL CONTRACTOR TO COORDINATE NEW CEILING LAYOUT AND OVERHEAT PATIENT LIFT SYSTEM TRACKS.
- B. THE CONTRACTOR SHALL REPAIR OR REPLACE, AT NO ADDITIONAL COST TO WRHN, ANY DAMAGE CAUSED TO EXISTING WALLS, WALL PROTECTION SYSTEMS, FINISHES, FURNITURE, EQUIPMENT, DEVICES, OR ADJACENT BUILDING ELEMENTS RESULTING FROM THE PERFORMANCE OF THE WORK.
- MECHANICAL CONTRACTOR TO CORE FOR 3/4" CONDENSATE. CONDENSATE TO TERMINATE AT WASHROOMS G117-1 AND G118-1 WET WALL.
 - POSITION FUME HOOD ON THE CENTER OF THE WALL TO MAIN ACCESS TO BACK FLOW PREVENTER ISOLATION VALVE ACCESS.
 - NEW RADIAL DIFFUSER IN NEW GRID. USE INSULATED RIGID DUCTING.
 - RELOCATE EXISTING DIFFUSER/GRILLE TO NEW CEILING LAYOUT.
 - CAP AND SEAL EXISTING DUCT TAKE OFF.
 - COORDINATE THE INSTALLATION OF THE INDOOR UNIT TO BE KEPT AWAY FROM ELECTRICAL DEVICES OR ANY EQUIPMENT RELATED TO THE CT SCANNER
 - REBALANCE EXISTING ROOF MOUNTED AIR HANDLER TO PROVIDE AN ADDITIONAL 284 L/s
 - EXHHAUST DUCT TO BE CONSTRUCTED FROM STAINLESS STEEL. ALL JOINTS TO BE WELDED. DUCT TO BE LABELED EVERY 3 METERS WITH A RADIATION WARNING SYMBOL.



PROJECT LOGO

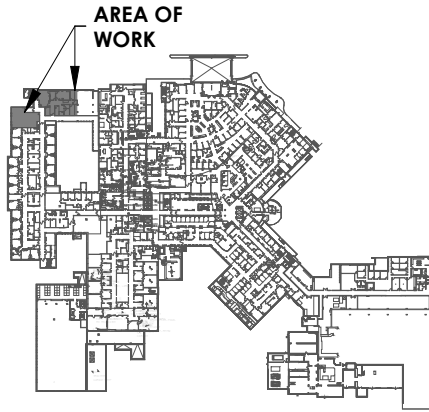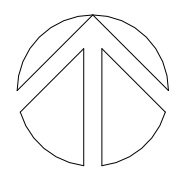

KEY PLAN

ISSUED FOR TENDER
(2026.02.27)

7	ISSUED FOR TENDER	2026.04.10
6	ISSUED FOR TENDER	2025.12.12
5	ISSUED FOR PERMIT	2025.11.26
4	FINAL DESIGN DEVELOPMENT SET	2025.11.07
3	100% DESIGN DEVELOPMENT SET	2025.10.31
2	100% DESIGN DEVELOPMENT PROGRESS SET	2025.09.29
1	50% DESIGN DEVELOPMENT PROGRESS SET	2025.05.09

No.	DESCRIPTION	DATE
REVISIONS:		
DISCREPANCIES MUST BE REPORTED IMMEDIATELY TO THE ARCHITECT/ENGINEER BEFORE PROCEEDING.		
ONLY FIGURED DIMENSIONS MUST BE USED.		
THE CONTRACTOR MUST CHECK THE DIMENSIONS ON SITE.		
THE DRAWING IS PROTECTED BY COPYRIGHT.		
ALL DIMENSIONS ARE SHOWN IN MILLIMETERS.		
DO NOT SCALE THE DRAWINGS.		

mcCallumSather
Westinghouse HQ, 2nd Floor
286 Sanford Ave., N
Hamilton, ON L8L 6A1
905.526.6700
www.mccallumsather.com

SEAL

CONSULTANTS:

PROJECT:
WATERLOO REGIONAL HEALTH NETWORK @ MODTPWN - PET CT


835 KING ST W, KITCHENER, ON N2G 1G

DRAWING TITLE:
LEVEL 2 HVAC PROPOSED PLAN - CT SCANNER AREA

DRAWN BY:	SB.MC	DATE:	2024/09/01
CHECKED BY:	DR. AB	SCALE:	1:50


PROJECT NO: **24048**

DRAWING NO: **M502**

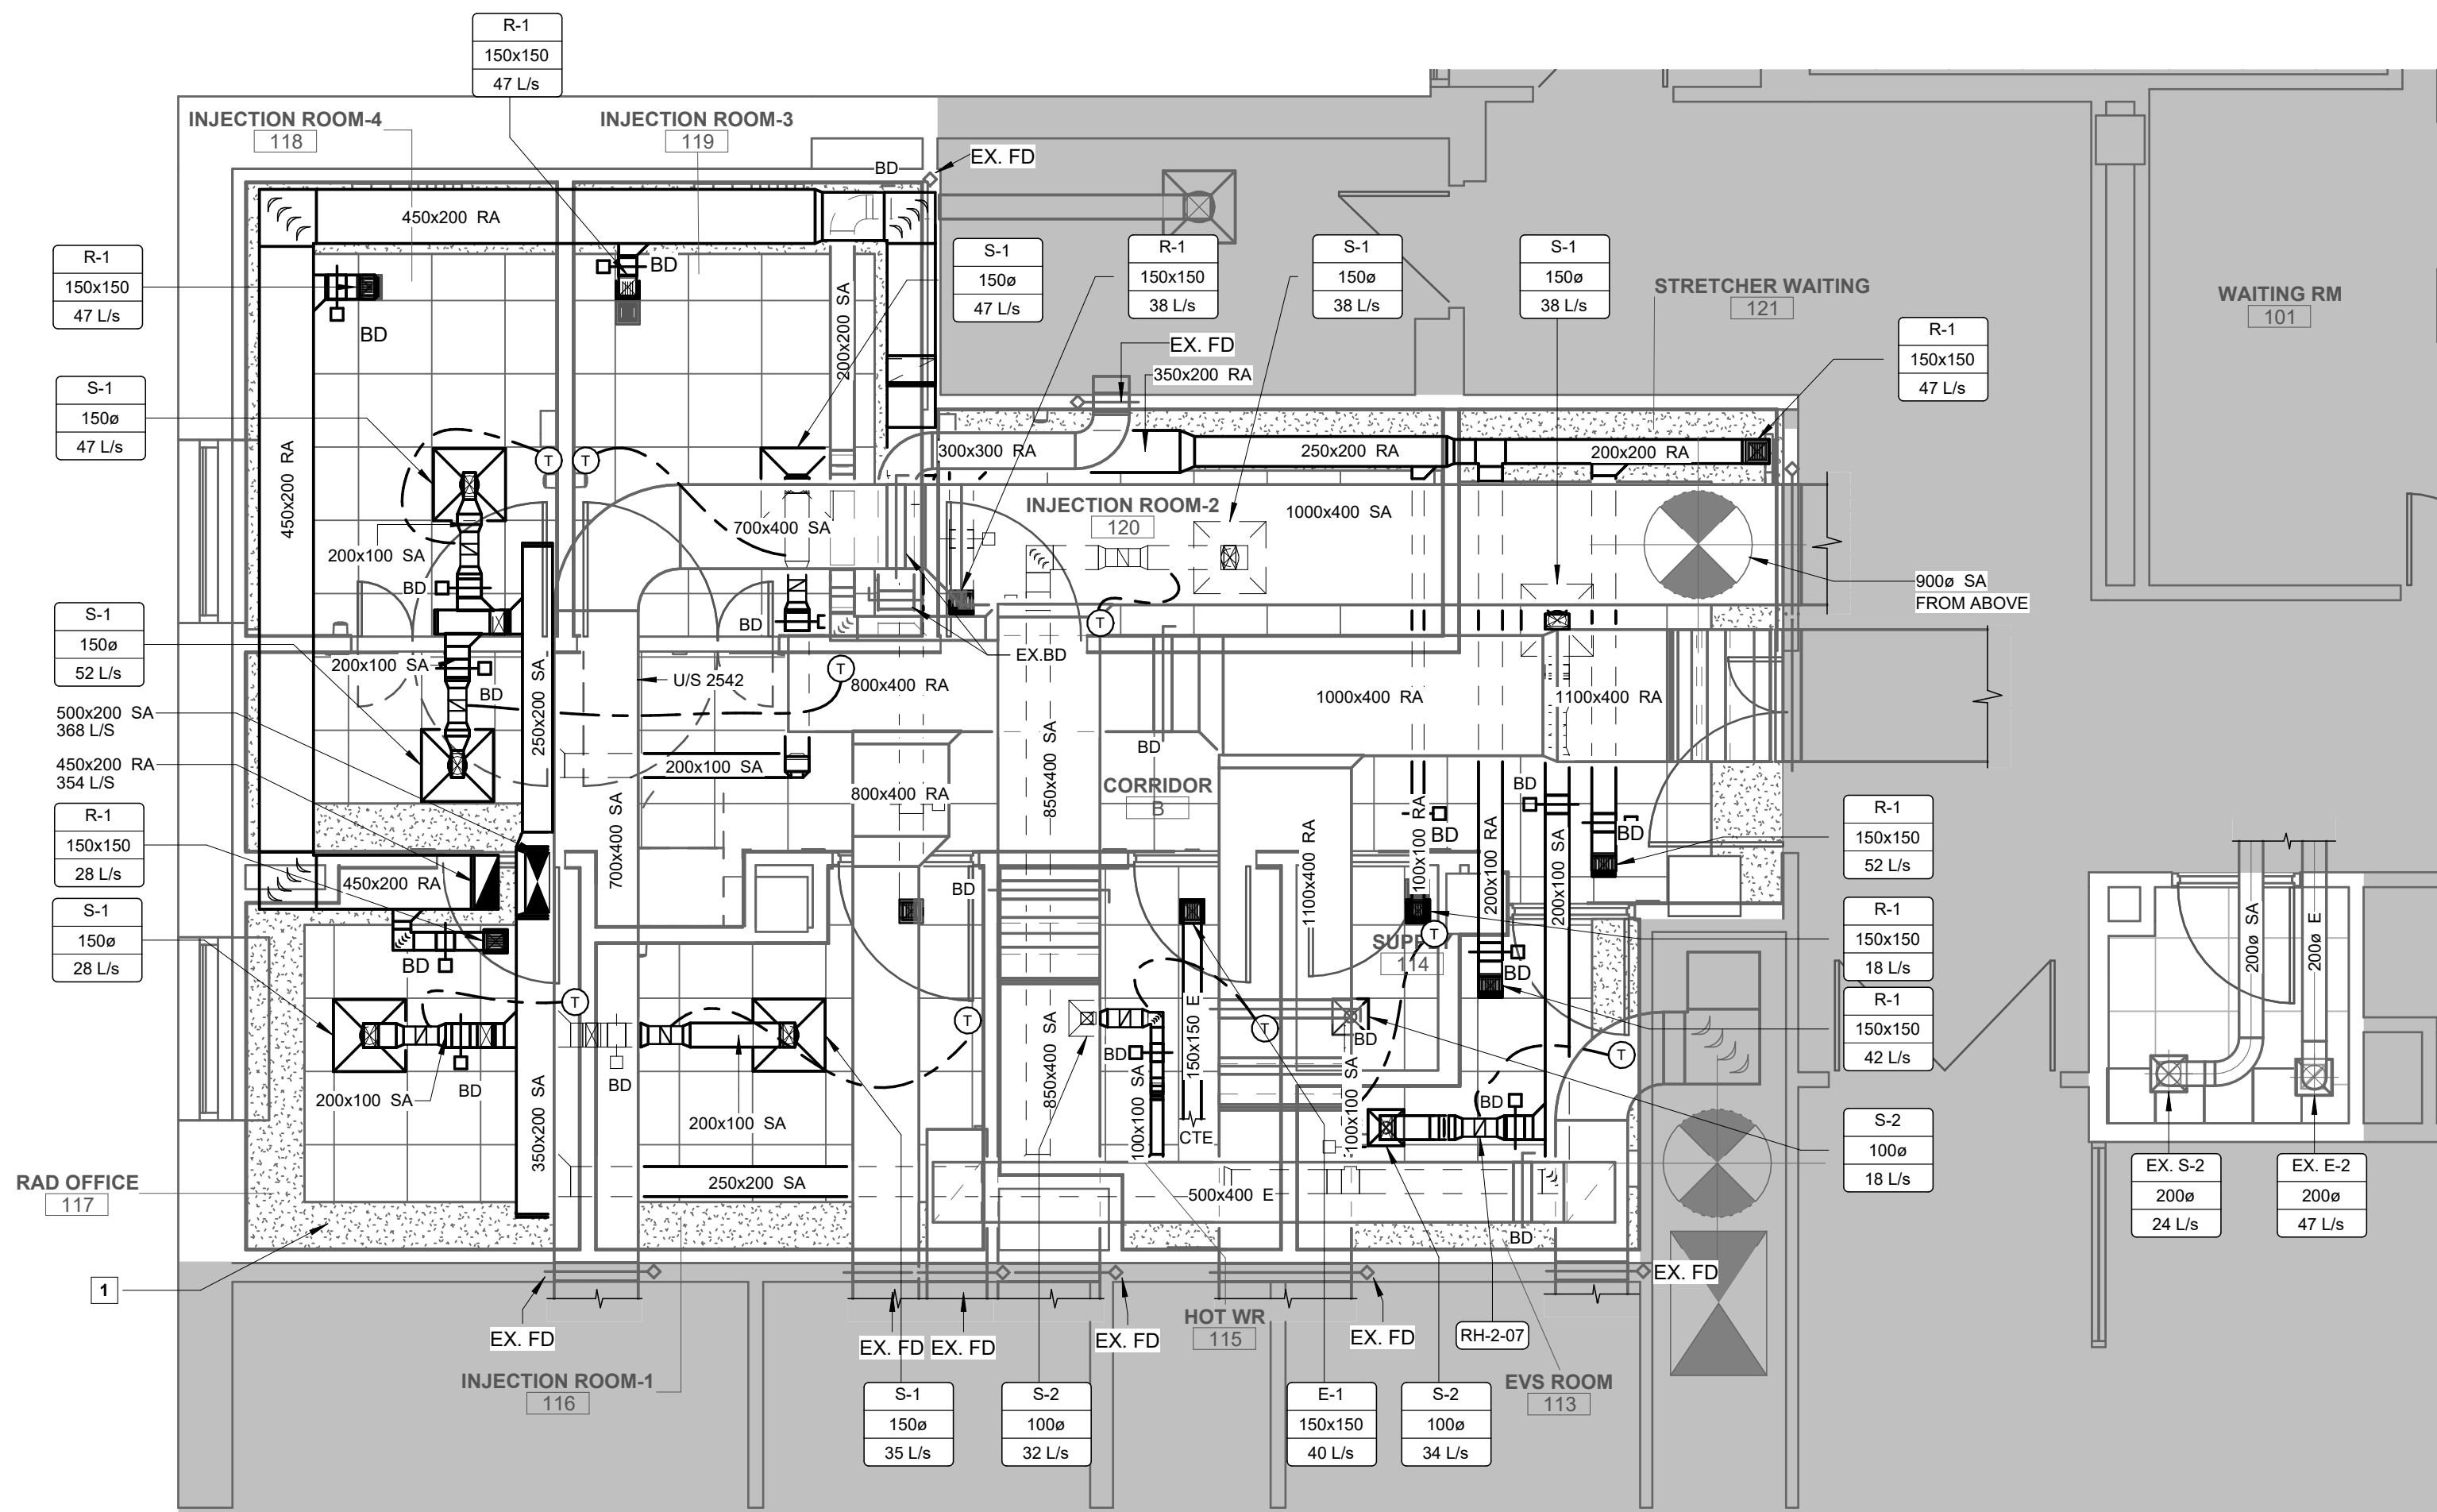

LEVEL 2 HVAC PROPOSED PLAN - INJECTION ROOM AREA

1
1 : 50 M503

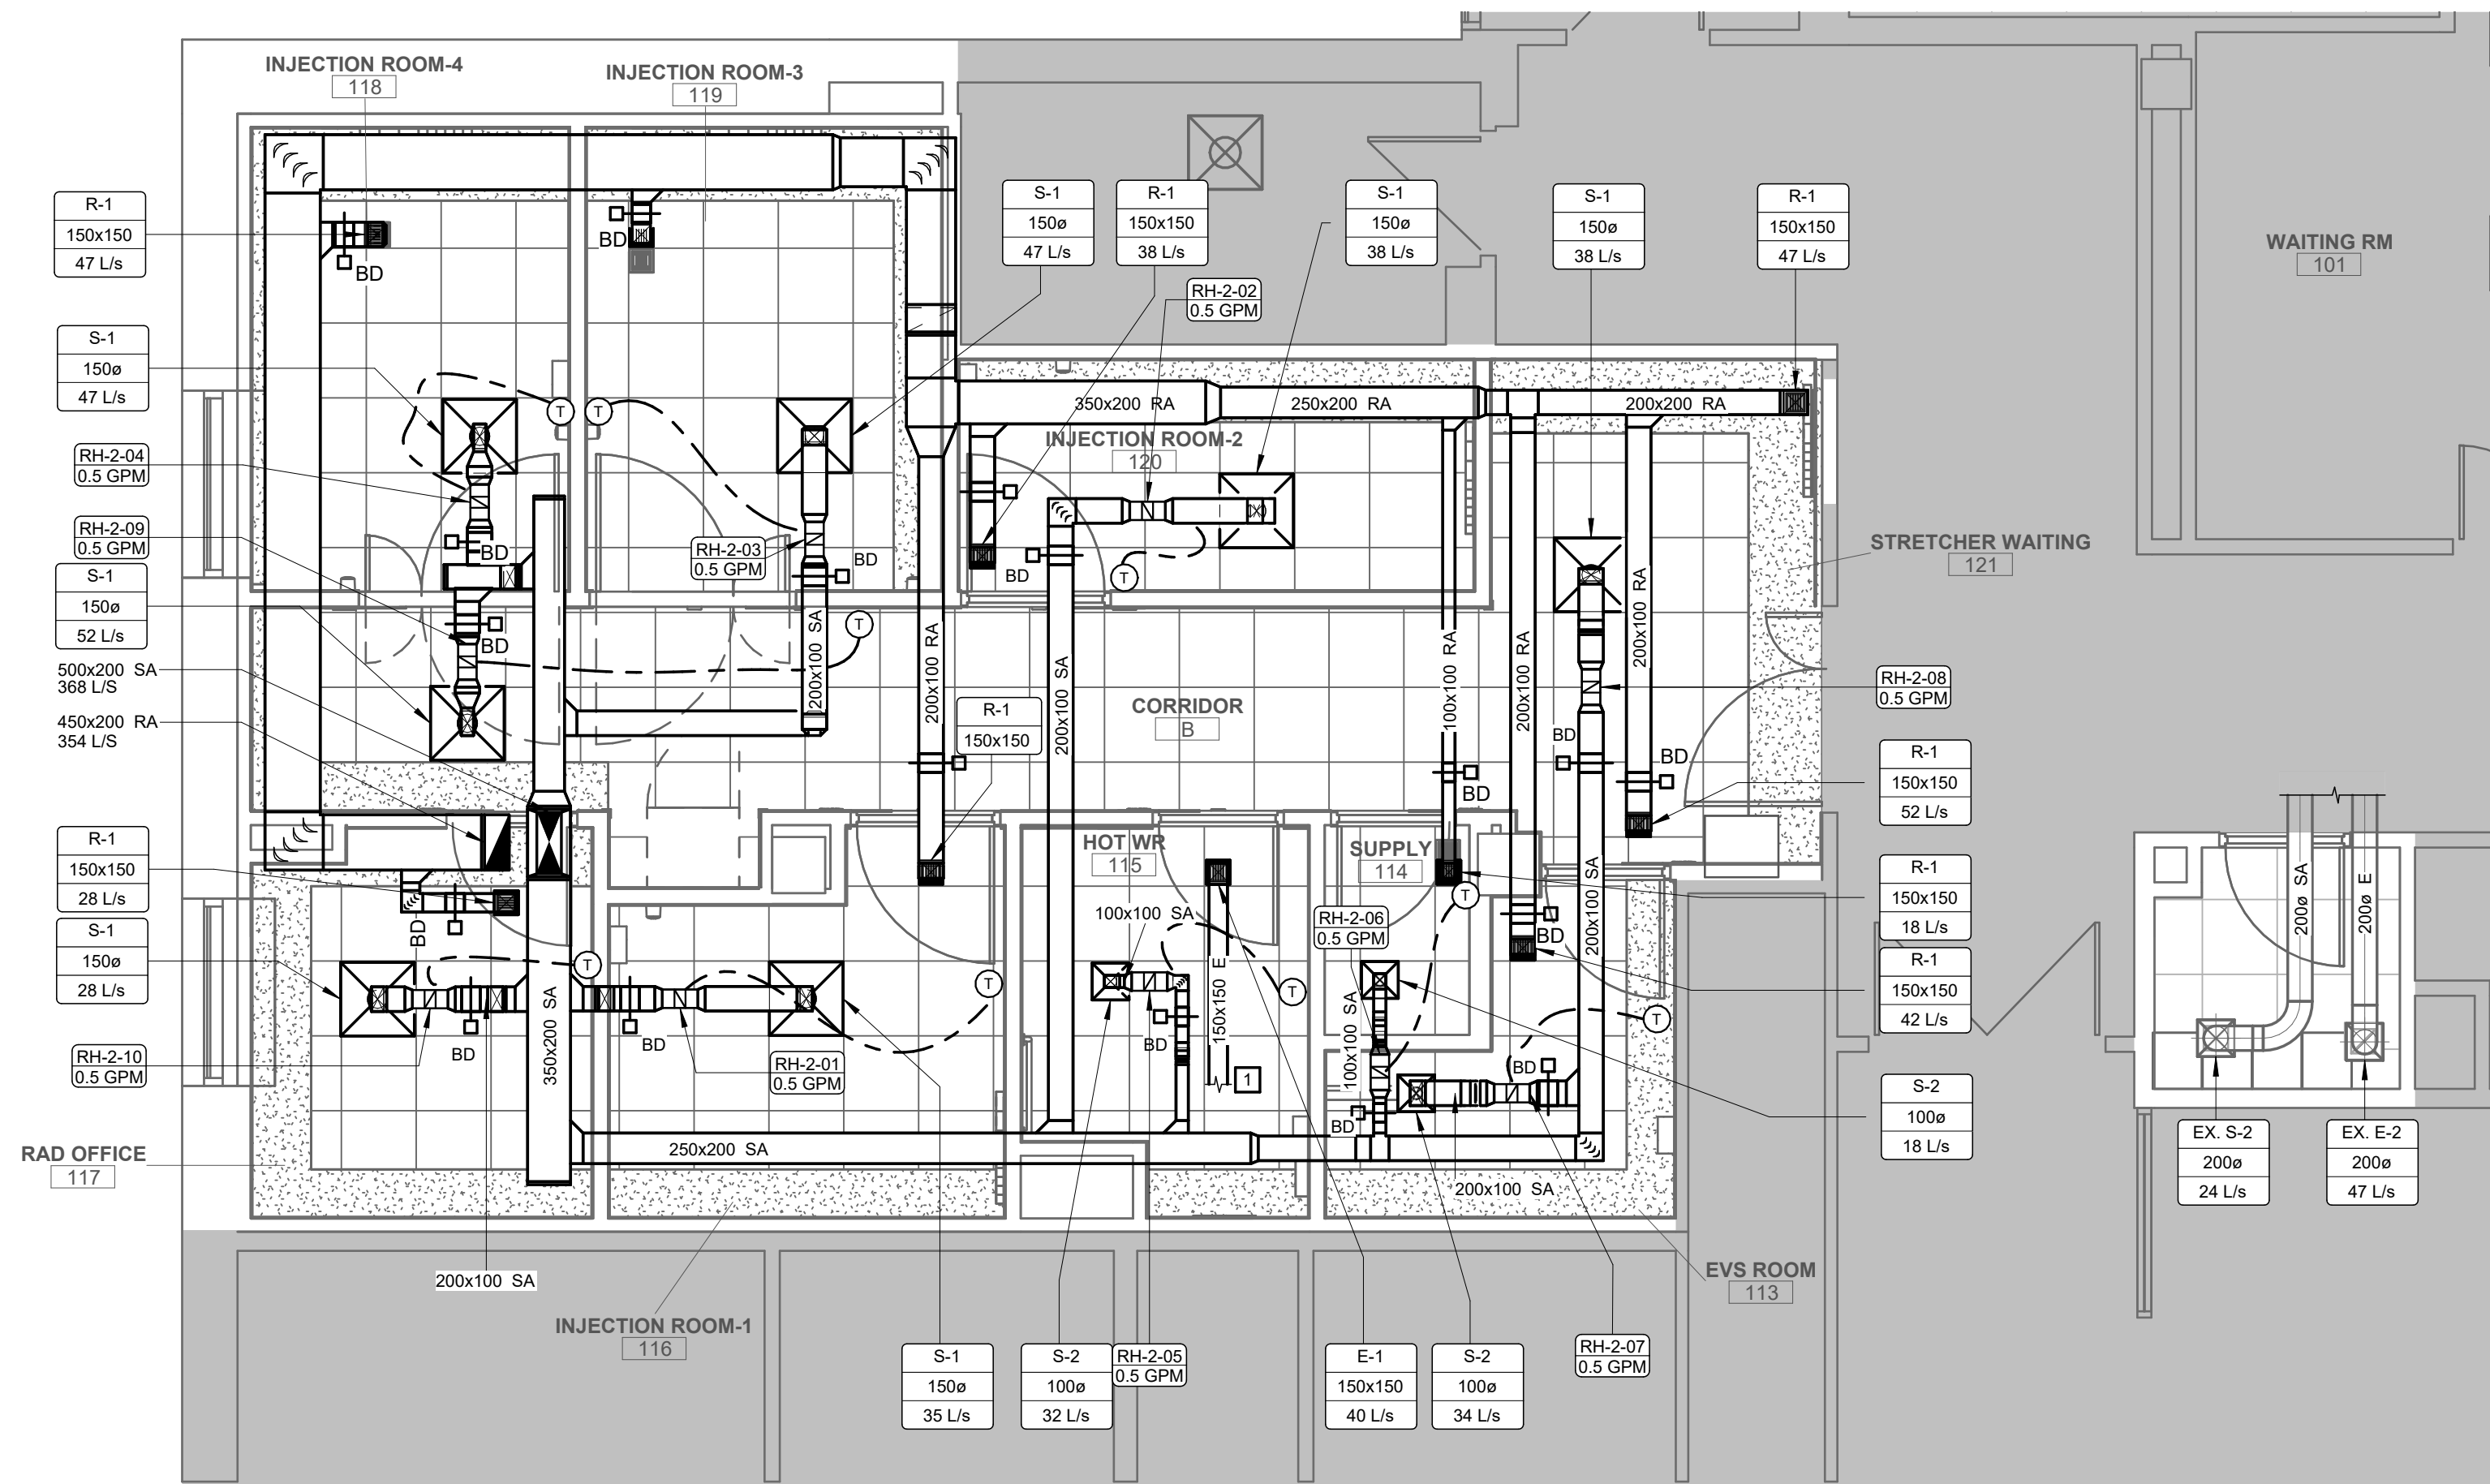

LEVEL 2 HVAC PROPOSED PLAN - INJECTION ROOM AREA - NEW CONSTRUCTION ONLY


2
1 : 50 M503

CONSTRUCTION NOTES

- A. ALPHABETICAL NOTES ARE GENERAL TO THE PLAN(S) ON THIS SHEET
- F** NUMERICAL NOTES ARE KEYED NOTES CORRESPONDING TO KEYED NOTES ON PLAN(S) ON THIS SHEET
- A. INSTALL DUCTING OFF WALL TO ENSURE ACCESS TO DUCT ACCESS DOORS TO RESET EXISTING FIRE DAMPERS.
- B.
1. CONNECT NEW EXHAUST DUCT TO EXISTING DUCT. EXISTING DUCT NOT SHOWN ON NEW CONSTRUCTION ONLY PLAN.



PROJECT LOGO

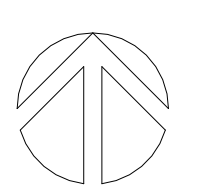

KEY PLAN

ISSUED FOR TENDER
(2026.02.27)

7	ISSUED FOR TENDER	2026.04.10
6	ISSUED FOR TENDER	2025.12.12
5	ISSUED FOR PERMIT	2025.11.26
4	FINAL DESIGN DEVELOPMENT SET	2025.11.07
3	100% DESIGN DEVELOPMENT SET	2025.10.31
2	100% DESIGN DEVELOPMENT PROGRESS SET	2025.09.29
1	50% DESIGN DEVELOPMENT PROGRESS SET	2025.05.09

No.	DESCRIPTION	DATE
-----	-------------	------

REVISIONS:

DISCREPANCIES MUST BE REPORTED IMMEDIATELY TO THE ARCHITECT / ENGINEER BEFORE PROCEEDING.

ONLY FIGURED DIMENSIONS MUST BE USED.

THE CONTRACTOR MUST CHECK THE DIMENSIONS ON SITE.

THE DRAWING IS PROTECTED BY COPYRIGHT.

ALL DIMENSIONS ARE SHOWN IN MILLIMETERS.

DO NOT SCALE THE DRAWINGS.

mcCallumSather
Westinghouse HQ, 2nd Floor
286 Sanford Ave. N
Hamilton, ON L8L 6A1
905.526.6700
www.mccallumsather.com

SEAL

CONSULTANTS:

PROJECT:
WATERLOO REGIONAL HEALTH NETWORK @ MODTPWN - PET CT


835 KING ST W, KITCHENER, ON N2G 1G

DRAWING TITLE:
LEVEL 2 HVAC PROPOSED PLAN - INJECTION ROOM AREA

DRAWN BY:	SB.MC	DATE:	2024/09/01
CHECKED BY:	DR. AB	SCALE:	1:50


PROJECT NO.: **24048**

DRAWINGS NO.: **M503**

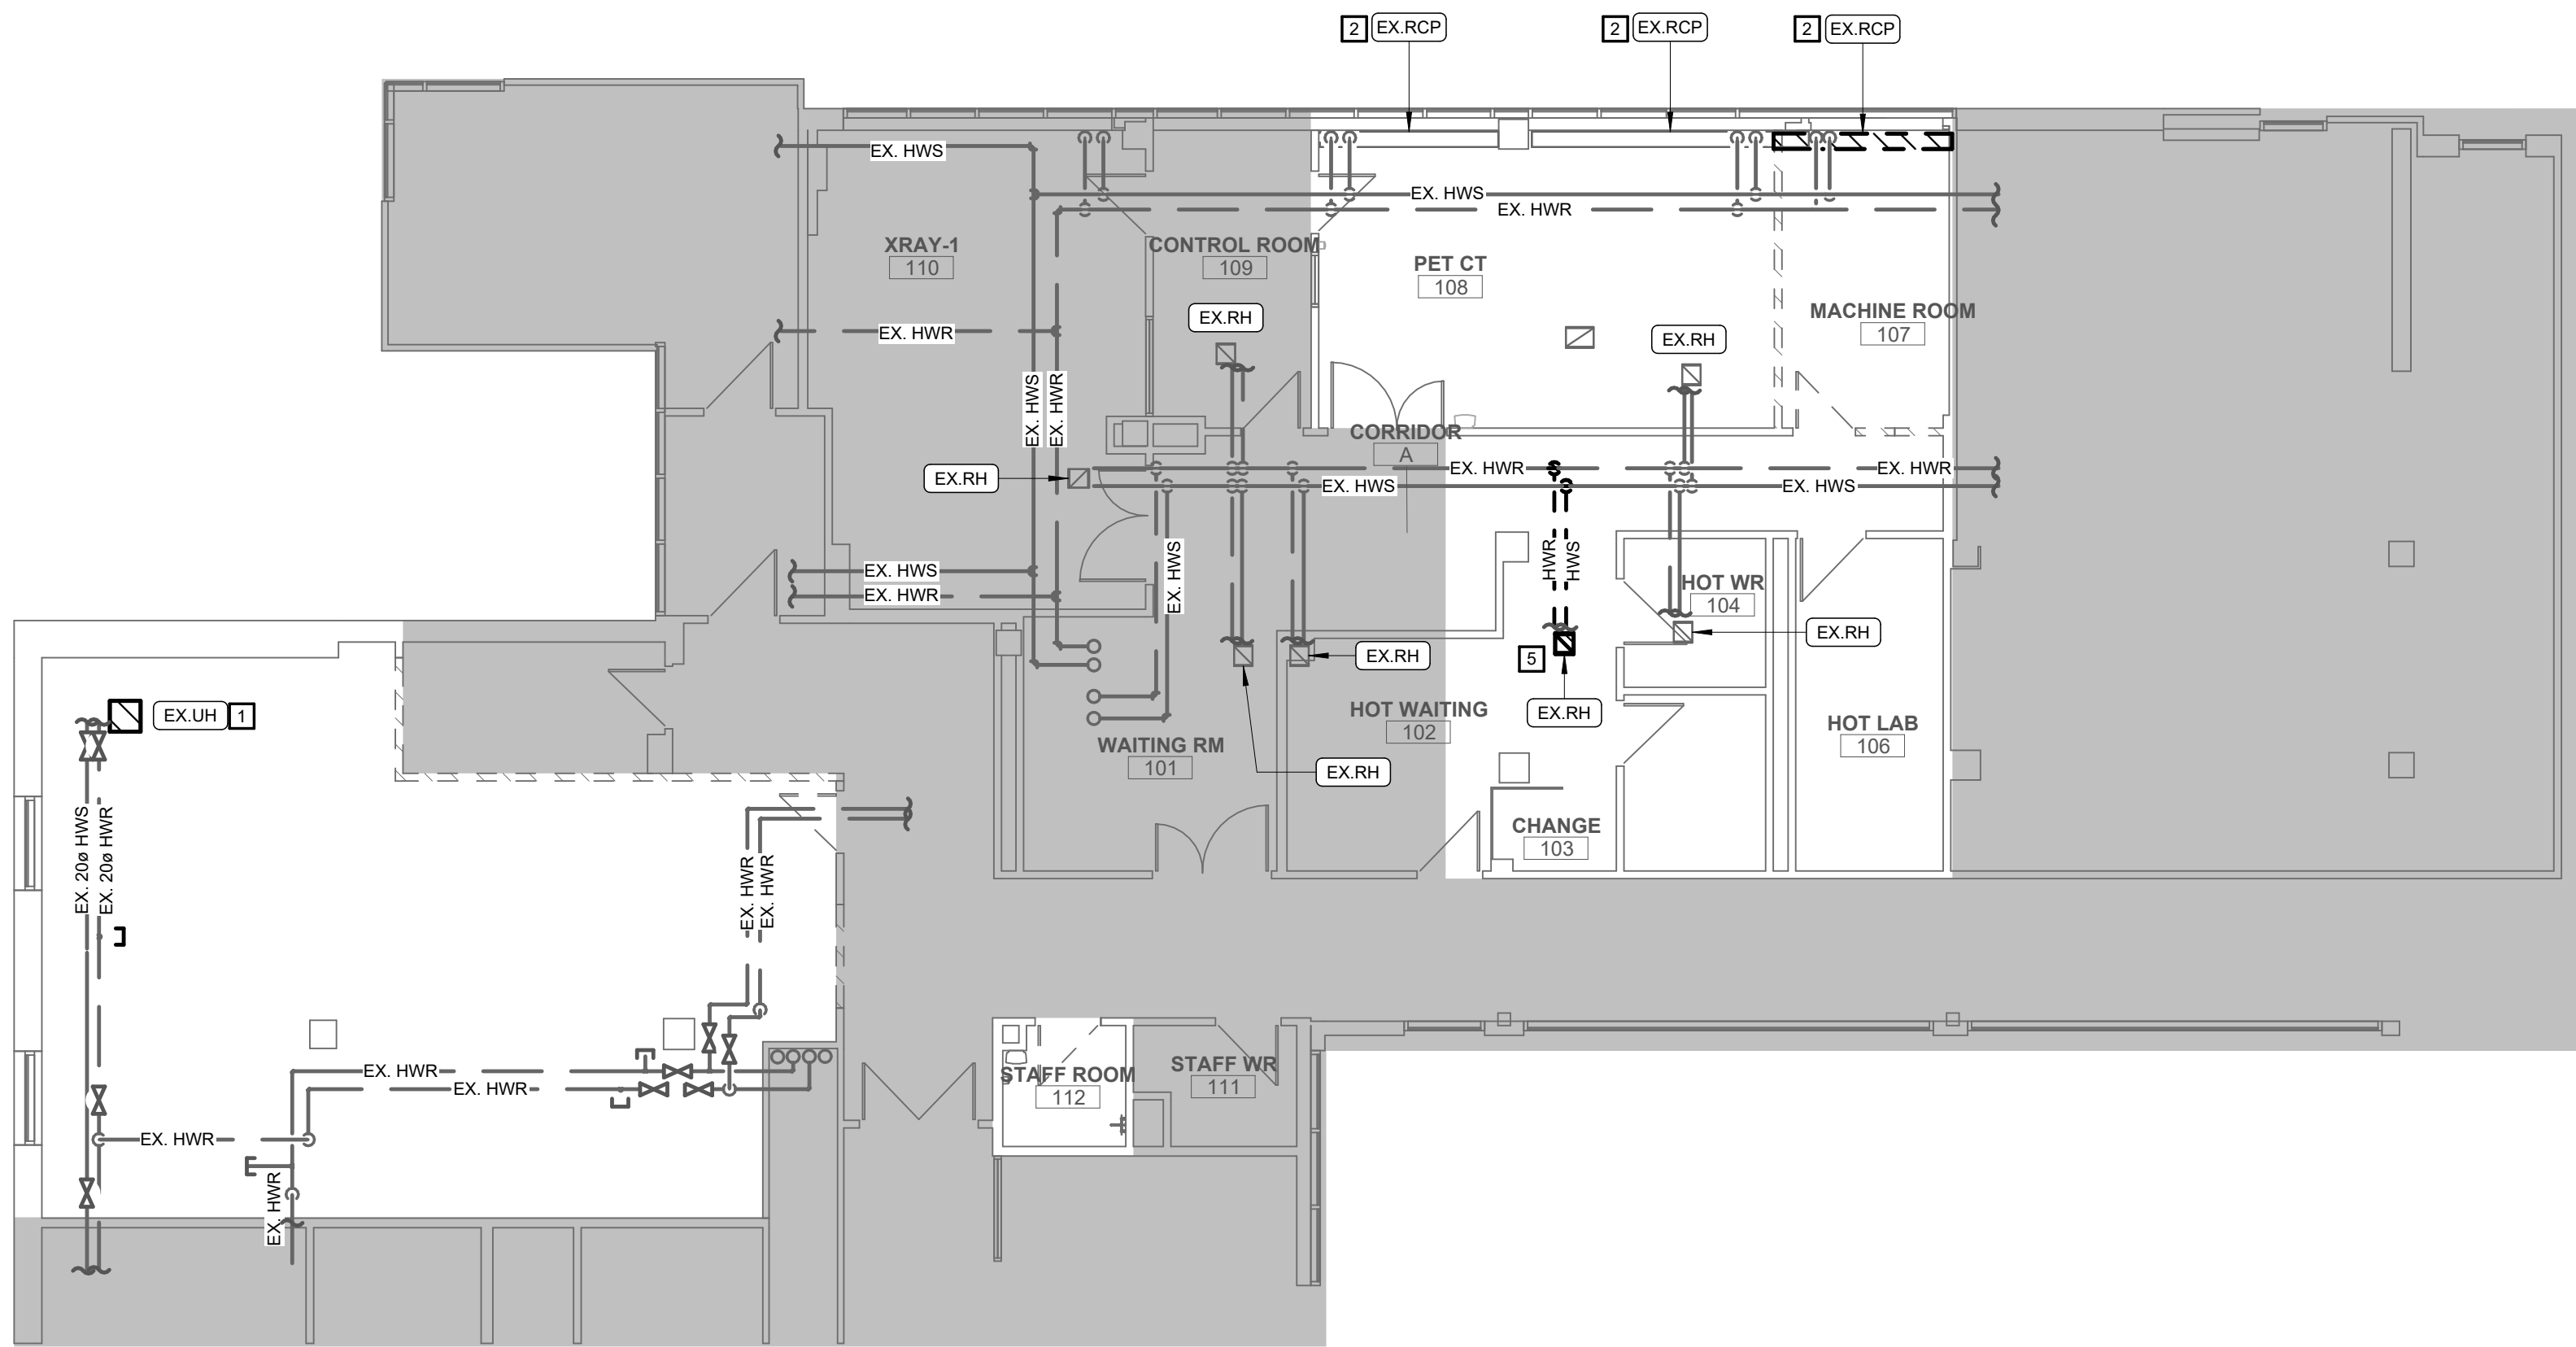

LEVEL 2 HYDRONIC DEMO PLAN

1
1:100 M600

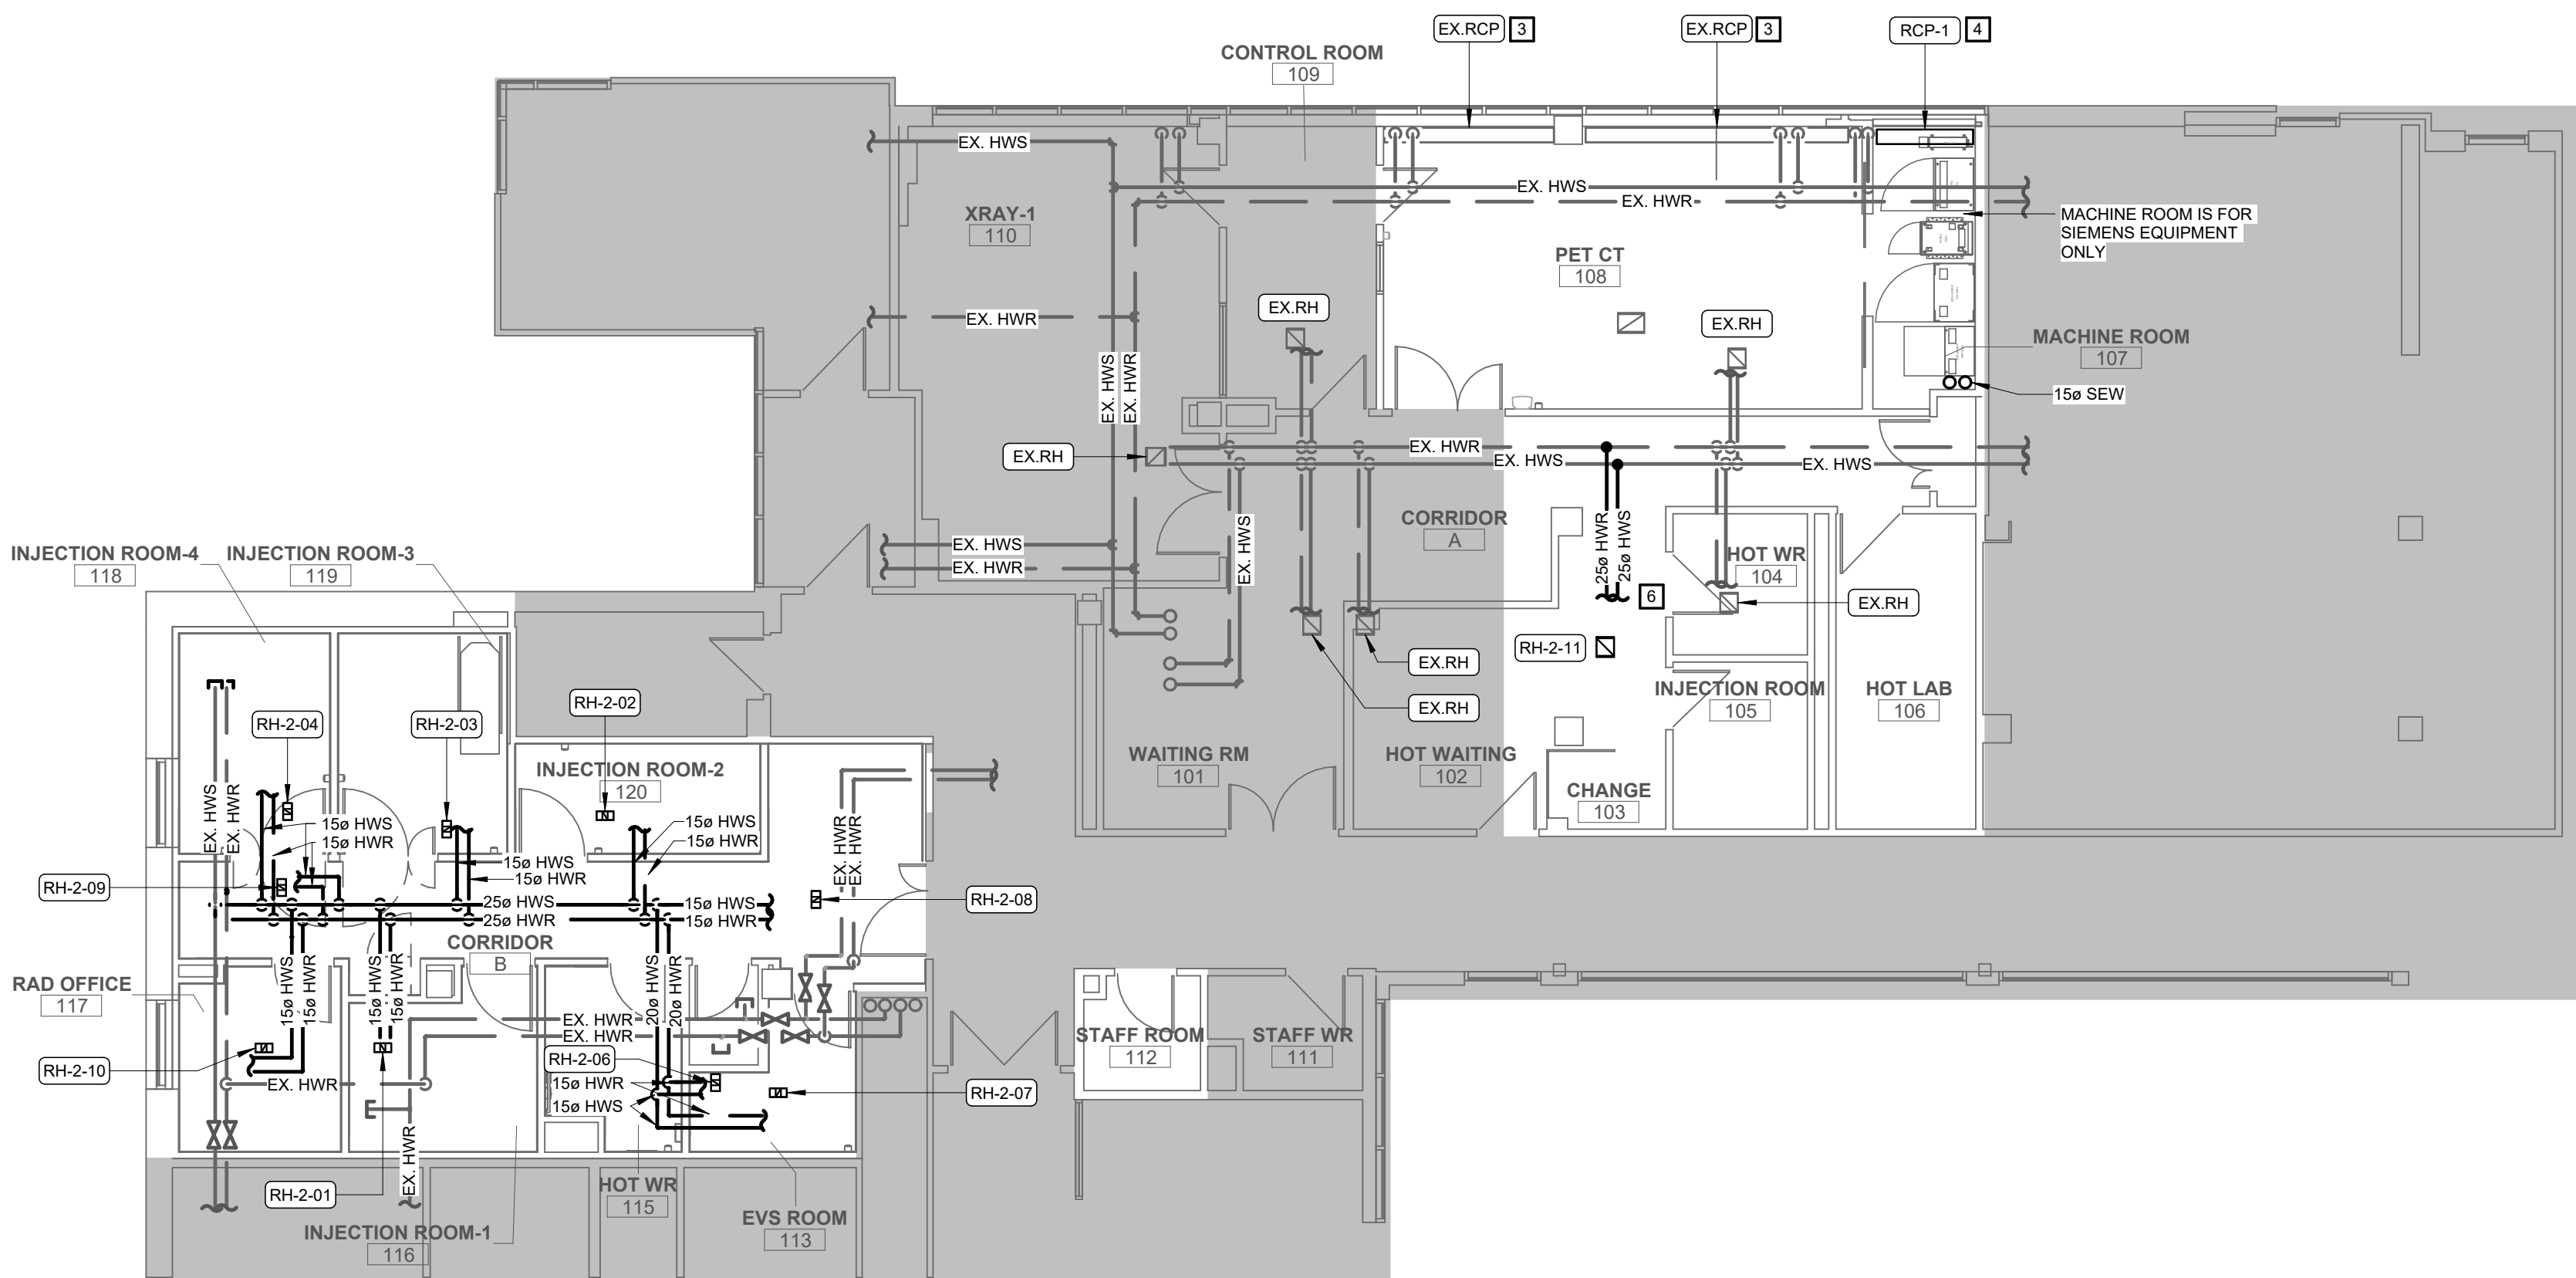

LEVEL 2 HYDRONIC PROPOSED PLAN

2
1:100 M600



CONSTRUCTION NOTES

- A. ALPHABETICAL NOTES ARE GENERAL TO THE PLAN(S) ON THIS SHEET
- NUMERICAL NOTES ARE KEYED NOTES CORRESPONDING TO KEYED NOTES ON PLAN(S) ON THIS SHEET
- MECHANICAL CONTRACTOR TO COORDINATE WITH CONTROLS CONTRACTOR TO HAVE A LEAK DETECTOR SENSOR CONNECTED TO EXISTING BAS.
 - EXISTING UNIT HEATER TO BE REMOVED. COORDINATE WITH ELECTRICAL CONTRACTOR FOR ELECTRICAL DISCONNECTION.
 - ISOLATE AND DISCONNECT HWS & HWR AND REMOVE EXISTING HYDRONIC RADIANT PANELS.
 - INSTALL EXISTING HYDRONIC RADIANT CEILING PANELS IN NEW CEILING GRID. COORDINATE CEILING GRID WITH GENERAL CONTRACTOR. REWORK EXISTING HWS & HWR AND RECONNECT EXISTING RADIANT CEILING PANELS.
 - PROVIDE NEW RADIANT CEILING PANEL IN NEW CEILING GRID. COORDINATE CEILING GRID WITH GENERAL CONTRACTOR. REWORK EXISTING HWS & HWR AND RECONNECT RADIANT CEILING PANELS.
 - REMOVE EXISTING DUCT HEAT AND CAP HWS AND HWR PIPING AT MAINS.
 - EXTEND 25mm DIAMETER HWS & HWR FROM MAINS TO NEW REHEAT COIL. REFER TO DETAILS FOR PIPING ARRANGEMENTS.

TO BE DEMOLISHED



PROJECT LOGO

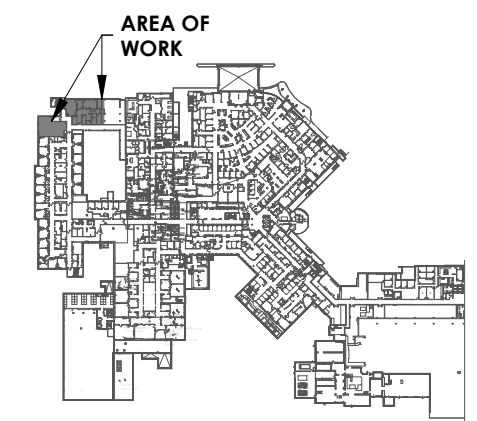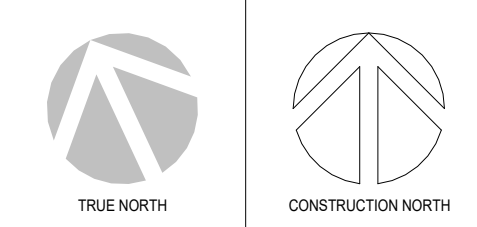

KEY PLAN

ISSUED FOR TENDER
(2026.02.27)

7	ISSUED FOR TENDER	2026.04.10
6	ISSUED FOR TENDER	2025.12.12
5	ISSUED FOR PERMIT	2025.11.26
4	FINAL DESIGN DEVELOPMENT SET	2025.11.07
3	100% DESIGN DEVELOPMENT SET	2025.10.31
2	100% DESIGN DEVELOPMENT PROGRESS SET	2025.09.29
1	50% DESIGN DEVELOPMENT PROGRESS SET	2025.05.09

No.	DESCRIPTION	DATE
1	50% DESIGN DEVELOPMENT PROGRESS SET	2025.05.09
2	100% DESIGN DEVELOPMENT PROGRESS SET	2025.09.29
3	100% DESIGN DEVELOPMENT SET	2025.10.31
4	FINAL DESIGN DEVELOPMENT SET	2025.11.07
5	ISSUED FOR PERMIT	2025.11.26
6	ISSUED FOR TENDER	2025.12.12
7	ISSUED FOR TENDER	2026.04.10

DISCREPANCIES MUST BE REPORTED IMMEDIATELY TO THE ARCHITECT/ENGINEER BEFORE PROCEEDING. ONLY FIGURED DIMENSIONS MUST BE USED. THE CONTRACTOR MUST CHECK THE DIMENSIONS ON SITE. THE DRAWING IS PROTECTED BY COPYRIGHT. ALL DIMENSIONS ARE SHOWN IN MILLIMETERS. DO NOT SCALE THE DRAWINGS.

mcCallumSather
Westinghouse HQ, 2nd Floor
286 Sanford Ave. N
Hamilton, ON L8L 6A1
905.526.6700
www.mccallumsather.com

SEAL

CONSULTANTS:

PROJECT:
WATERLOO REGIONAL HEALTH NETWORK @ MODTPWN - PET CT

835 KING ST W, KITCHENER, ON N2G 1G


DRAWING TITLE:
LEVEL 2 HYDRONIC DEMO & PROPOSED PLAN

DRAWN BY: SB.MC DATE: 2024/09/01
CHECKED BY: DR. AB SCALE: As indicated

PROJECT NO: **24048**


DRAWING NO: **M600**

MECHANICAL CONTRACTOR TO REVIEW AND FOLLOW SIEMENS PET CT SCANNER DRAWINGS 01-SK-1 THROUGH 01-SK-4

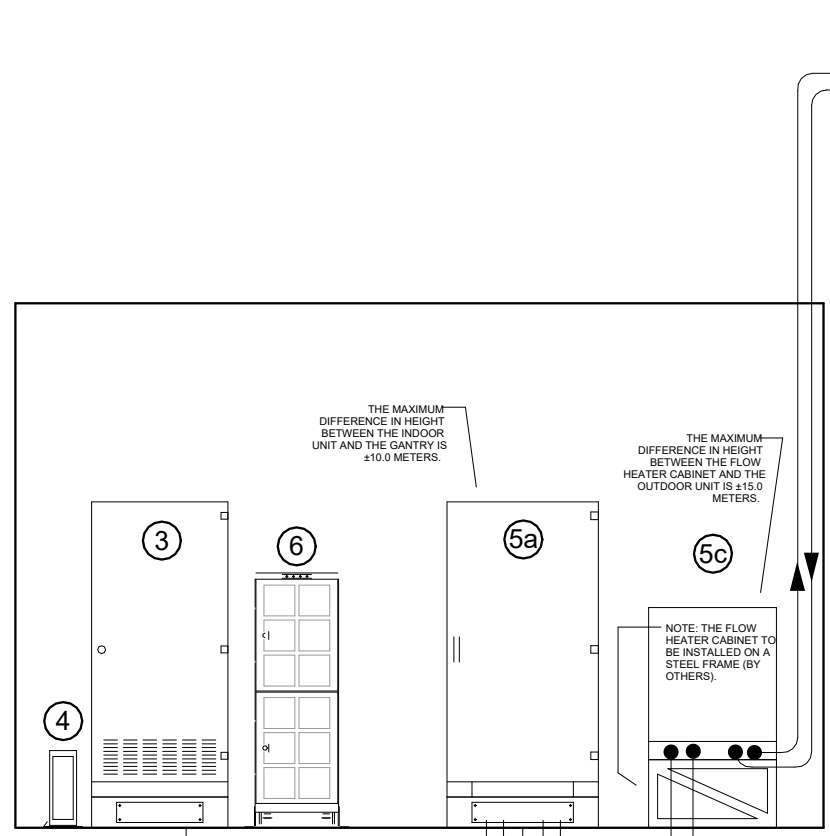

SIEMENS EQUIPMENT DETAIL

N.T.S. M600

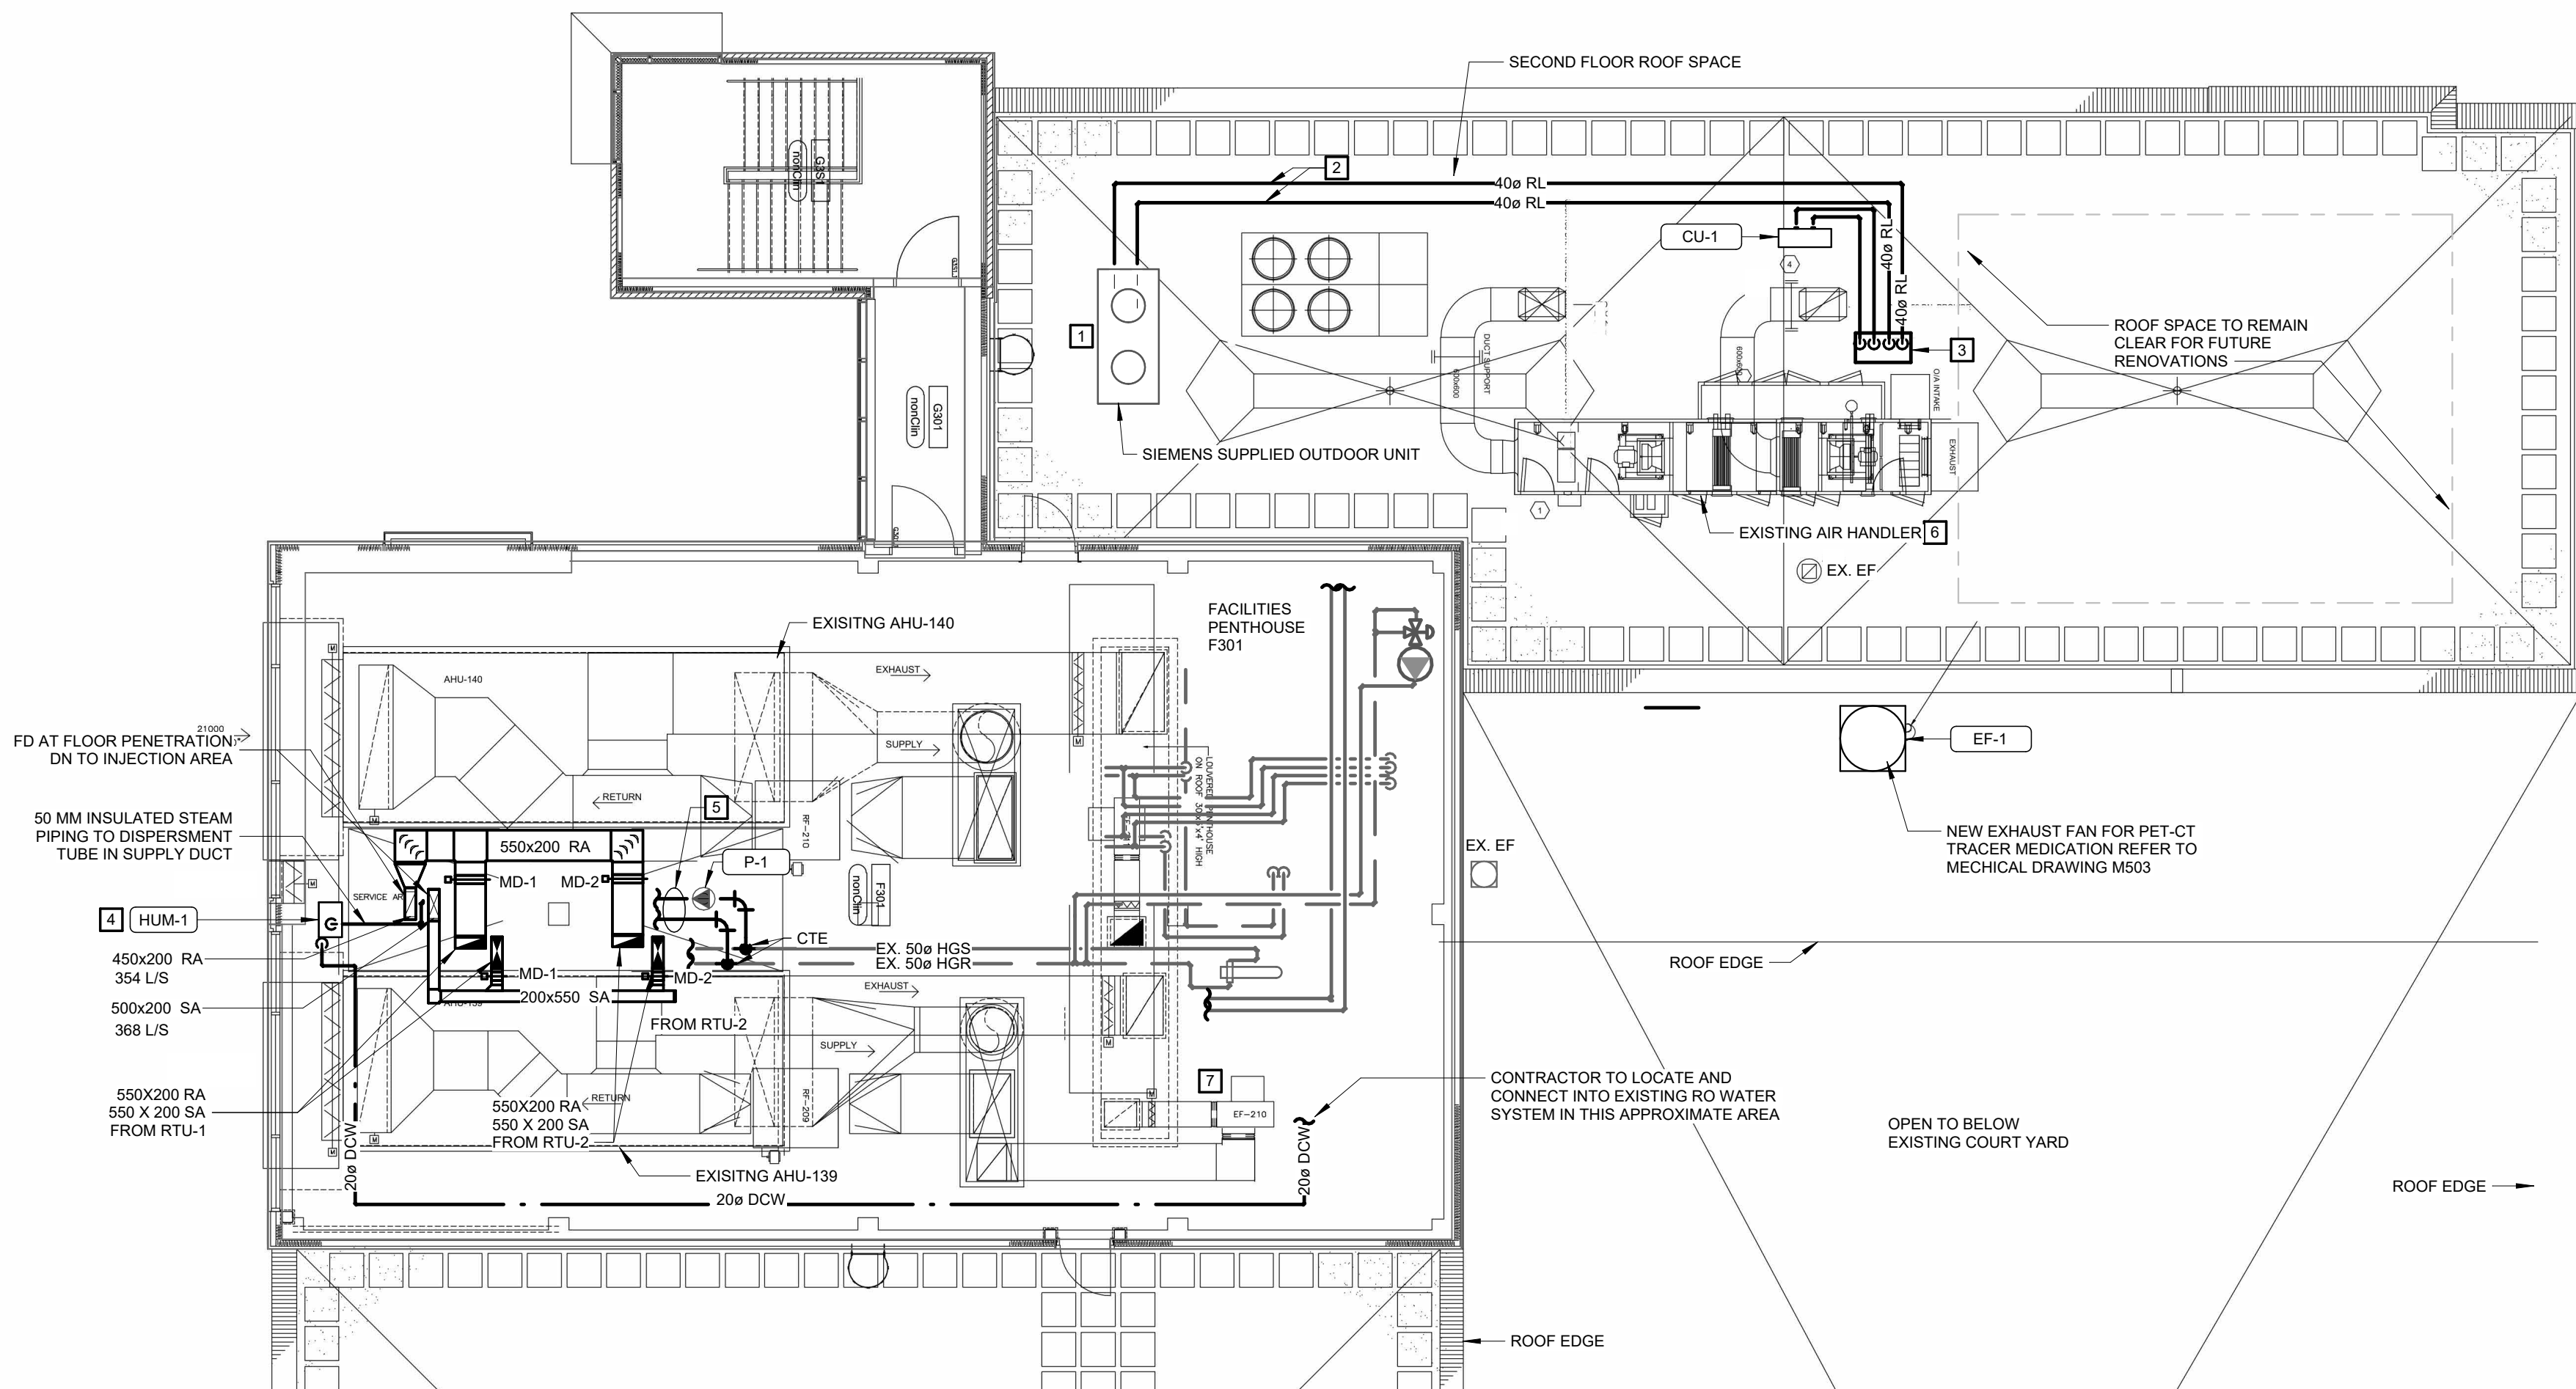

PENTHOUSE HVAC PLAN
1
1 : 100 M700

CONSTRUCTION NOTES

A. ALPHABETICAL NOTES ARE GENERAL TO THE PLAN(S) ON THIS SHEET

NUMERICAL NOTES ARE KEYED NOTES CORRESPONDING TO KEYED NOTES ON PLAN(S) ON THIS SHEET

1. CT SCANNER OUTDOOR UNIT SUPPLY BY SIEMENS INSTALLED BY MECHANICAL. REFER TO STRUCTURAL DRAWINGS FOR ROOF MOUNTING SUPPORTS.

2. TWO 25MM HIGH PRESSURE WATER HOSES. MAX LENGTH = 40.0 M (SUPPLIED BY SIEMENS). EACH HOSE IN A 80 MM (3") CONDUIT BY MECHANICAL CONTRACTOR TO SUPPORT 14" OFF ROOF SURFACE BY LARGE FOUR PRINT PIPE SUPPORT. COMMISSIONED BY SIEMENS.

3. PROVIDE A MECHANICAL PIPING DOG HOUSE FOR CT SCANNER OUT DOOR UNIT PIPING AND CU-1 REFRIGERANT PIPING INCLUDING CONTROL WIRING. SCAN AND XRAY CONCRETE ROOF DECK PRIOR TO CORING. MECHANICAL CONTRACTOR FOR FLASHING IN DOG HOUSE INTO EXISTING ROOFING SYSTEM.

4. HUMIDIFIER TO BE MOUNTED ON A MANUFACTURERS SUPPLIED STAND.

5. REFER TO THE SCHEMATICS ON MECHANICAL DRAWING M800 FOR COMPLETE PIPE ARRANGEMENT. PIPING TO BE INSULATED, JACKETED AND HEAT TRACED 3.8W/FT SELF REGULATING WIRE. TYPICAL FOR ALL NEW EXTERIOR. MECHANICAL CONTRACTOR TO PROVIDE AND INSTALL MECHANICAL DOG HOUSE FOR PIPE PENETRATION THROUGH ROOF.

6. REBALANCE EXISTING ROOF MOUNTED AIR HANDLER TO PROVIDE AN ADDITIONAL 284 L/s

7. REBALANCE EXISTING EXHAUST FAN TO PROVIDE AN ADDITIONAL 40 L/s




WRHN
Waterloo Regional
Health Network

PROJECT LOGO




TRUE NORTH

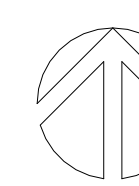

CONSTRUCTION NORTH

AREA OF WORK

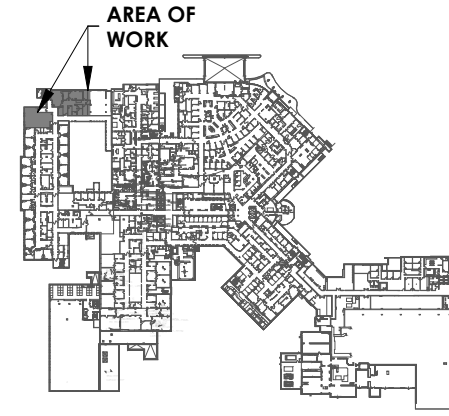

KEY PLAN

ISSUED FOR TENDER
(2026.02.27)

7	ISSUED FOR TENDER	2026.04.10
6	ISSUED FOR TENDER	2025.12.12
5	ISSUED FOR PERMIT	2025.11.26
4	FINAL DESIGN DEVELOPMENT SET	2025.11.07
3	100% DESIGN DEVELOPMENT SET	2025.10.31
2	100% DESIGN DEVELOPMENT PROGRESS SET	2025.09.29
1	50% DESIGN DEVELOPMENT PROGRESS SET	2025.05.09

No.	DESCRIPTION	DATE
REVISIONS		
DISCREPANCIES MUST BE REPORTED IMMEDIATELY TO THE ARCHITECT / ENGINEER BEFORE PROCEEDING. ONLY FIGURED DIMENSIONS MUST BE USED. THE CONTRACTOR MUST CHECK THE DIMENSIONS ON SITE. THE DRAWING IS PROTECTED BY COPYRIGHT. ALL DIMENSIONS ARE SHOWN IN MILLIMETERS. DO NOT SCALE THE DRAWINGS.		



Westinghouse HQ, 2nd Floor
286 Sanford Ave. N
Hamilton, ON L8L 6A1
905.526.6700
www.mccallumsather.com

SEAL

CONSULTANTS:

PROJECT:
WATERLOO REGIONAL HEALTH NETWORK @ MODTPWN - PET CT


835 KING ST W, KITCHENER, ON N2G 1G

DRAWING TITLE:
MECHANICAL PENTHOUSE HVAC PLAN

DRAWN BY:	SB.MC	DATE:	2024/09/01
CHECKED BY:	DR. AB	SCALE:	As indicated

PROJECT NO:	24048
DRAWINGS NO:	M700

FILENAME: A:\bids\Draws\03484 - WRHN\PET CT Stage 2.dwg
PROJECT: 24048 - PET CT Stage 2.dwg

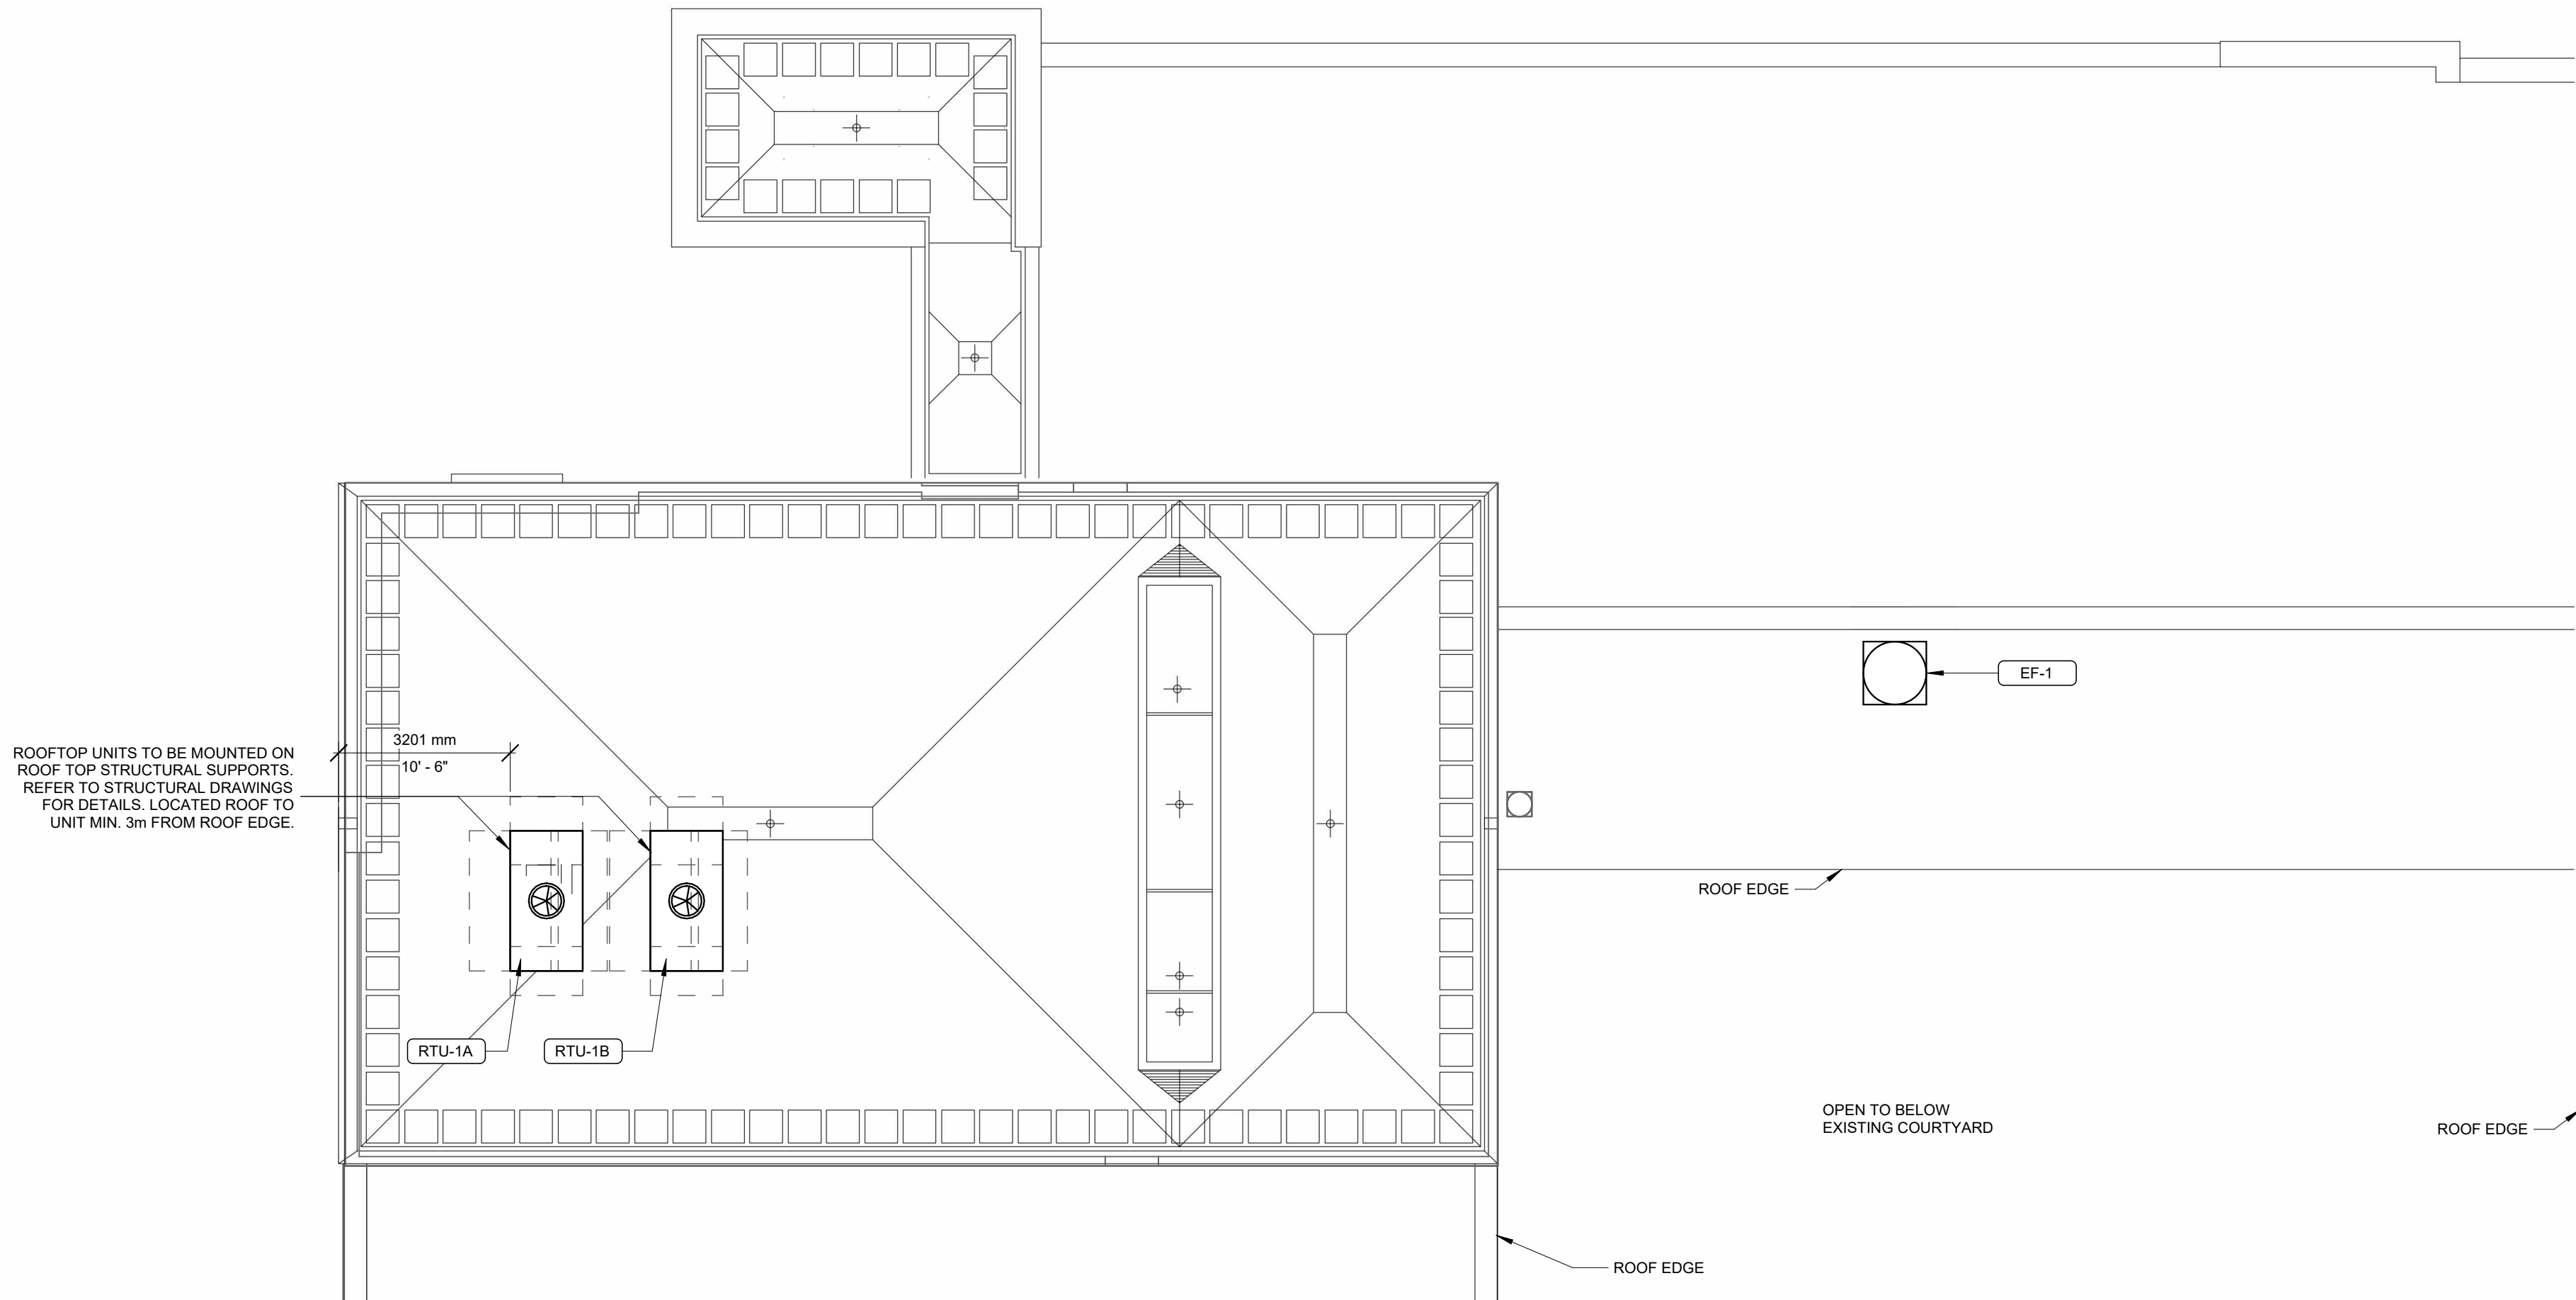

ROOF HVAC PLAN 1
1 : 100 M800

CONSTRUCTION NOTES


- A. ALPHABETICAL NOTES ARE GENERAL TO THE PLAN(S) ON THIS SHEET
- # NUMERICAL NOTES ARE KEYED NOTES CORRESPONDING TO KEYED NOTES ON PLAN(S) ON THIS SHEET




PROJECT LOGO



TRUE NORTH

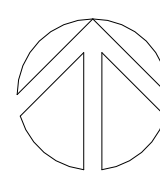

CONSTRUCTION NORTH

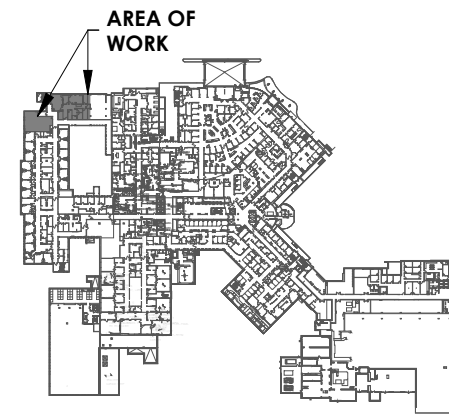

KEY PLAN

ISSUED FOR TENDER
(2026.02.27)

7	ISSUED FOR TENDER	2026.04.10
6	ISSUED FOR TENDER	2025.12.12
5	ISSUED FOR PERMIT	2025.11.26
4	FINAL DESIGN DEVELOPMENT SET	2025.11.07
3	100% DESIGN DEVELOPMENT SET	2025.10.31
2	100% DESIGN DEVELOPMENT PROGRESS SET	2025.09.29
1	50% DESIGN DEVELOPMENT PROGRESS SET	2025.05.09

No.	DESCRIPTION	DATE
-----	-------------	------

REVISIONS:

DISCREPANCIES MUST BE REPORTED IMMEDIATELY TO THE ARCHITECT / ENGINEER BEFORE PROCEEDING.
ONLY FIGURED DIMENSIONS MUST BE USED.
THE CONTRACTOR MUST CHECK THE DIMENSIONS ON SITE.
THE DRAWING IS PROTECTED BY COPYRIGHT.
ALL DIMENSIONS ARE SHOWN IN MILLIMETERS.
DO NOT SCALE THE DRAWINGS.

mcCallumSather

Westinghouse HQ, 2nd Floor
286 Sanford Ave. N
Hamilton, ON L8L 6A1
905.526.6700
www.mccallumsather.com

SEAL

CONSULTANTS:

PROJECT:

**WATERLOO REGIONAL HEALTH
NETWORK @ MODTPWN - PET CT**


**835 KING ST W, KITCHENER, ON
N2G 1G**

DRAWING TITLE:
ROOF - MECHANICAL PLAN

DRAWN BY:	SB.MC	DATE:	2024/09/01
CHECKED BY:	DR. AB	SCALE:	

PROJECT NO: **24048**

DRAWING NO: **M800**

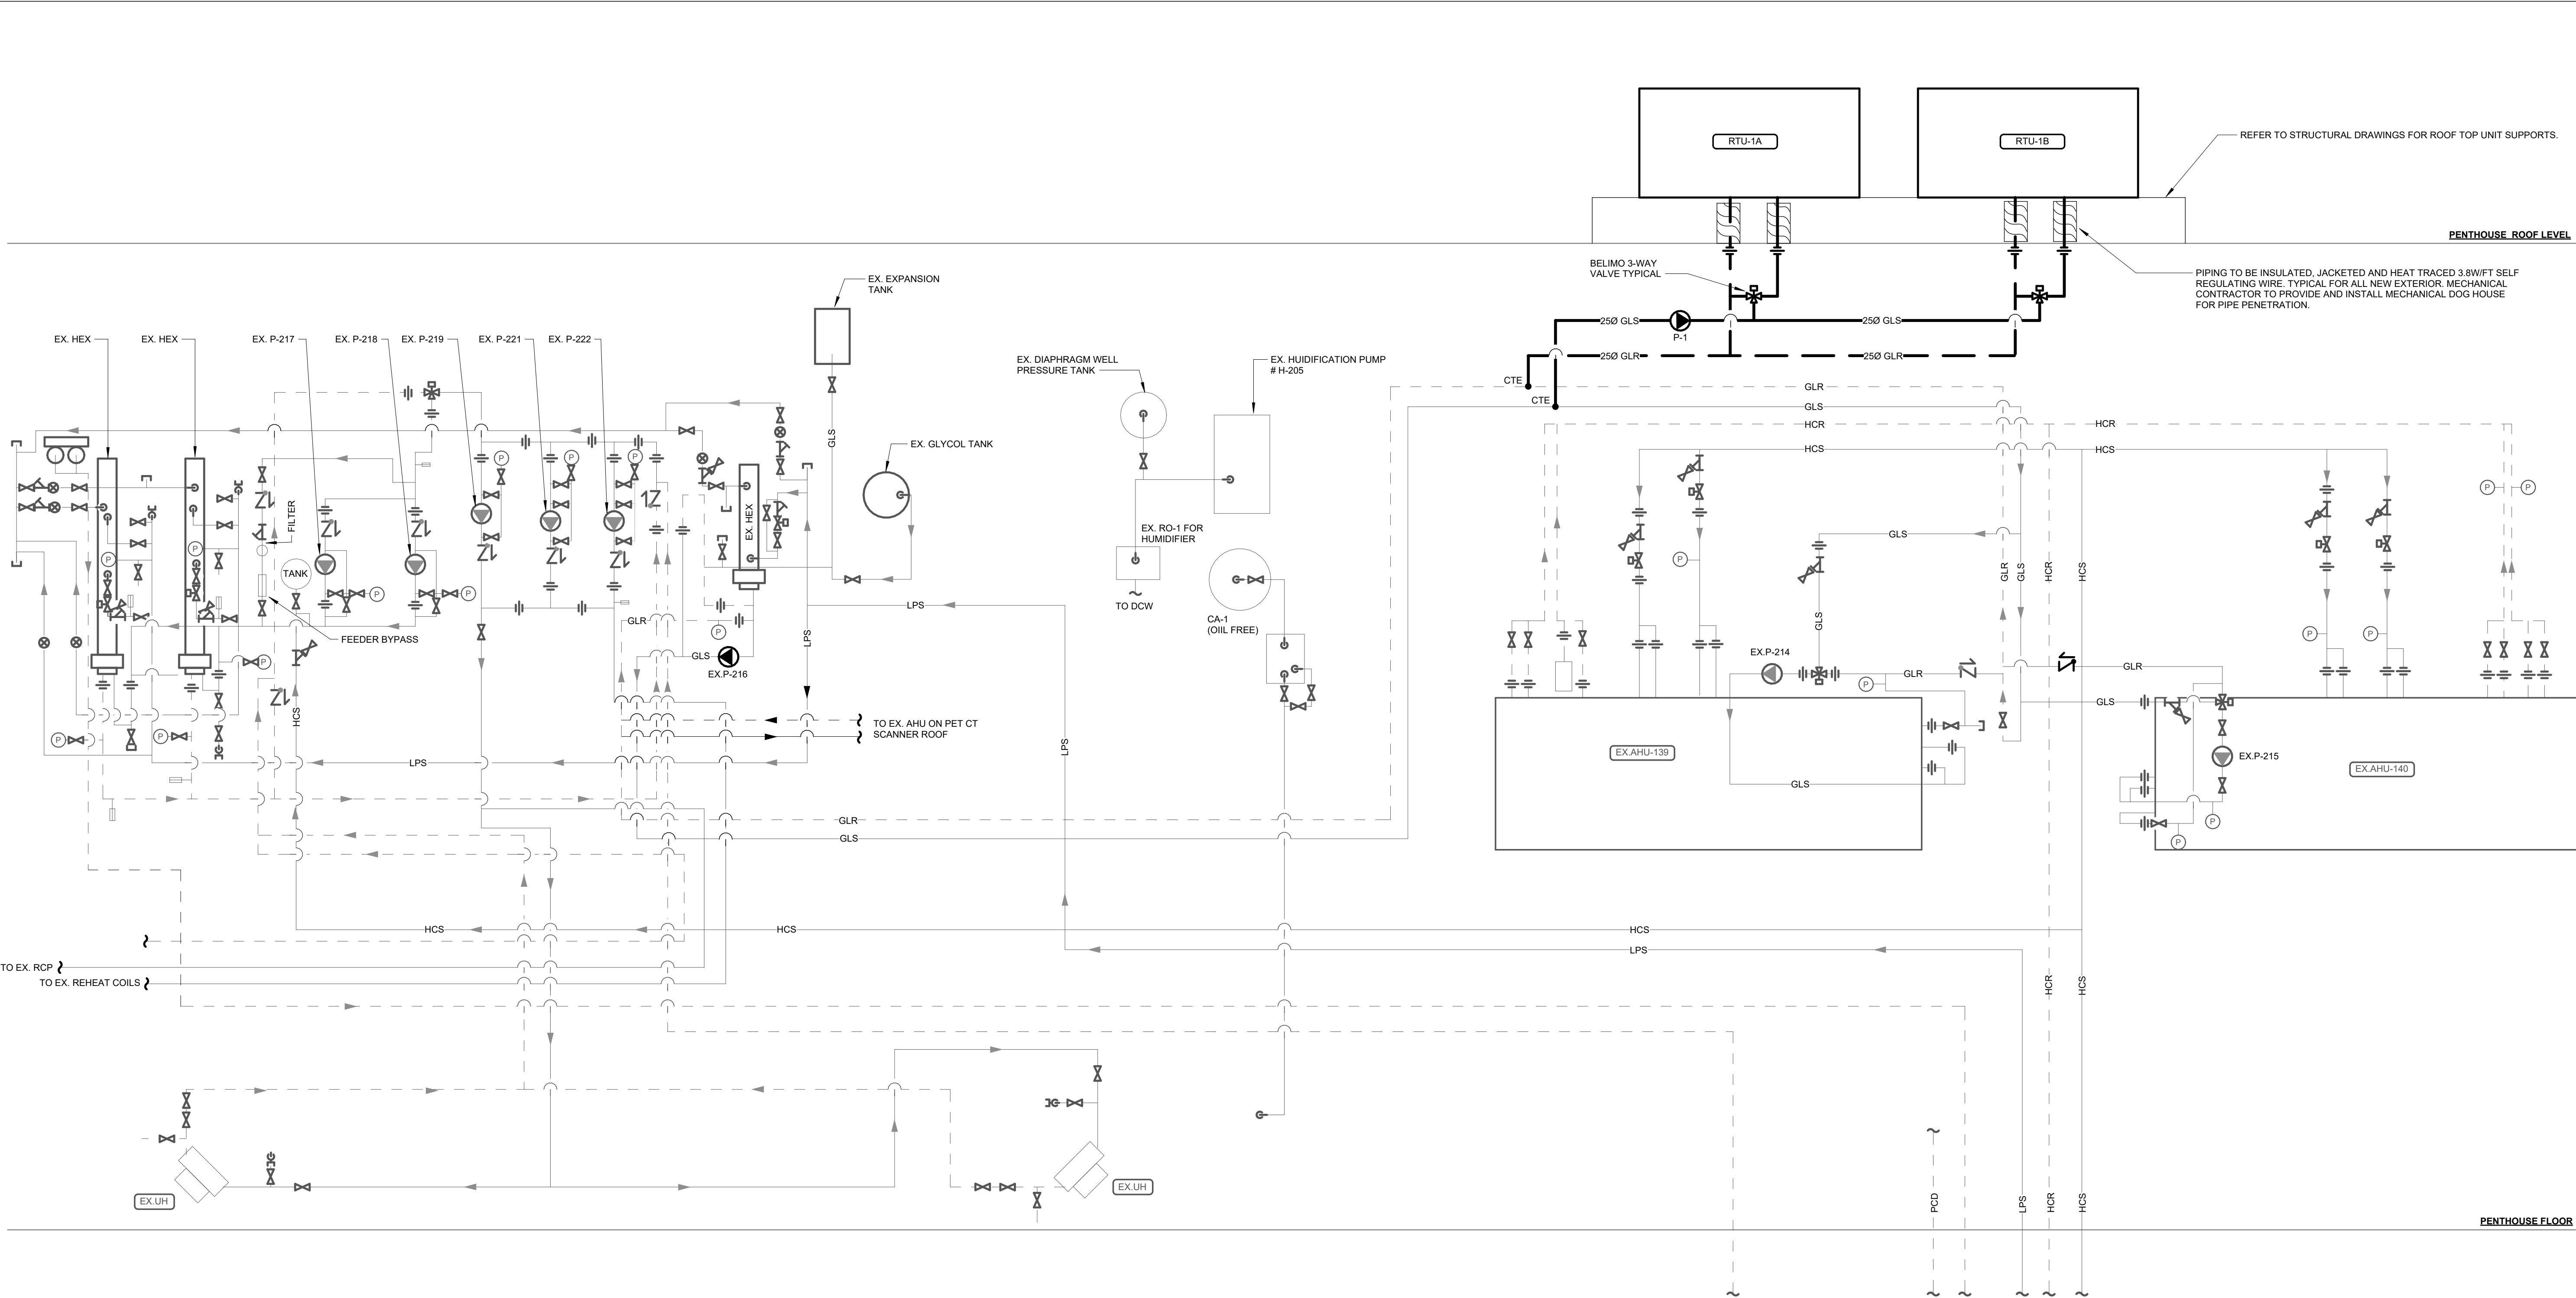



Waterloo Regional Health Network

PROJECT LOGO

KEY PLAN

ISSUED FOR TENDER (2026.02.27)

7	ISSUED FOR TENDER	2026.04.10
6	ISSUED FOR TENDER	2025.12.12
5	ISSUED FOR PERMIT	2025.11.26
4	FINAL DESIGN DEVELOPMENT SET	2025.11.07
3	100% DESIGN DEVELOPMENT SET	2025.10.31
2	100% DESIGN DEVELOPMENT PROGRESS SET	2025.09.29
1	50% DESIGN DEVELOPMENT PROGRESS SET	2025.05.09

REVISIONS

DISCREPANCIES MUST BE REPORTED IMMEDIATELY TO THE ARCHITECT / ENGINEER BEFORE PROCEEDING. ONLY FIGURED DIMENSIONS MUST BE USED. THE CONTRACTOR MUST CHECK THE DIMENSIONS ON SITE. THE DRAWING IS PROTECTED BY COPYRIGHT. ALL DIMENSIONS ARE SHOWN IN MILLIMETERS. DO NOT SCALE THE DRAWINGS.

mcCallumSather

Westinghouse HQ, 2nd Floor
286 Sanford Ave. N
Hamilton, ON L8L 6A1
905.526.6700
www.mccallumsather.com

SEAL

CONSULTANTS:

PROJECT:
WATERLOO REGIONAL HEALTH NETWORK @ MODTPWN - PET CT

835 KING ST W, KITCHENER, ON N2G 1G

DRAWING TITLE:
SCHEMATIC

DRAWN BY:	SB.MC	DATE:	2024/09/01
CHECKED BY:	DR. AB	SCALE:	1:1

PROJECT NO: 24048

DRAWING NO: M900

7	ISSUED FOR TENDER	2026.04.10
6	ISSUED FOR TENDER	2025.12.12
5	ISSUED FOR PERMIT	2025.11.26
4	FINAL DESIGN DEVELOPMENT SET	2025.11.07
3	100% DESIGN DEVELOPMENT SET	2025.10.31
2	100% DESIGN DEVELOPMENT PROGRESS SET	2025.09.29
1	50% DESIGN DEVELOPMENT PROGRESS SET	2025.05.09

No.	DESCRIPTION	DATE
-----	-------------	------

REVISIONS:

DISCREPANCIES MUST BE REPORTED IMMEDIATELY TO THE ARCHITECT/ENGINEER BEFORE PROCEEDING.

ONLY FIGURED DIMENSIONS MUST BE USED.

THE CONTRACTOR MUST CHECK THE DIMENSIONS ON SITE.

THE DRAWING IS PROTECTED BY COPYRIGHT.

ALL DIMENSIONS ARE SHOWN IN MILLIMETERS.

DO NOT SCALE THE DRAWINGS.

mcCallumSather
Westinghouse HQ, 2nd Floor
286 Sanford Ave., N
Hamilton, ON L8L 6A1
905.526.6700
www.mccallumsather.com

SEAL

CONSULTANTS:

PROJECT:
**WATERLOO REGIONAL HEALTH
NETWORK @ MODTPWN - PET CT**

**835 KING ST W, KITCHENER, ON
N2G 1G**


DRAWING TITLE:
CONTROL DIAGRAMS

DRAWN BY:	SB, MC	DATE:	2024/09/01
CHECKED BY:	DR, AB	SCALE:	1 : 1

PROJECT NO.: **24048**


DRAWING NO.:
M1000

FILENAME: Auditors_Docs\03048 - WRHN PET CT Stage 2_A_102.rvt
PROJECT: 24048 - PET CT Stage 2_A_102.rvt

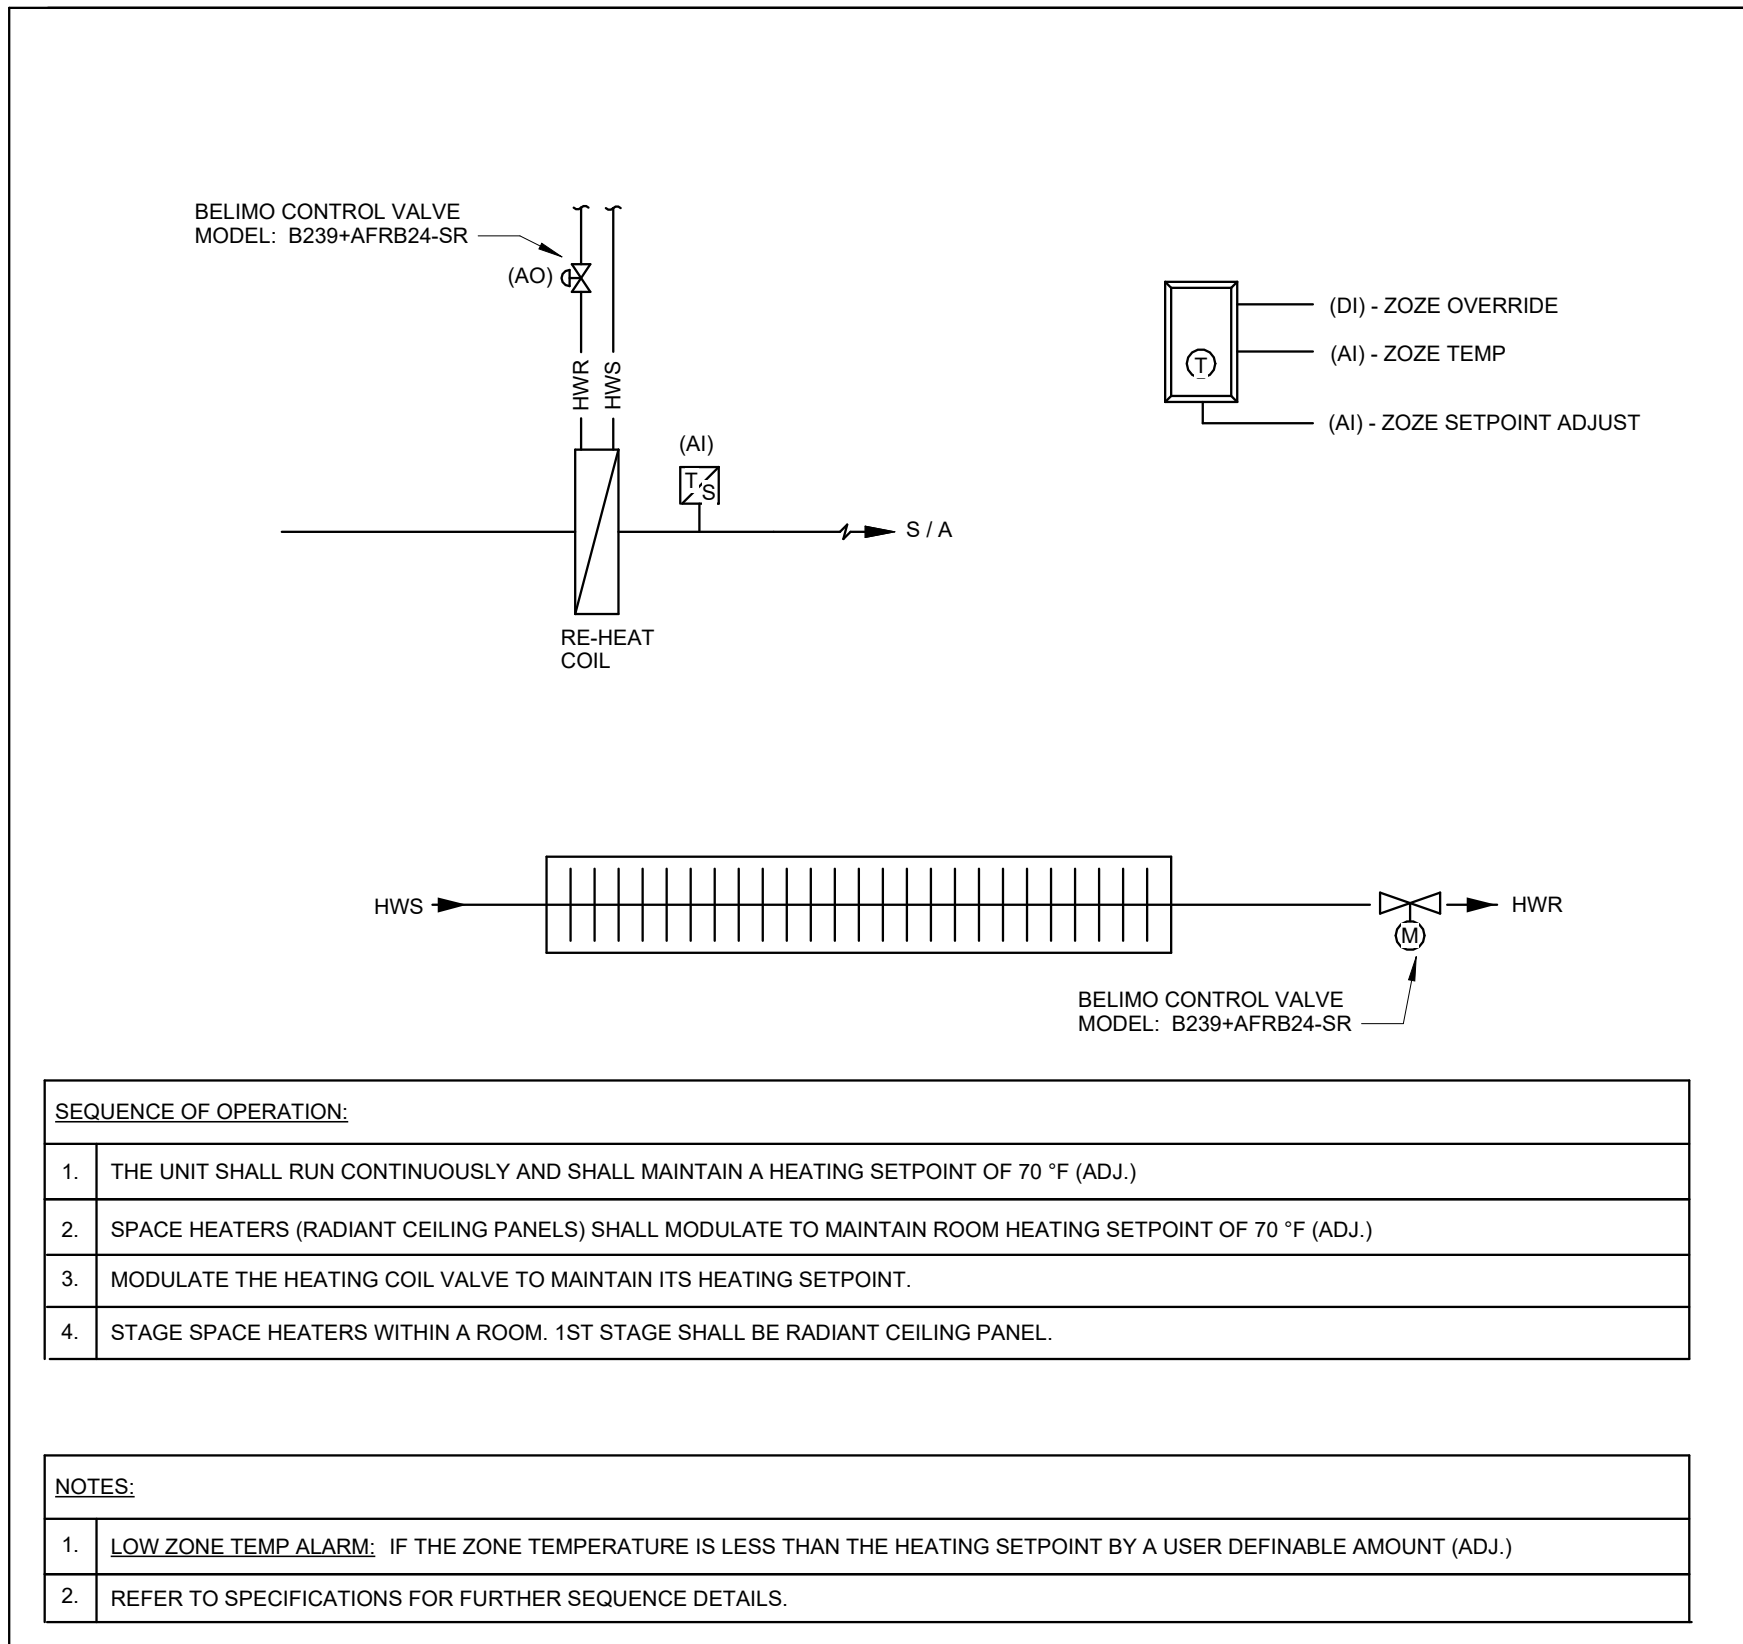

ZONE REHEAT & RADIANT PANEL HEATER CONTROL SCHEMATIC




N.T.S. M1000

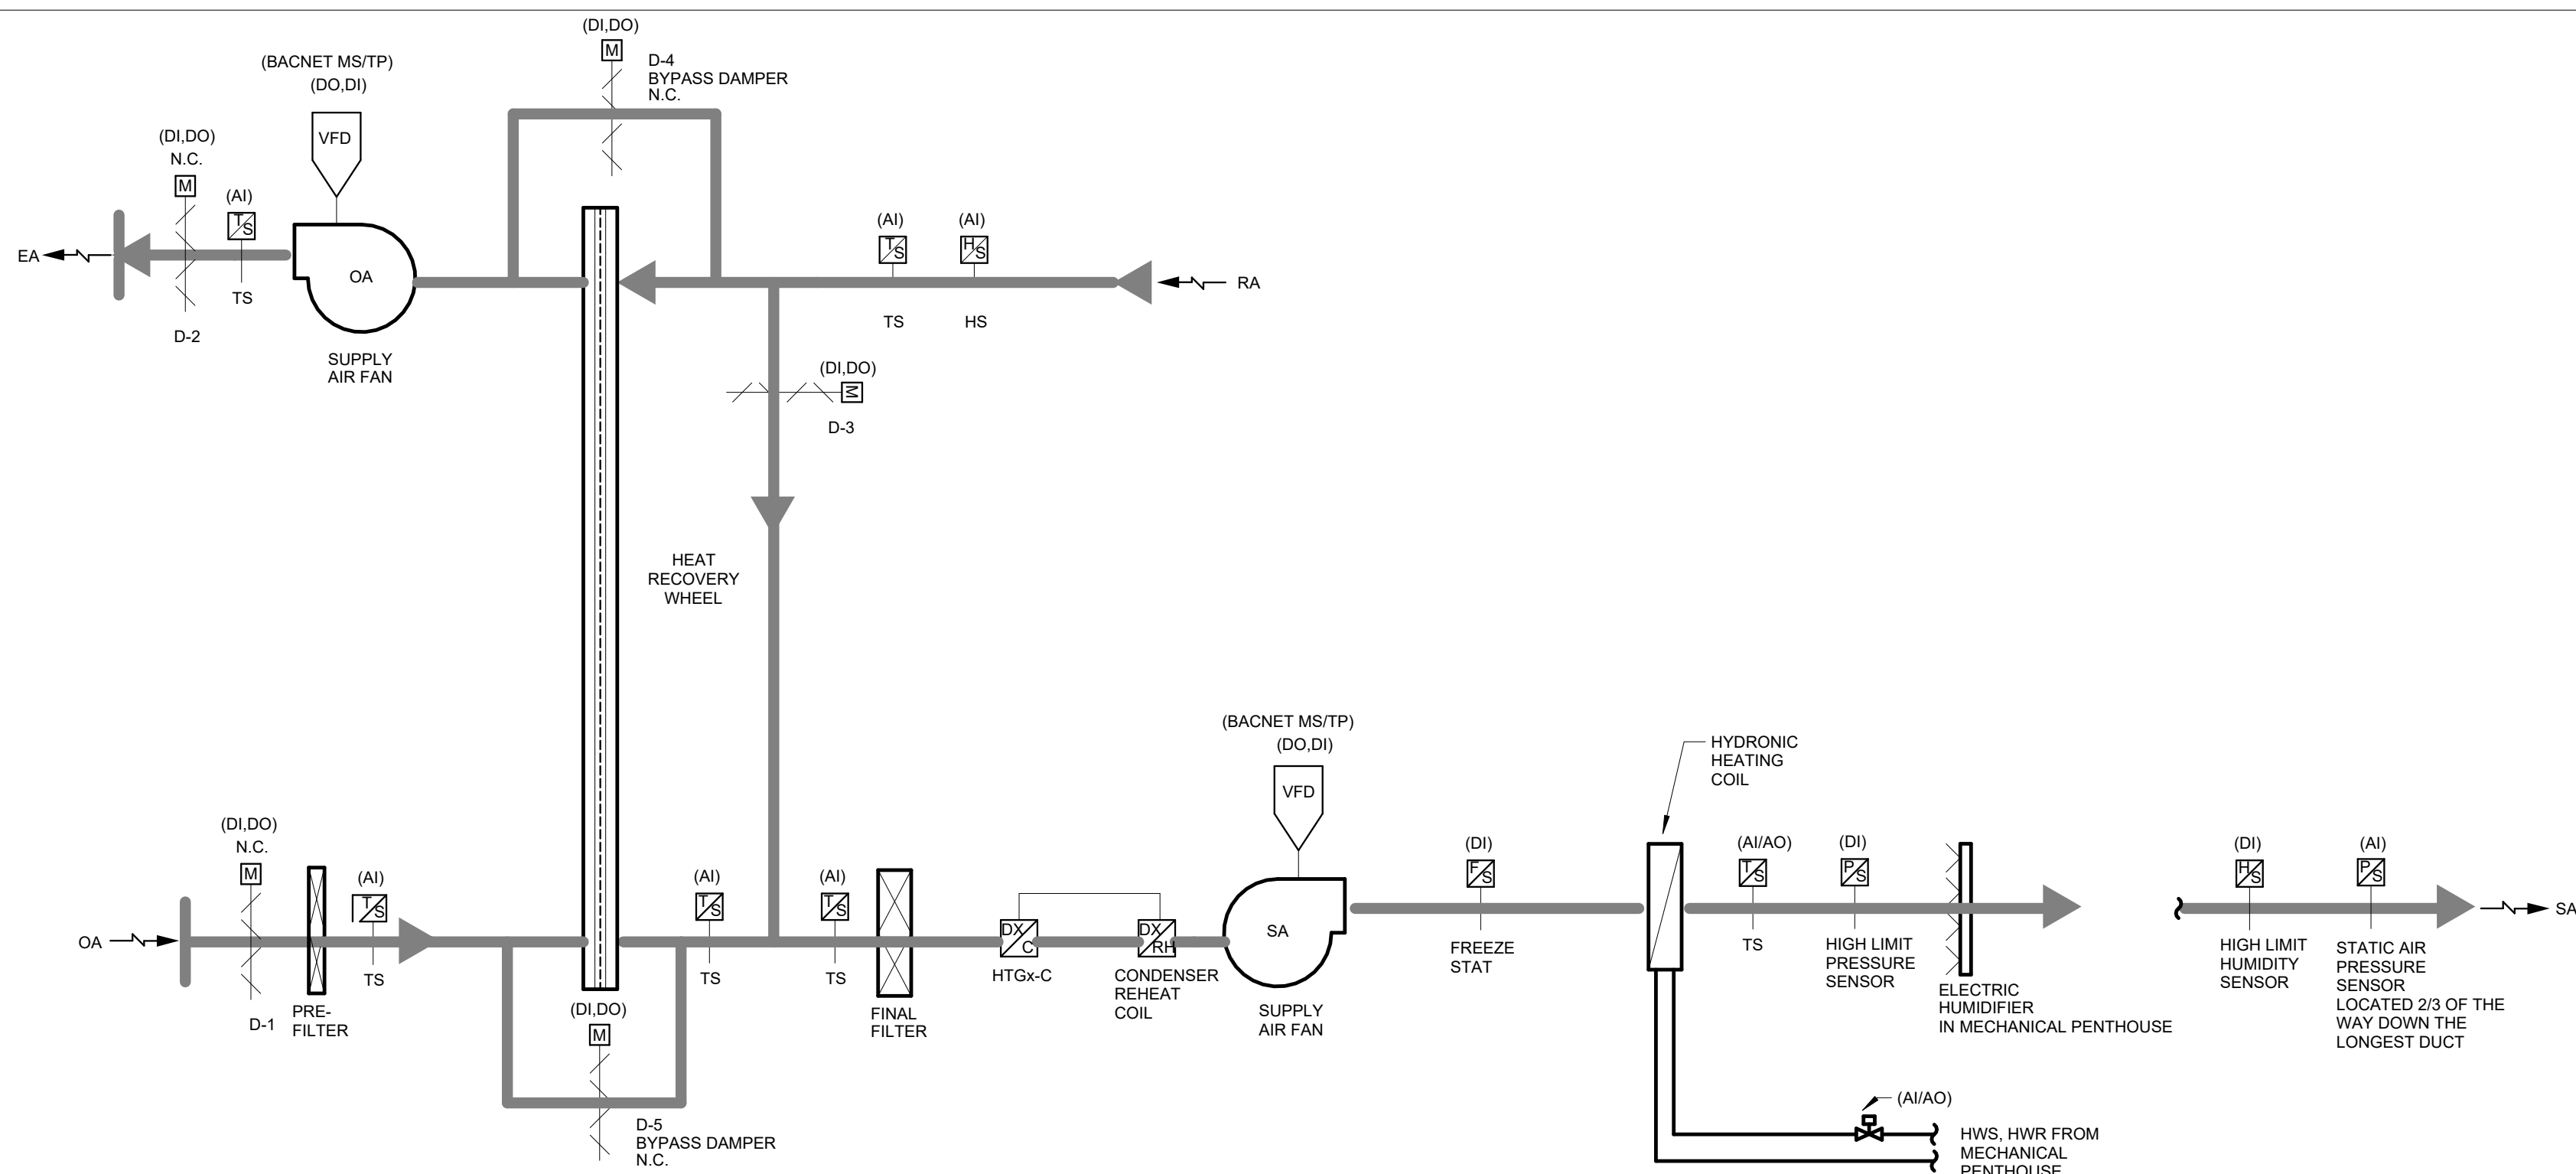

RTU CONTROL SCHEMATIC AND SEQUENCE OF OPERATION

N.T.S. M1000

Airflow plan view

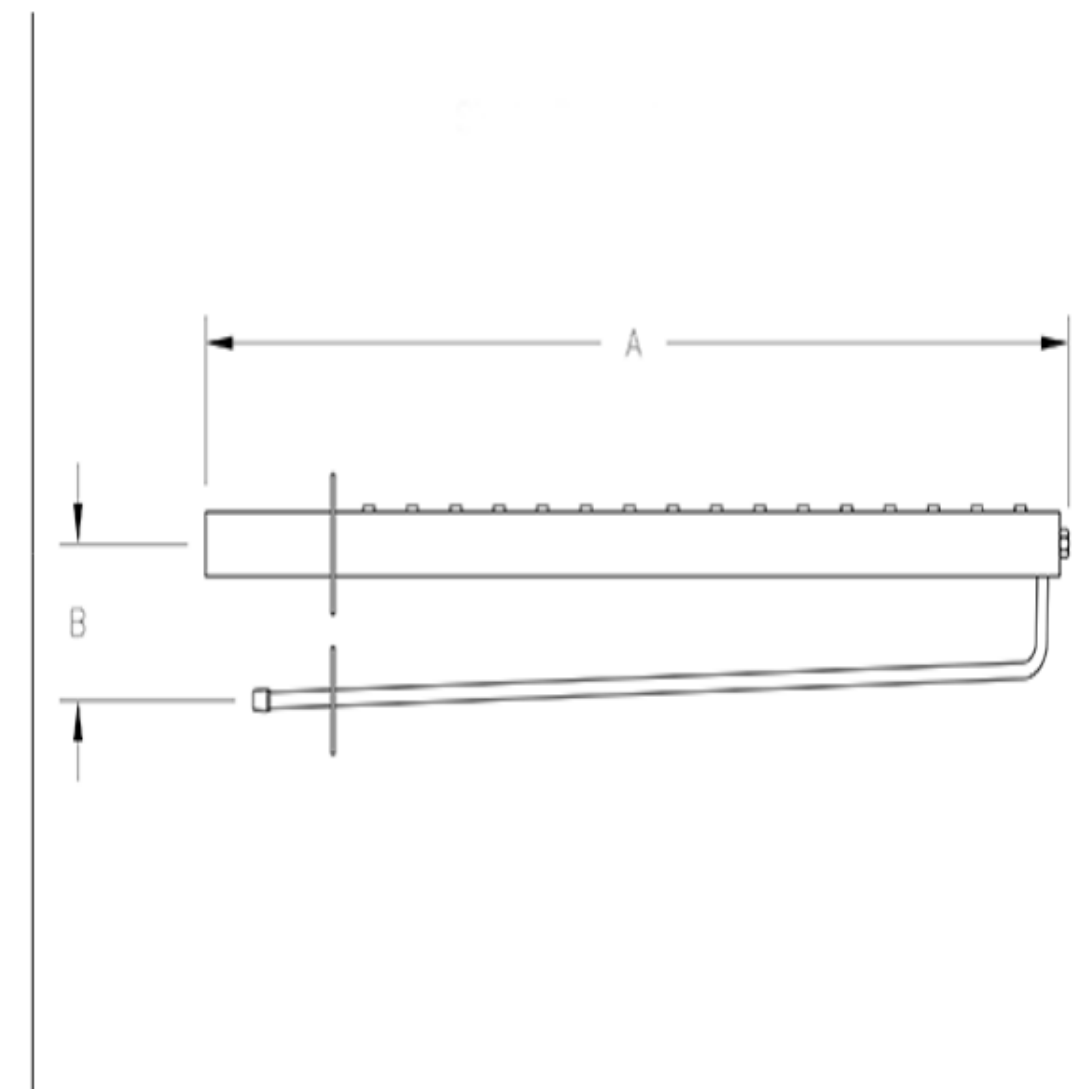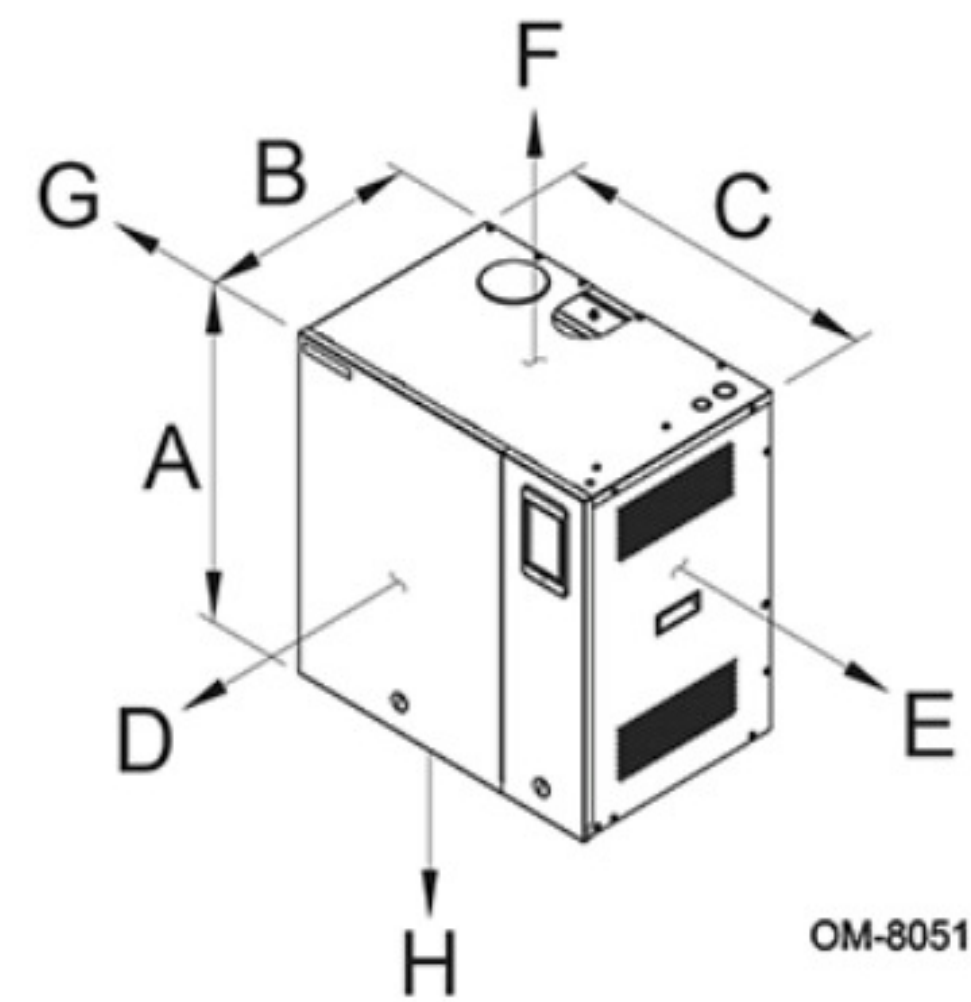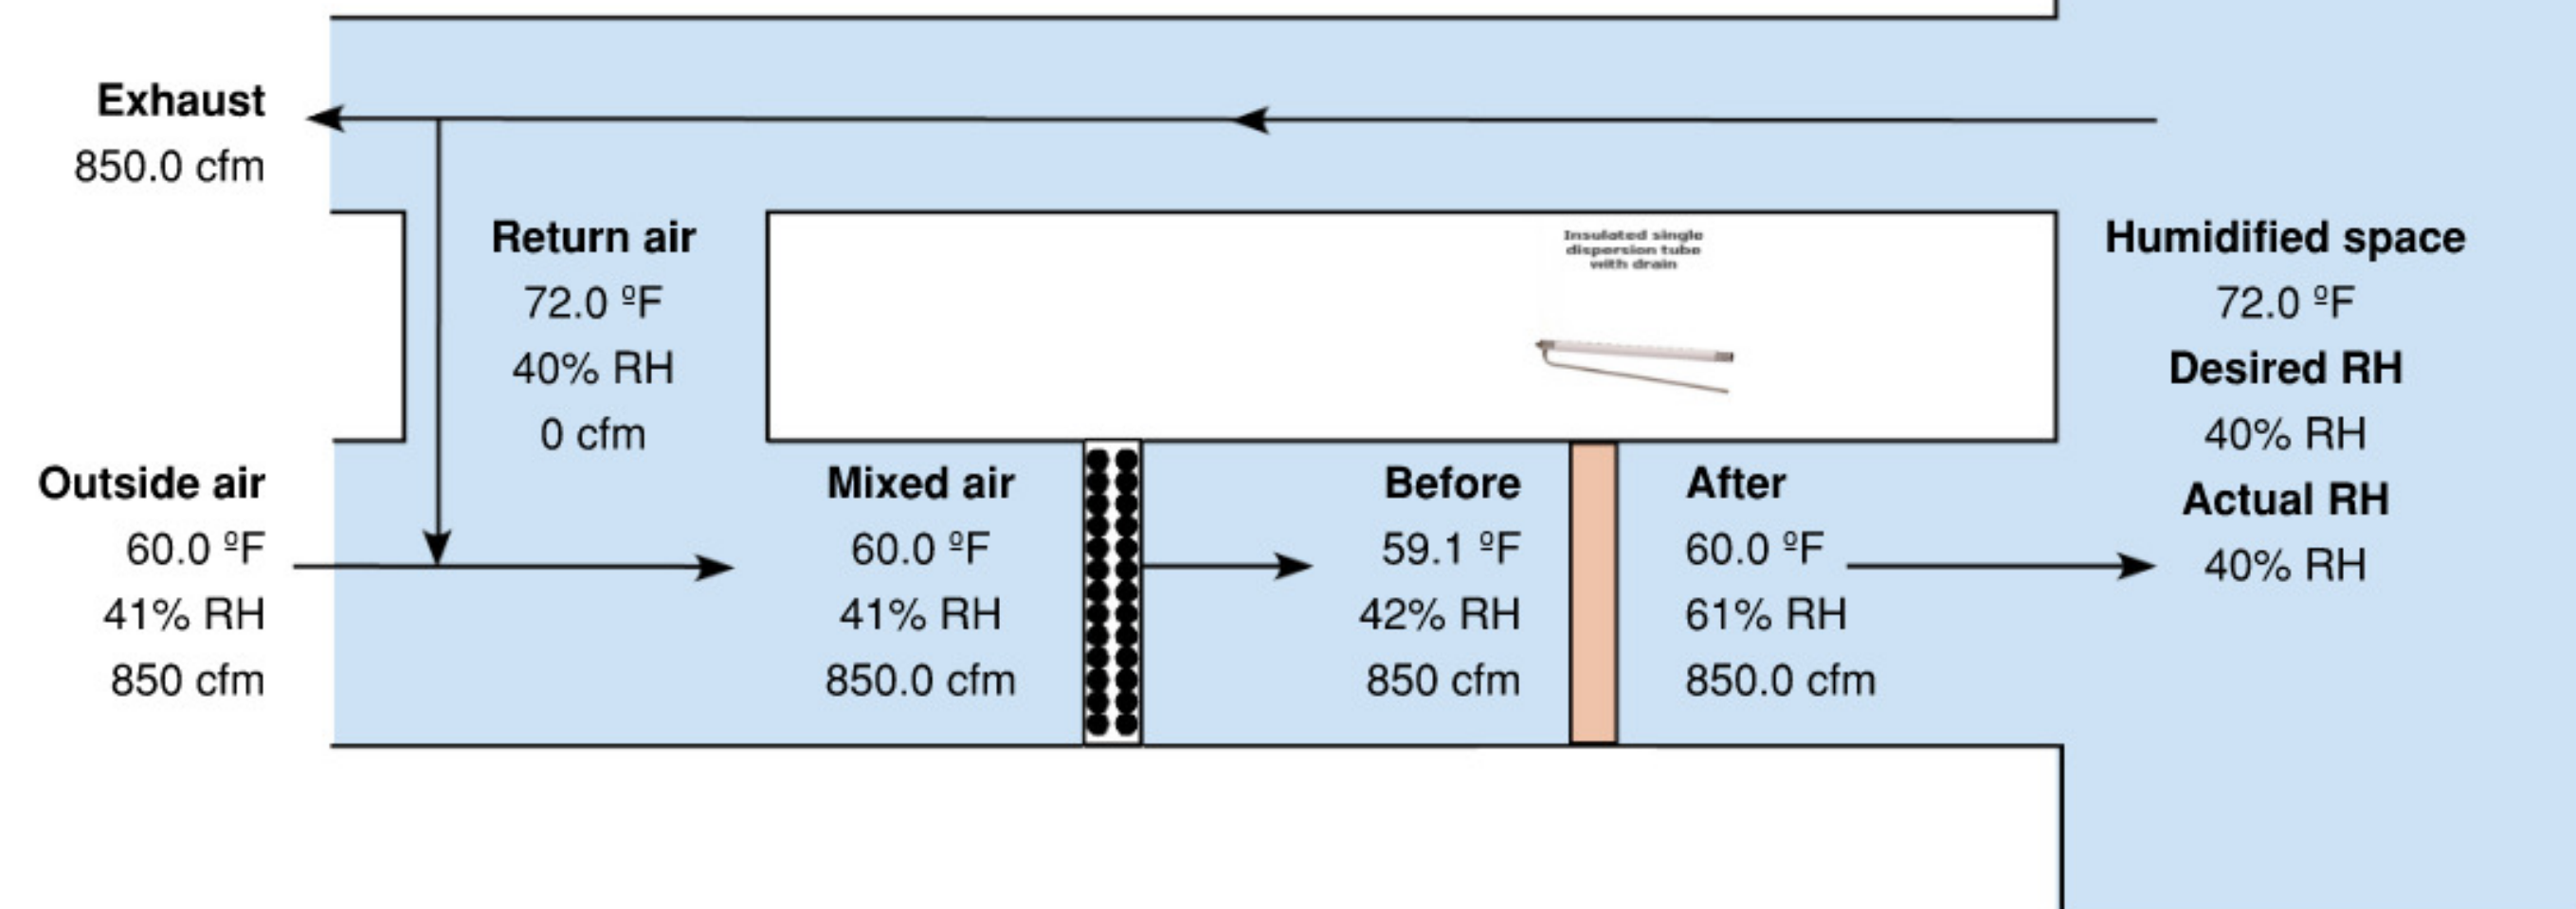


HUMIDIFIER DETAIL

1 : 1


1

M1100

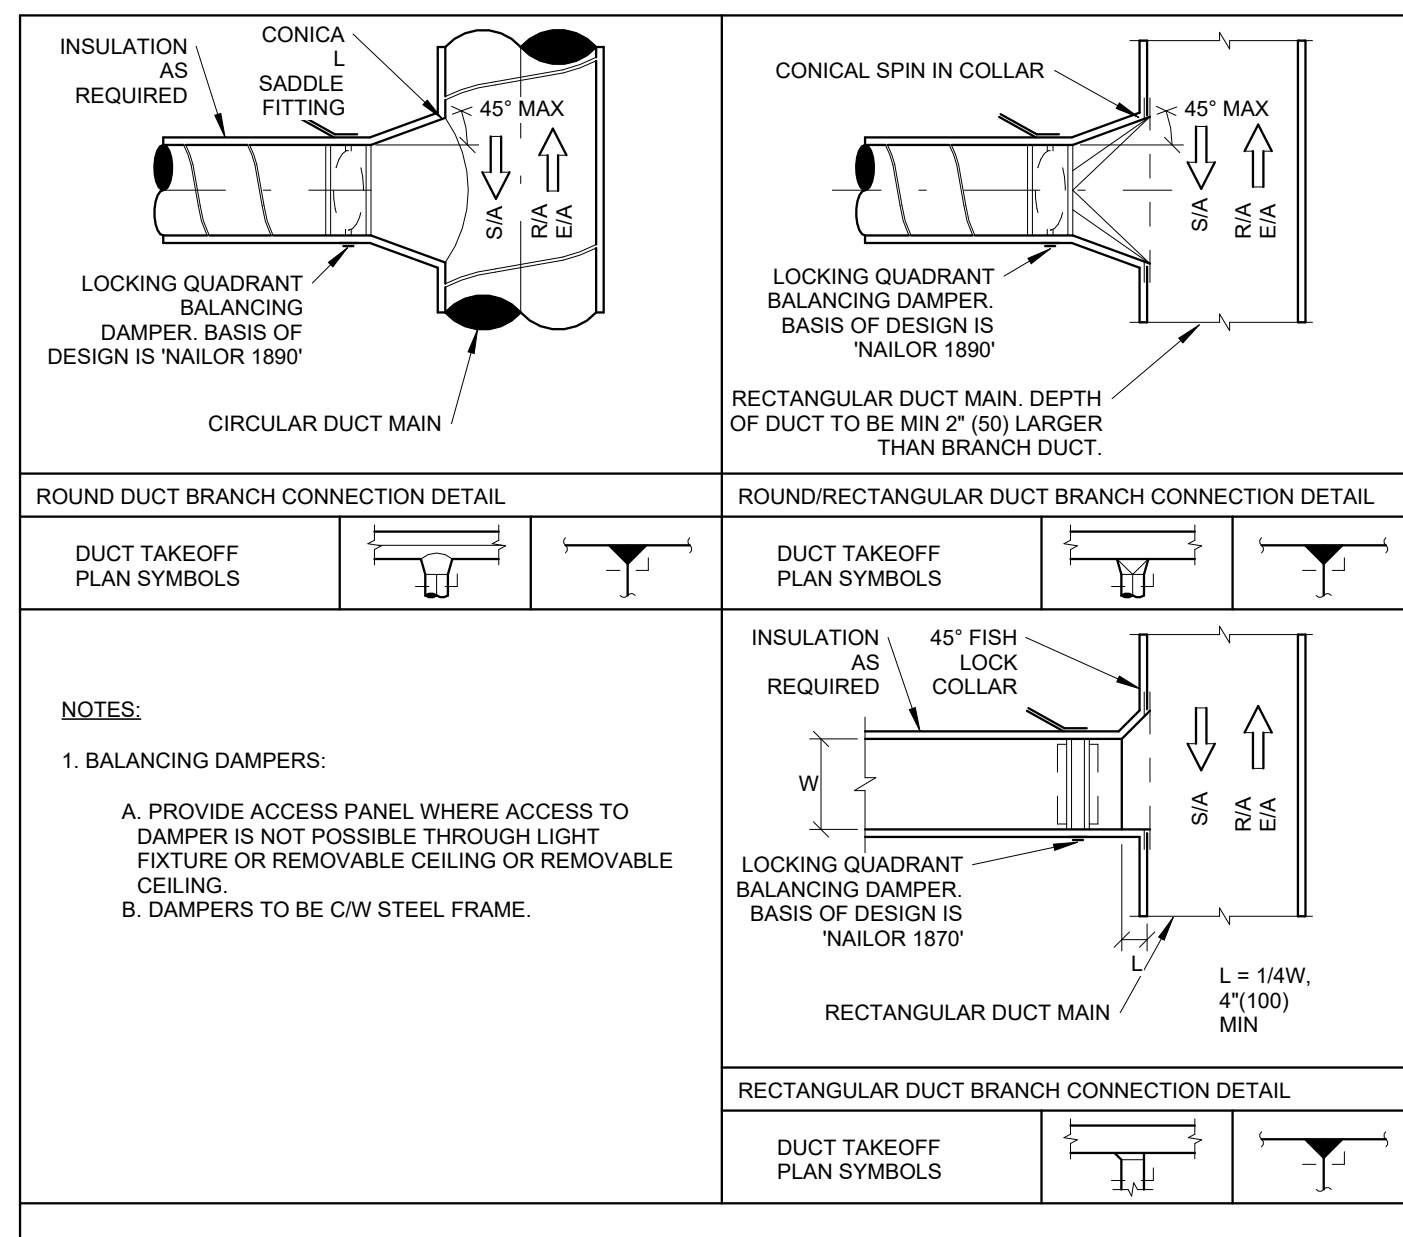

DUCT BRANCH CONNECTION DETAIL

N.T.S.	3 M1100
--------	------------

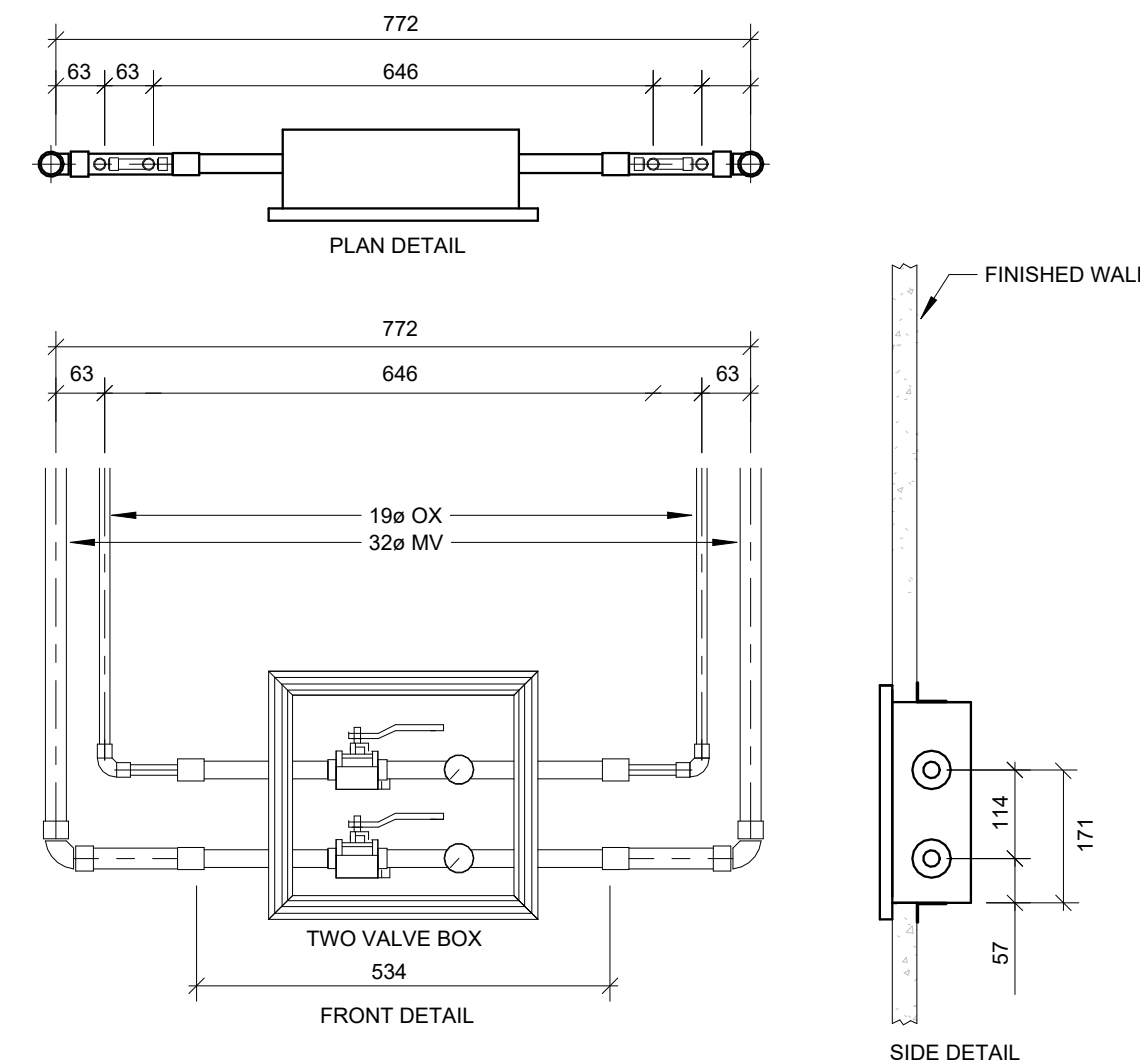


REFER TO MANUFACTURERS SHOP DRAWINGS FOR WALL THICKNESS REQUIREMENTS AND ZONE VALVE BOX DIMENSIONS

RECESSED MED GAS ZONE 2-VALVE DETAIL

N.T.S.

4

M1100

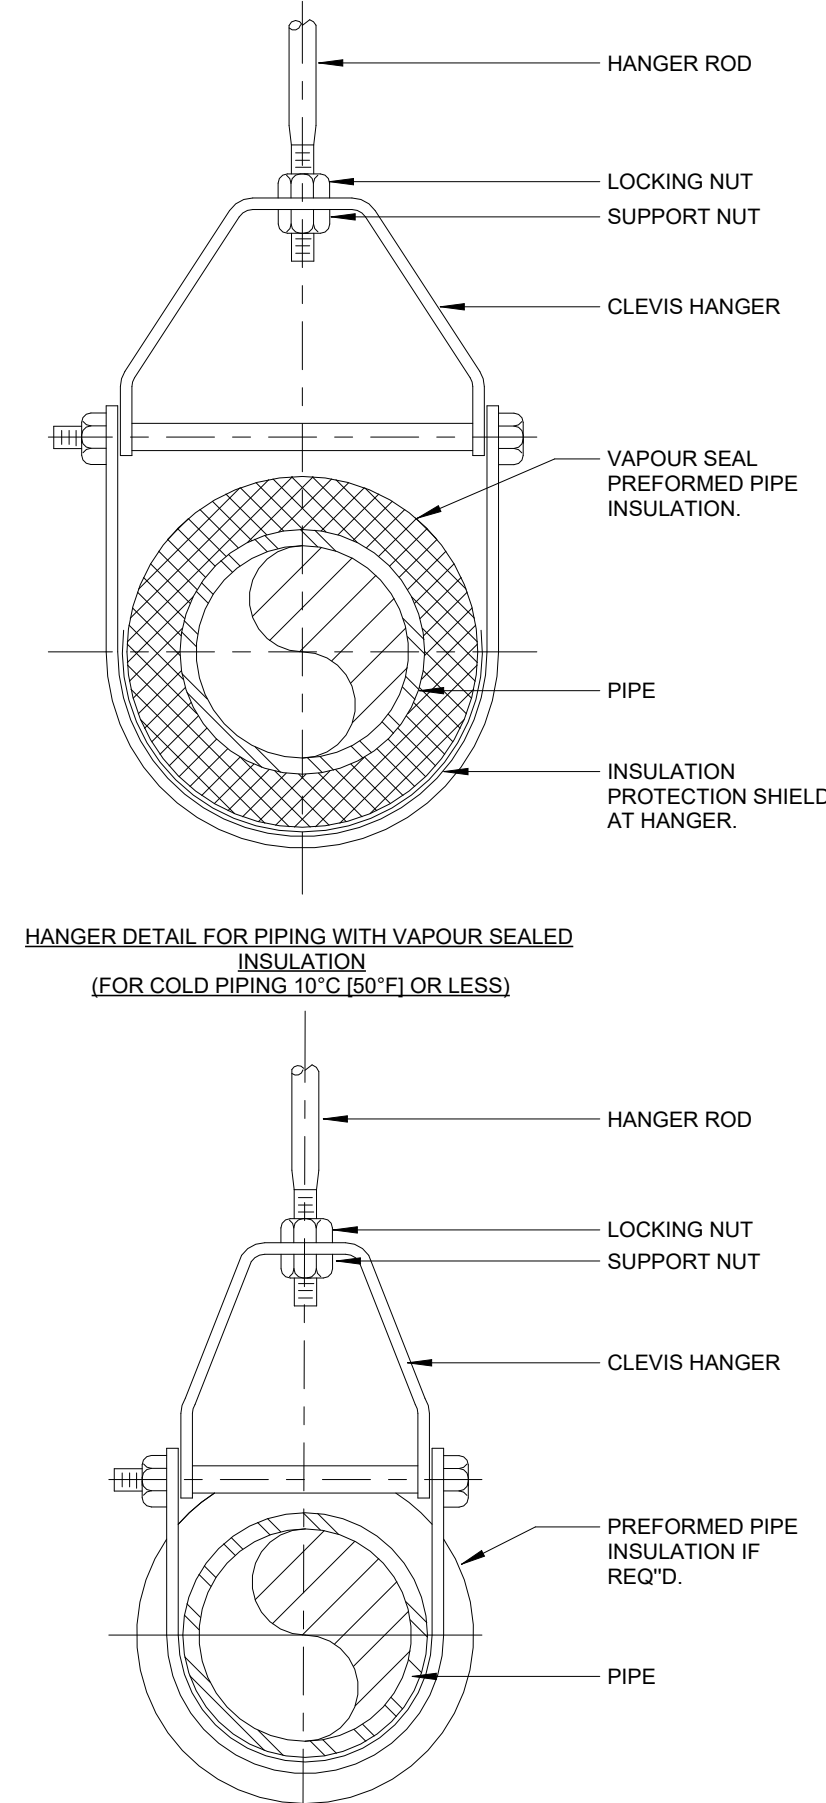


PIPE HANGER DETAIL


1:1

2


M1100

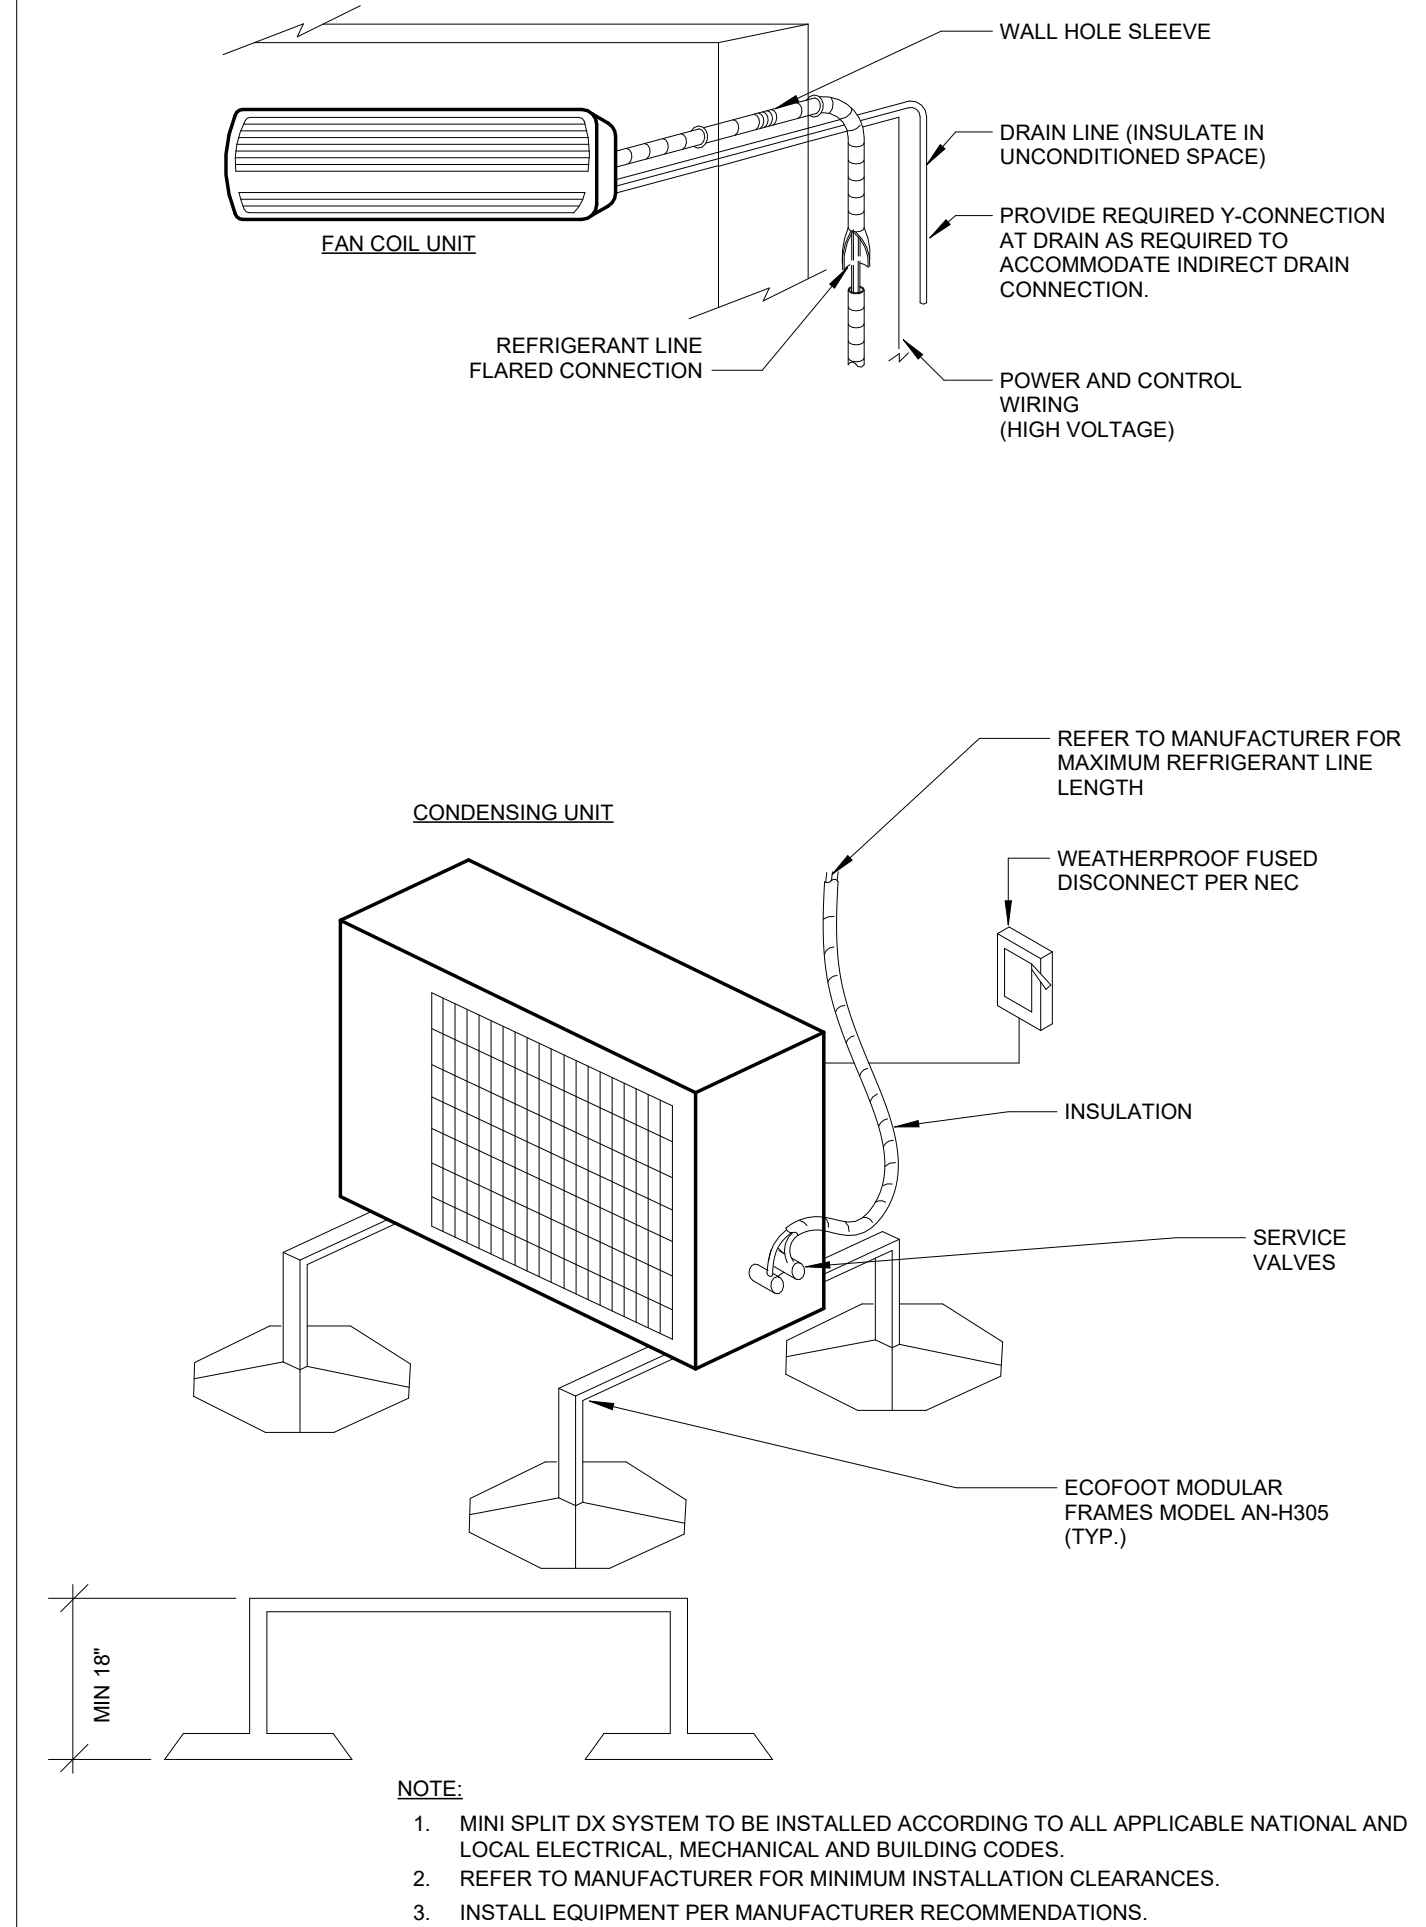

A/C MOUNTING DETAIL	7
N.T.S.	M110

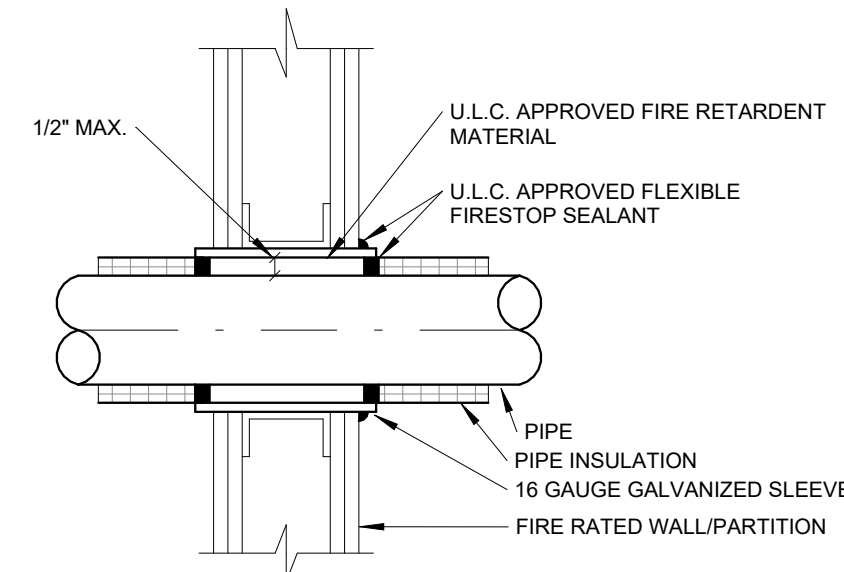

DETAIL OF PIPE SLEEVE THROUGH FIRE RATED WALL

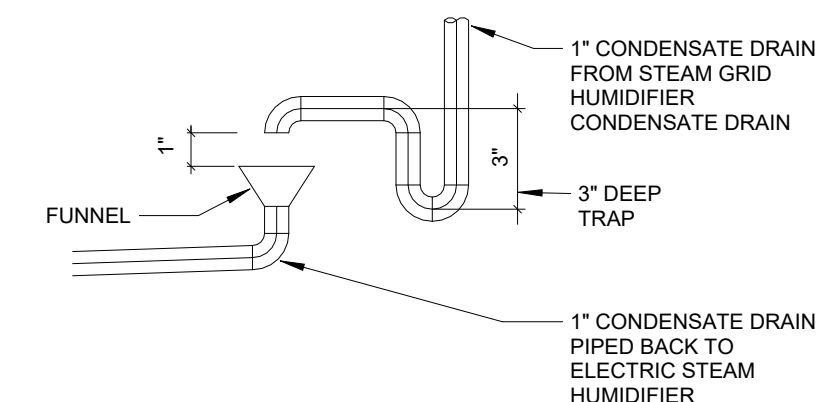

HUMIDIFIER CONDENSATE DRAIN DETAIL

N.T.S.

6
M1100

PROJECT LOGO

KEY PLAN

**ISSUED FOR TENDER
(2026.02.27)**

7	ISSUED FOR TENDER	2028.04.10
6	ISSUED FOR TENDER	2025.12.12
5	ISSUED FOR PERMIT	2025.11.28
4	FINAL DESIGN DEVELOPMENT SET	2025.11.07
3	100% DESIGN DEVELOPMENT SET	2025.10.31
2	100% DESIGN DEVELOPMENT PROGRESS SET	2025.09.29
1	50% DESIGN DEVELOPMENT PROGRESS SET	2025.05.09
No.	DESCRIPTION	DATE

REVISIONS:

DISCREPANCIES MUST BE REPORTED IMMEDIATELY TO THE ARCHITECT / ENGINEER BEFORE PROCEEDING.

ONLY FIGURED DIMENSIONS MUST BE USED.

THE CONTRACTOR MUST CHECK THE DIMENSIONS ON SITE.

THE DRAWING IS PROTECTED BY COPYRIGHT.

ALL DIMENSIONS ARE SHOWN IN MILLIMETERS.

DO NOT SCALE THE DRAWINGS.

mcCallumSather
Westinghouse HQ, 2nd Floor
286 Sanford Ave. N
Hamilton, ON L8L 6A1
905.526.6700
www.mccallumsather.com

SEAL

CONSULTANTS:

PROJECT:

WATERLOO REGIONAL HEALTH
NETWORK @ MODTPWN - PET CT

835 KING ST W, KITCHENER, ON
N2G 1G

DRAWING TITLE:
DETAILS






DRAWN BY:	DATE:
-----------	-------

CHECKED BY:	SCALE:
-------------	--------

PROJECT NO.: 24048

DRAWING NO.:

11100

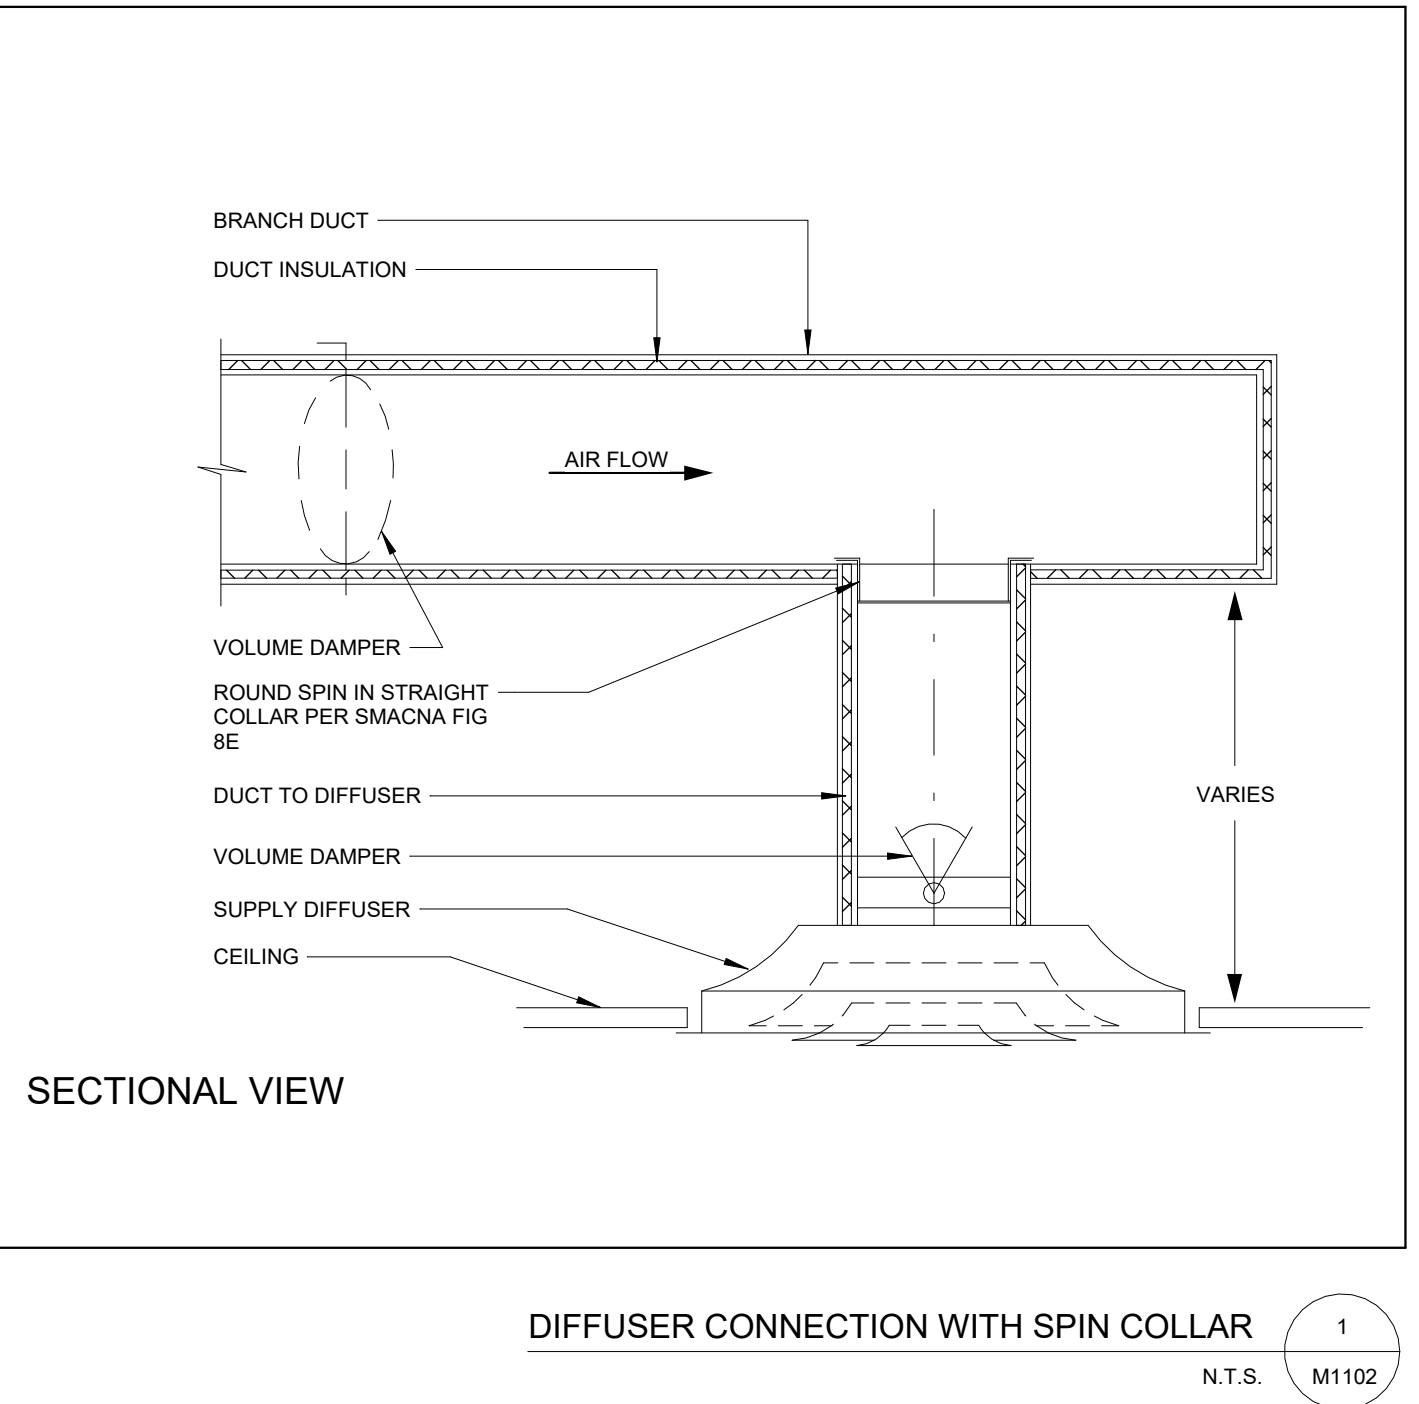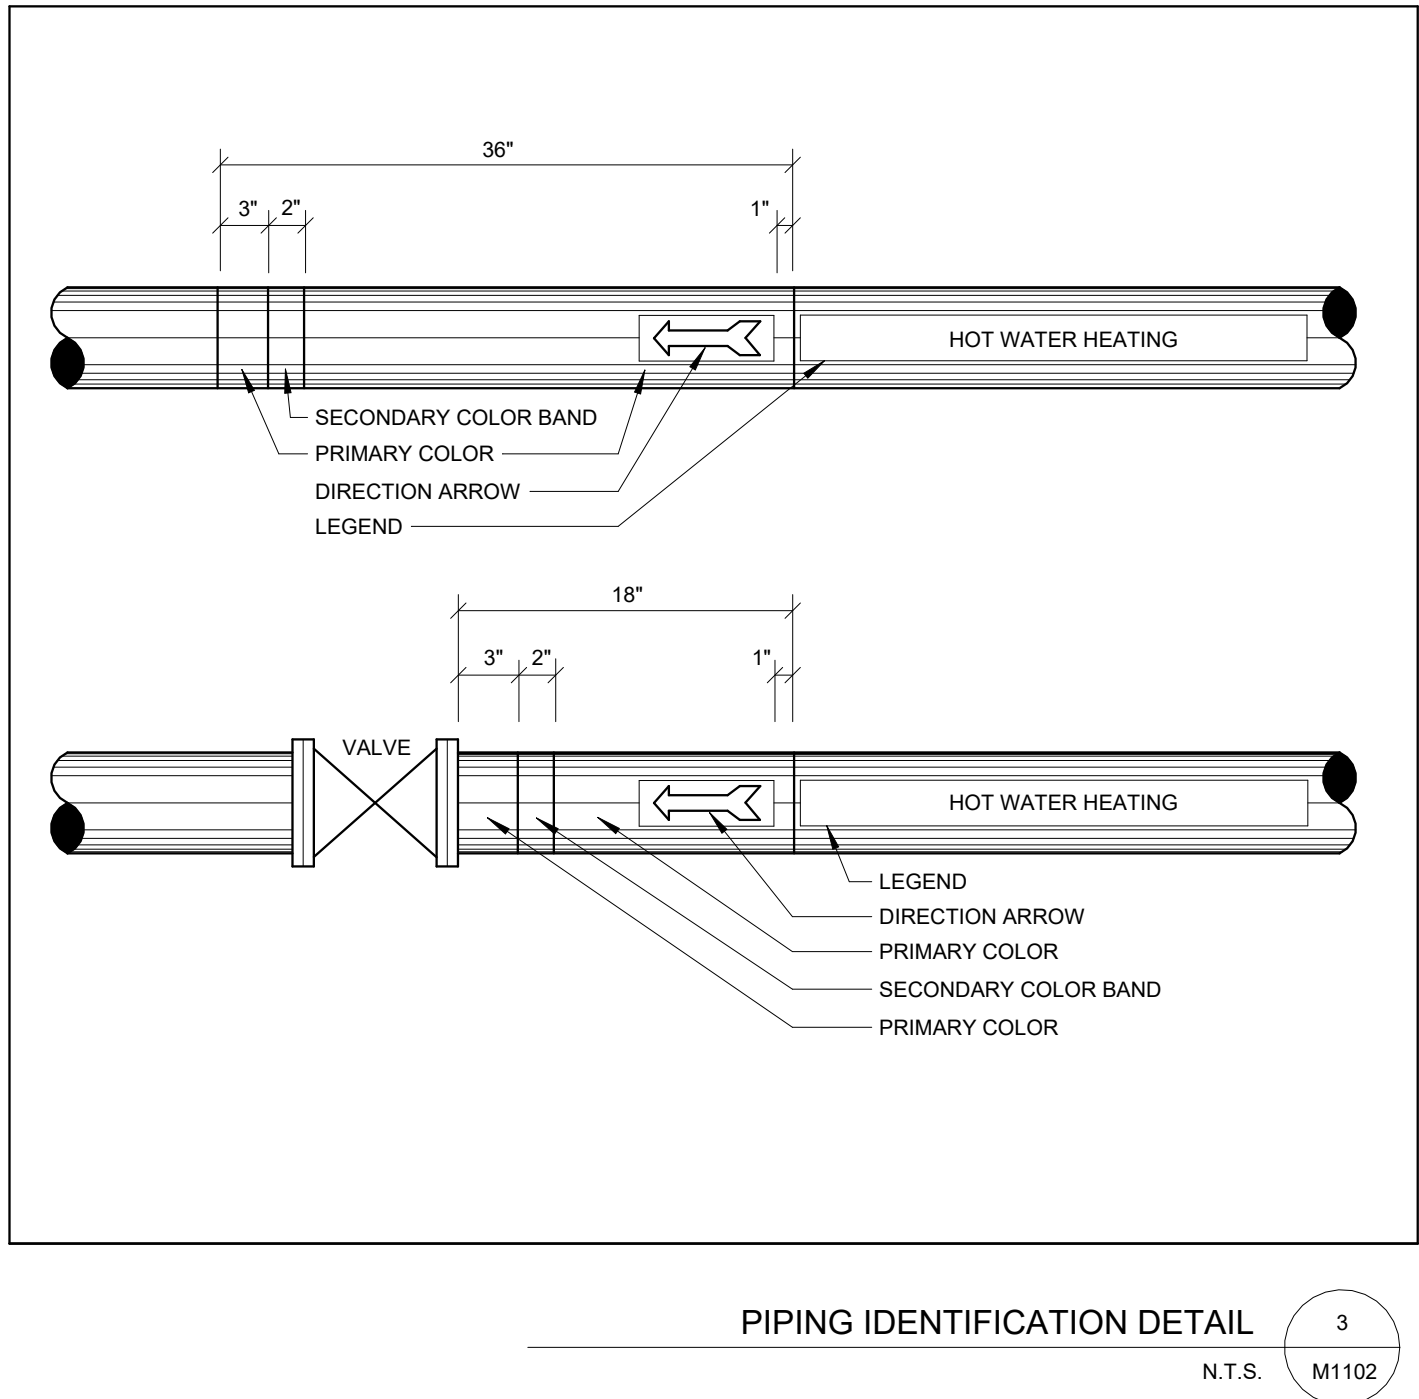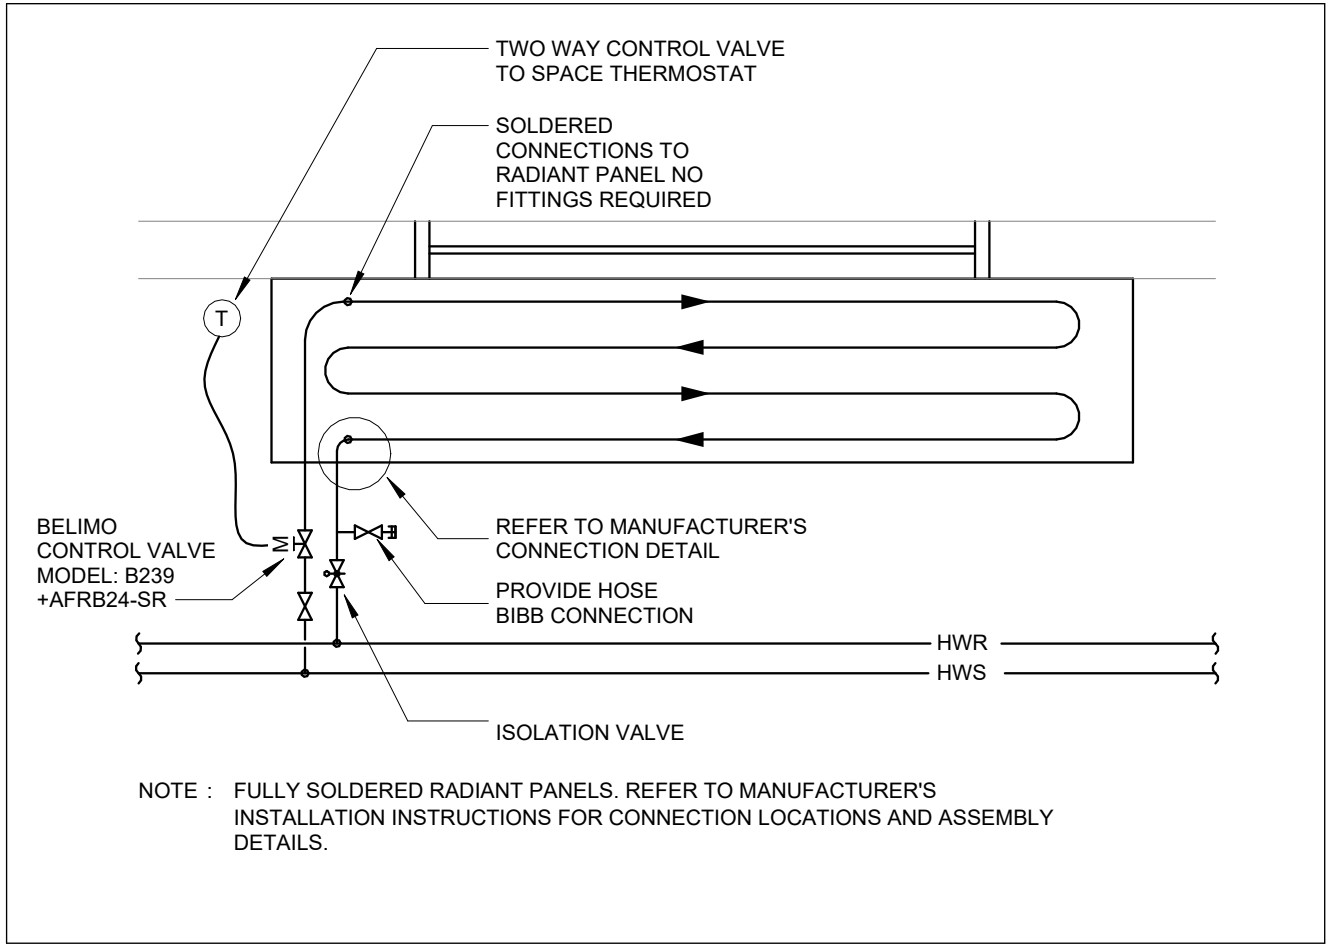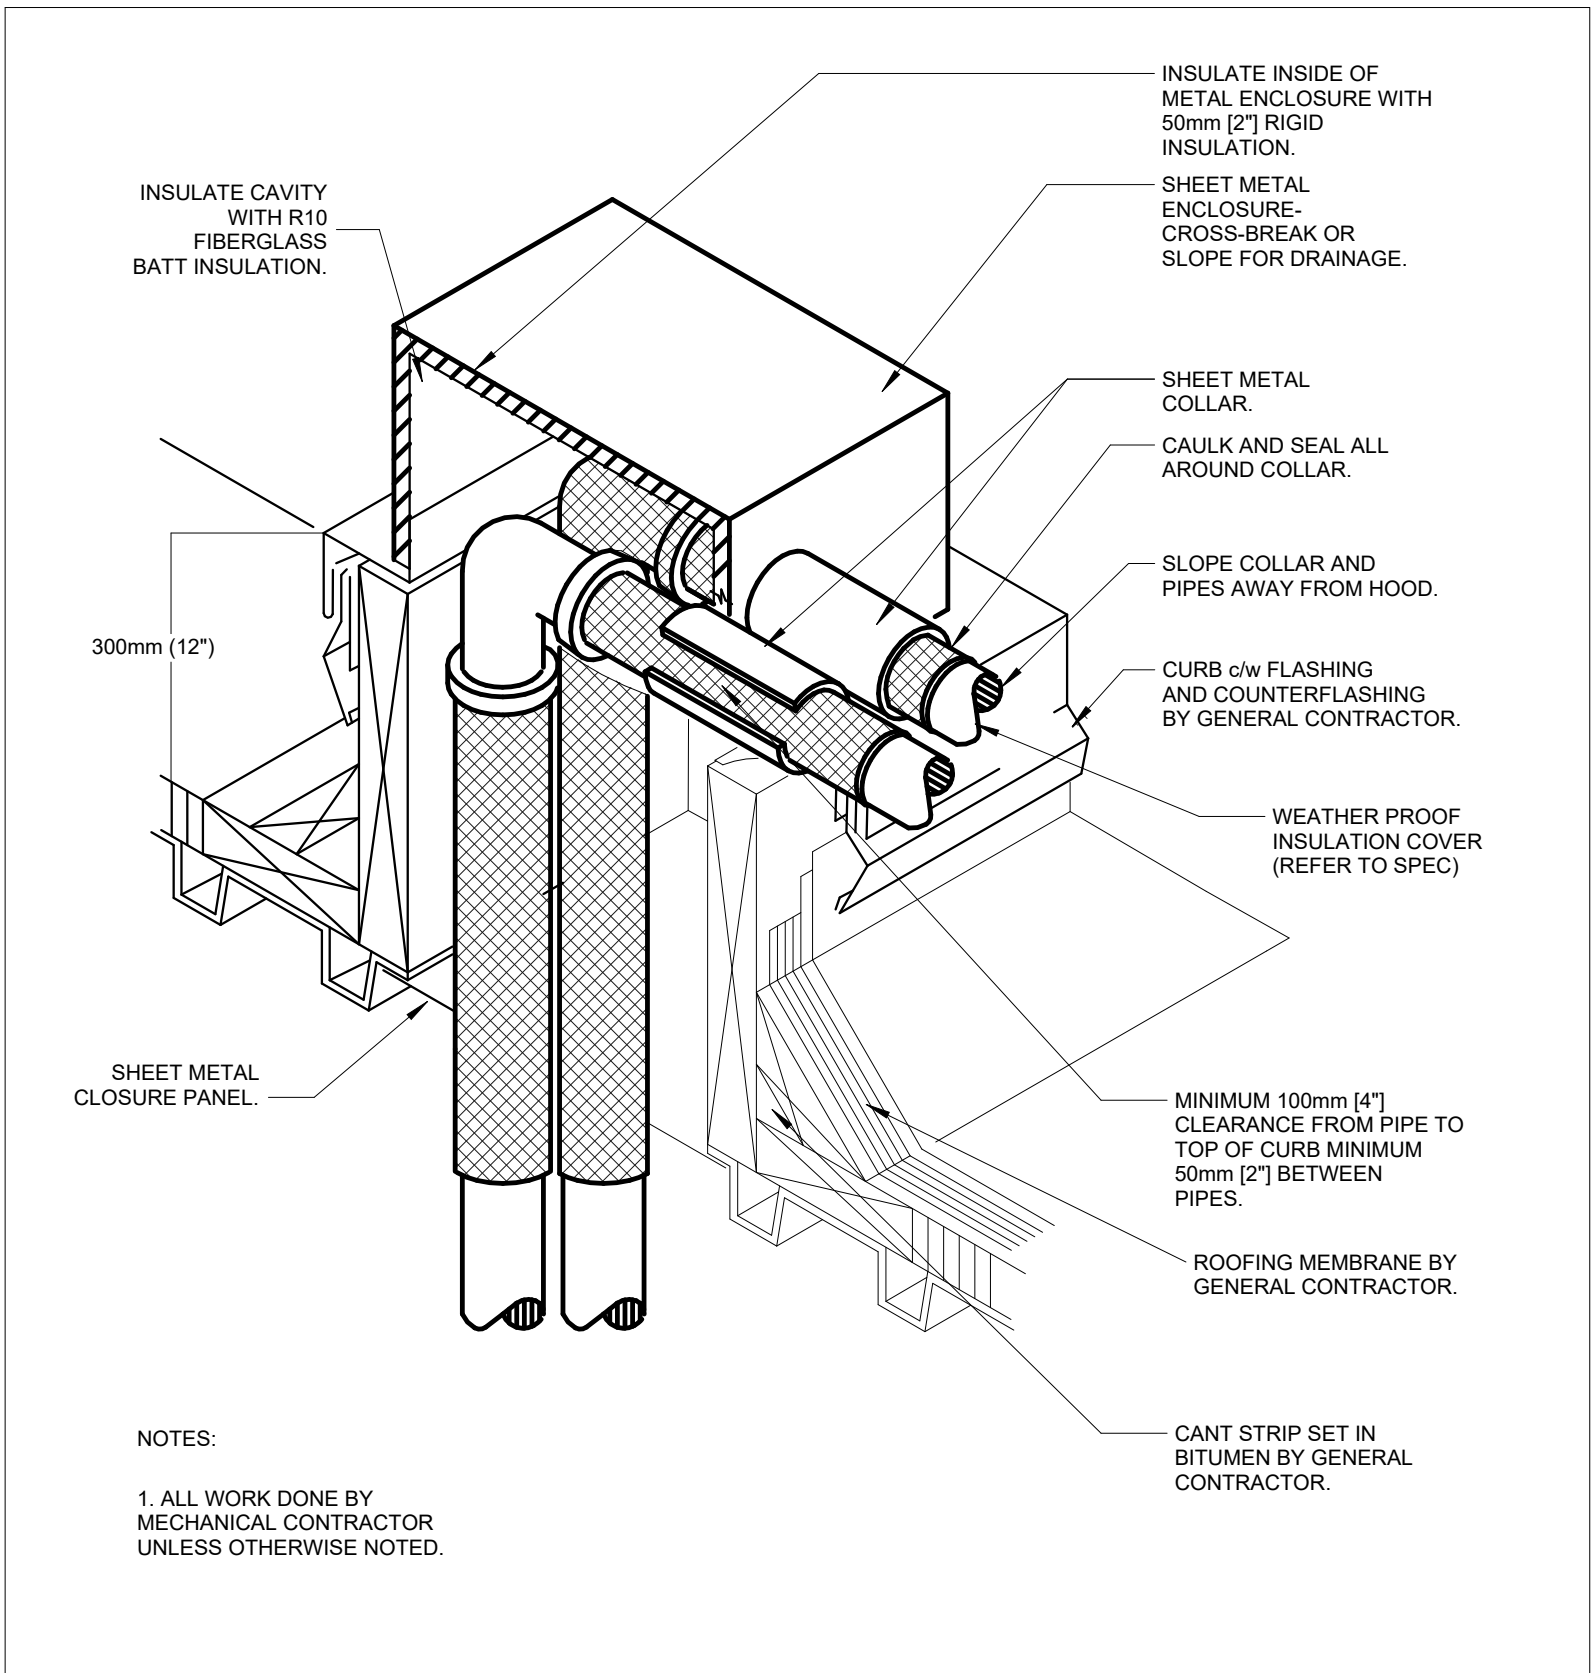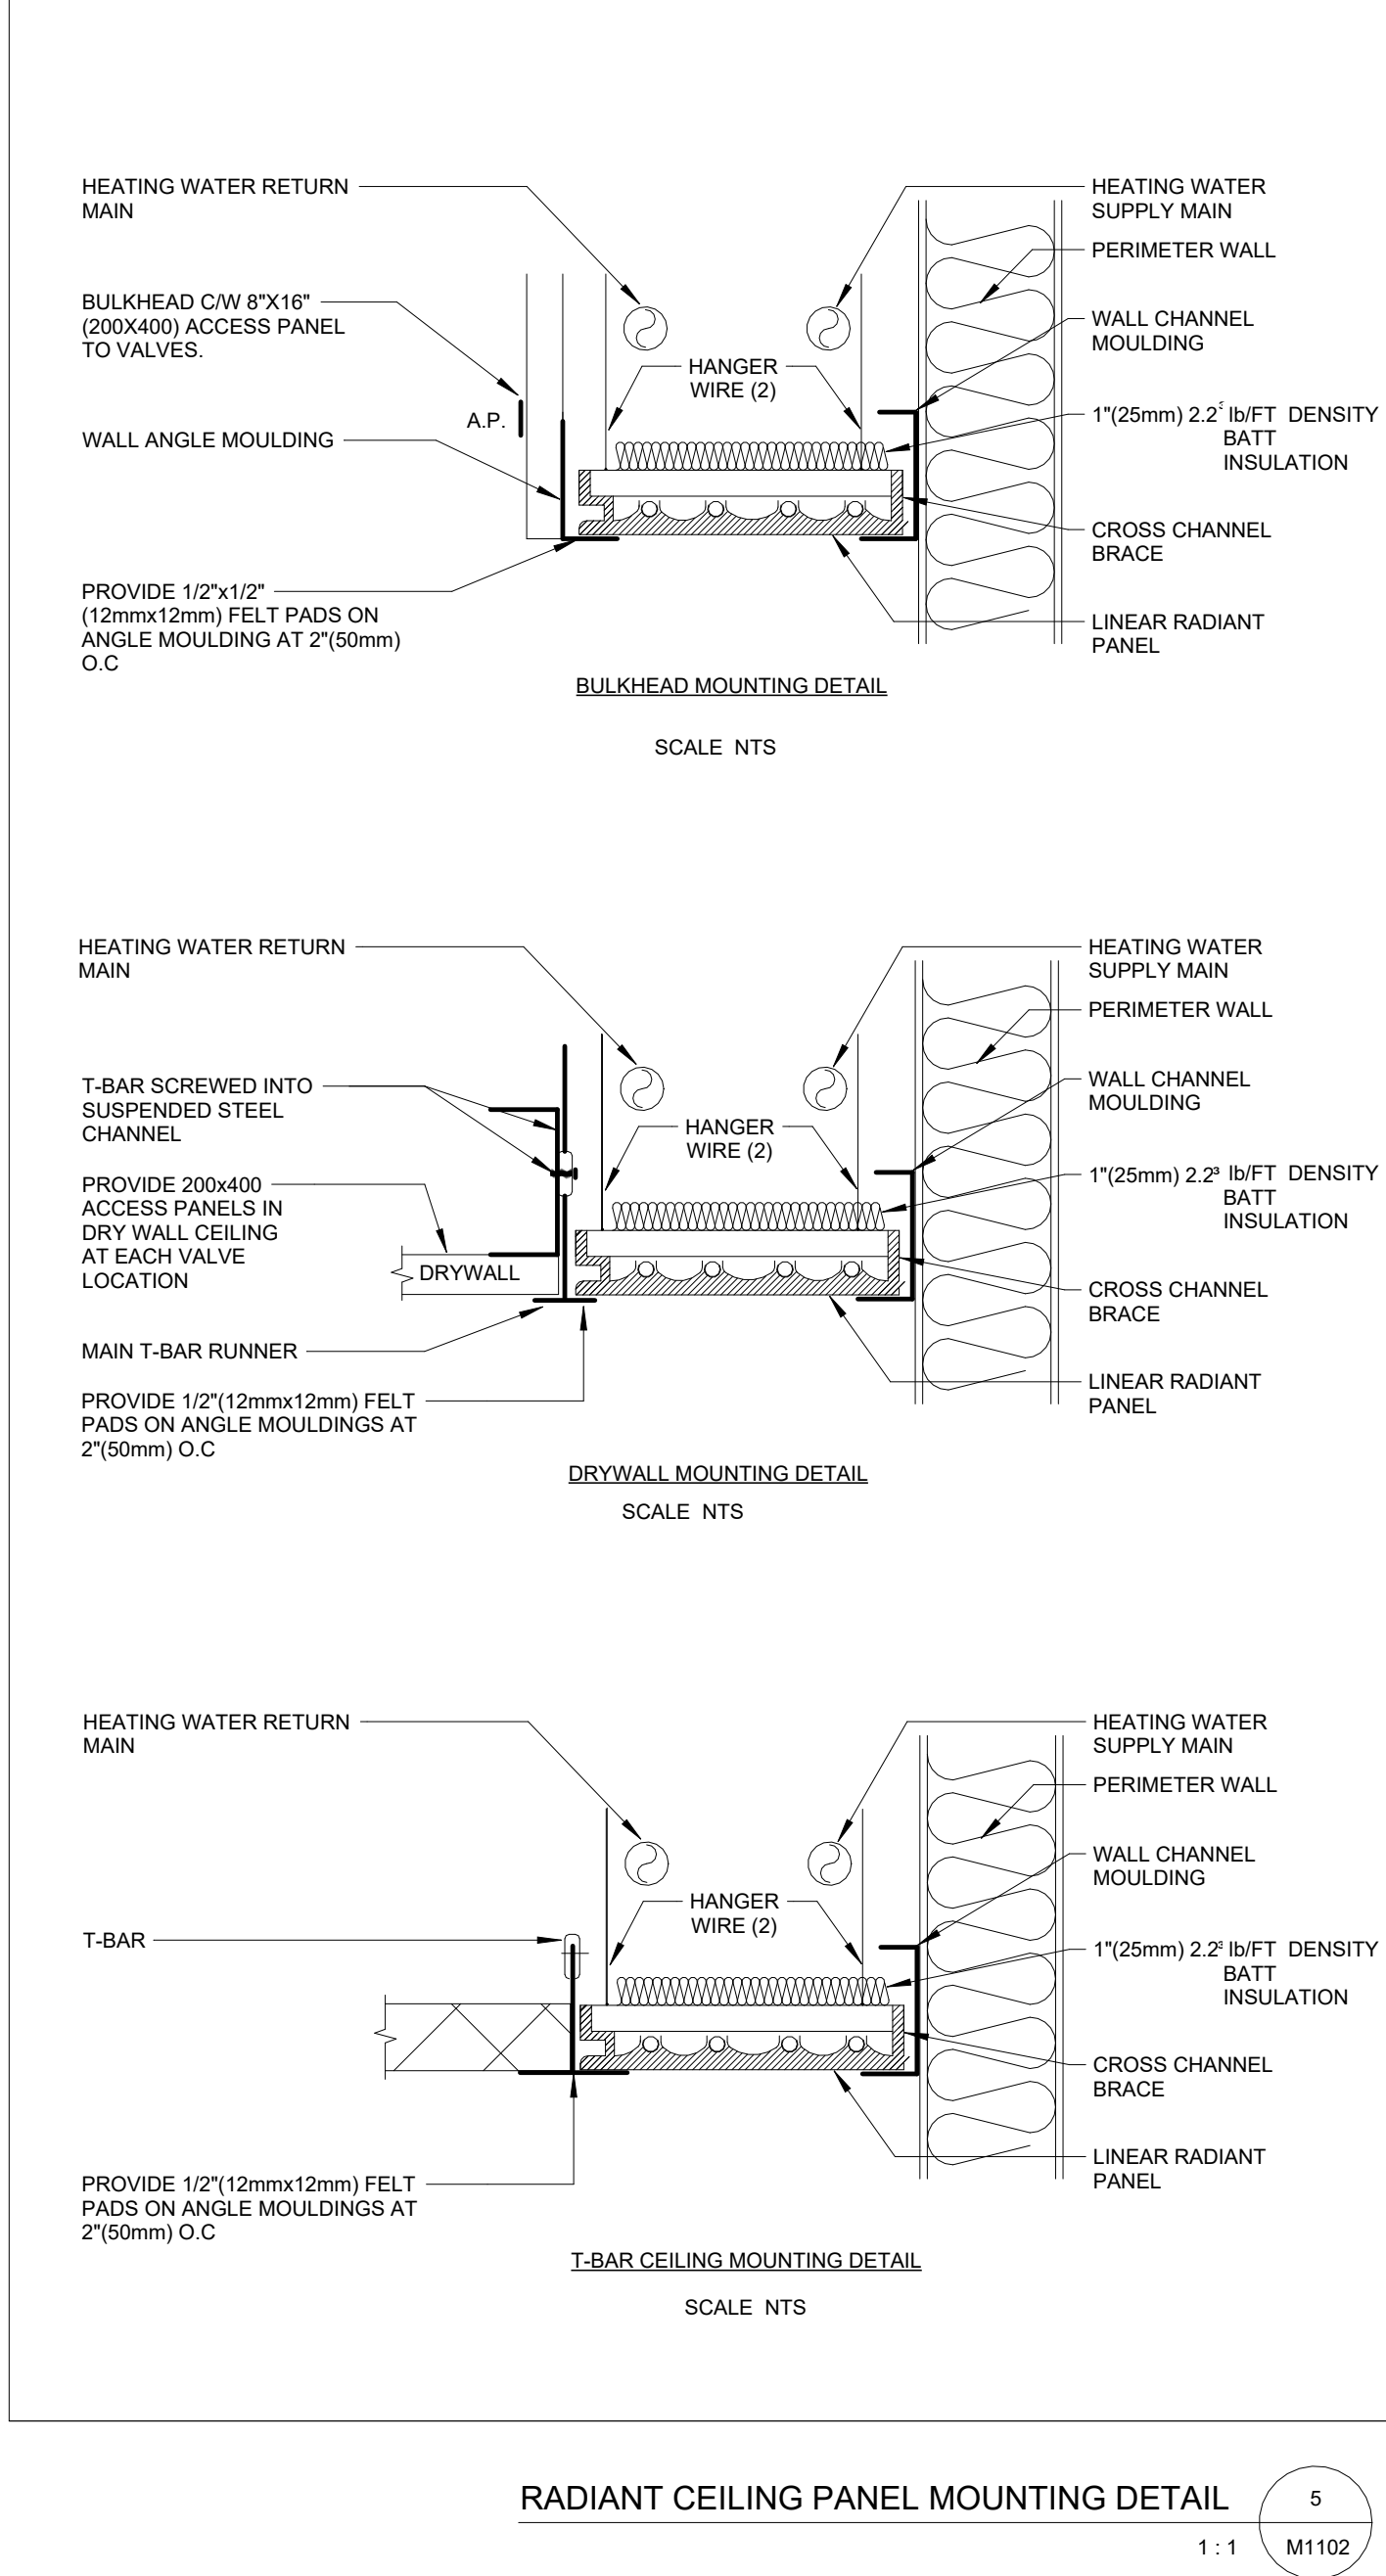

PROJECT LOGO

KEY PLAN

ISSUED FOR TENDER
(2026.02.27)

7	ISSUED FOR TENDER	2026.04.10
6	ISSUED FOR TENDER	2025.12.12
5	ISSUED FOR PERMIT	2025.11.26
4	FINAL DESIGN DEVELOPMENT SET	2025.11.07
3	100% DESIGN DEVELOPMENT SET	2025.10.31
2	100% DESIGN DEVELOPMENT PROGRESS SET	2025.09.29
1	50% DESIGN DEVELOPMENT PROGRESS SET	2025.05.09

REVISIONS:

No.	DESCRIPTION	DATE

DISCREPANCIES MUST BE REPORTED IMMEDIATELY TO THE ARCHITECT/ENGINEER BEFORE PROCEEDING.
ONLY FIGURED DIMENSIONS MUST BE USED.
THE CONTRACTOR MUST CHECK THE DIMENSIONS ON SITE.
THE DRAWING IS PROTECTED BY COPYRIGHT.
ALL DIMENSIONS ARE SHOWN IN MILLIMETERS.
DO NOT SCALE THE DRAWINGS.

mcCallumSather
Westinghouse HQ, 2nd Floor
286 Sanford Ave. N
Hamilton, ON L8L 6A1
905.526.6700
www.mccallumsather.com

SEAL

CONSULTANTS:

PROJECT:
WATERLOO REGIONAL HEALTH NETWORK @ MODTPWN - PET CT

835 KING ST W, KITCHENER, ON N2G 1G

DRAWING TITLE:
DETAILS

DRAWN BY:	SB.MC	DATE:	2024/09/01
CHECKED BY:	DR. AB	SCALE:	

PROJECT NO: **24048**

DRAWING NO:

M1102

